


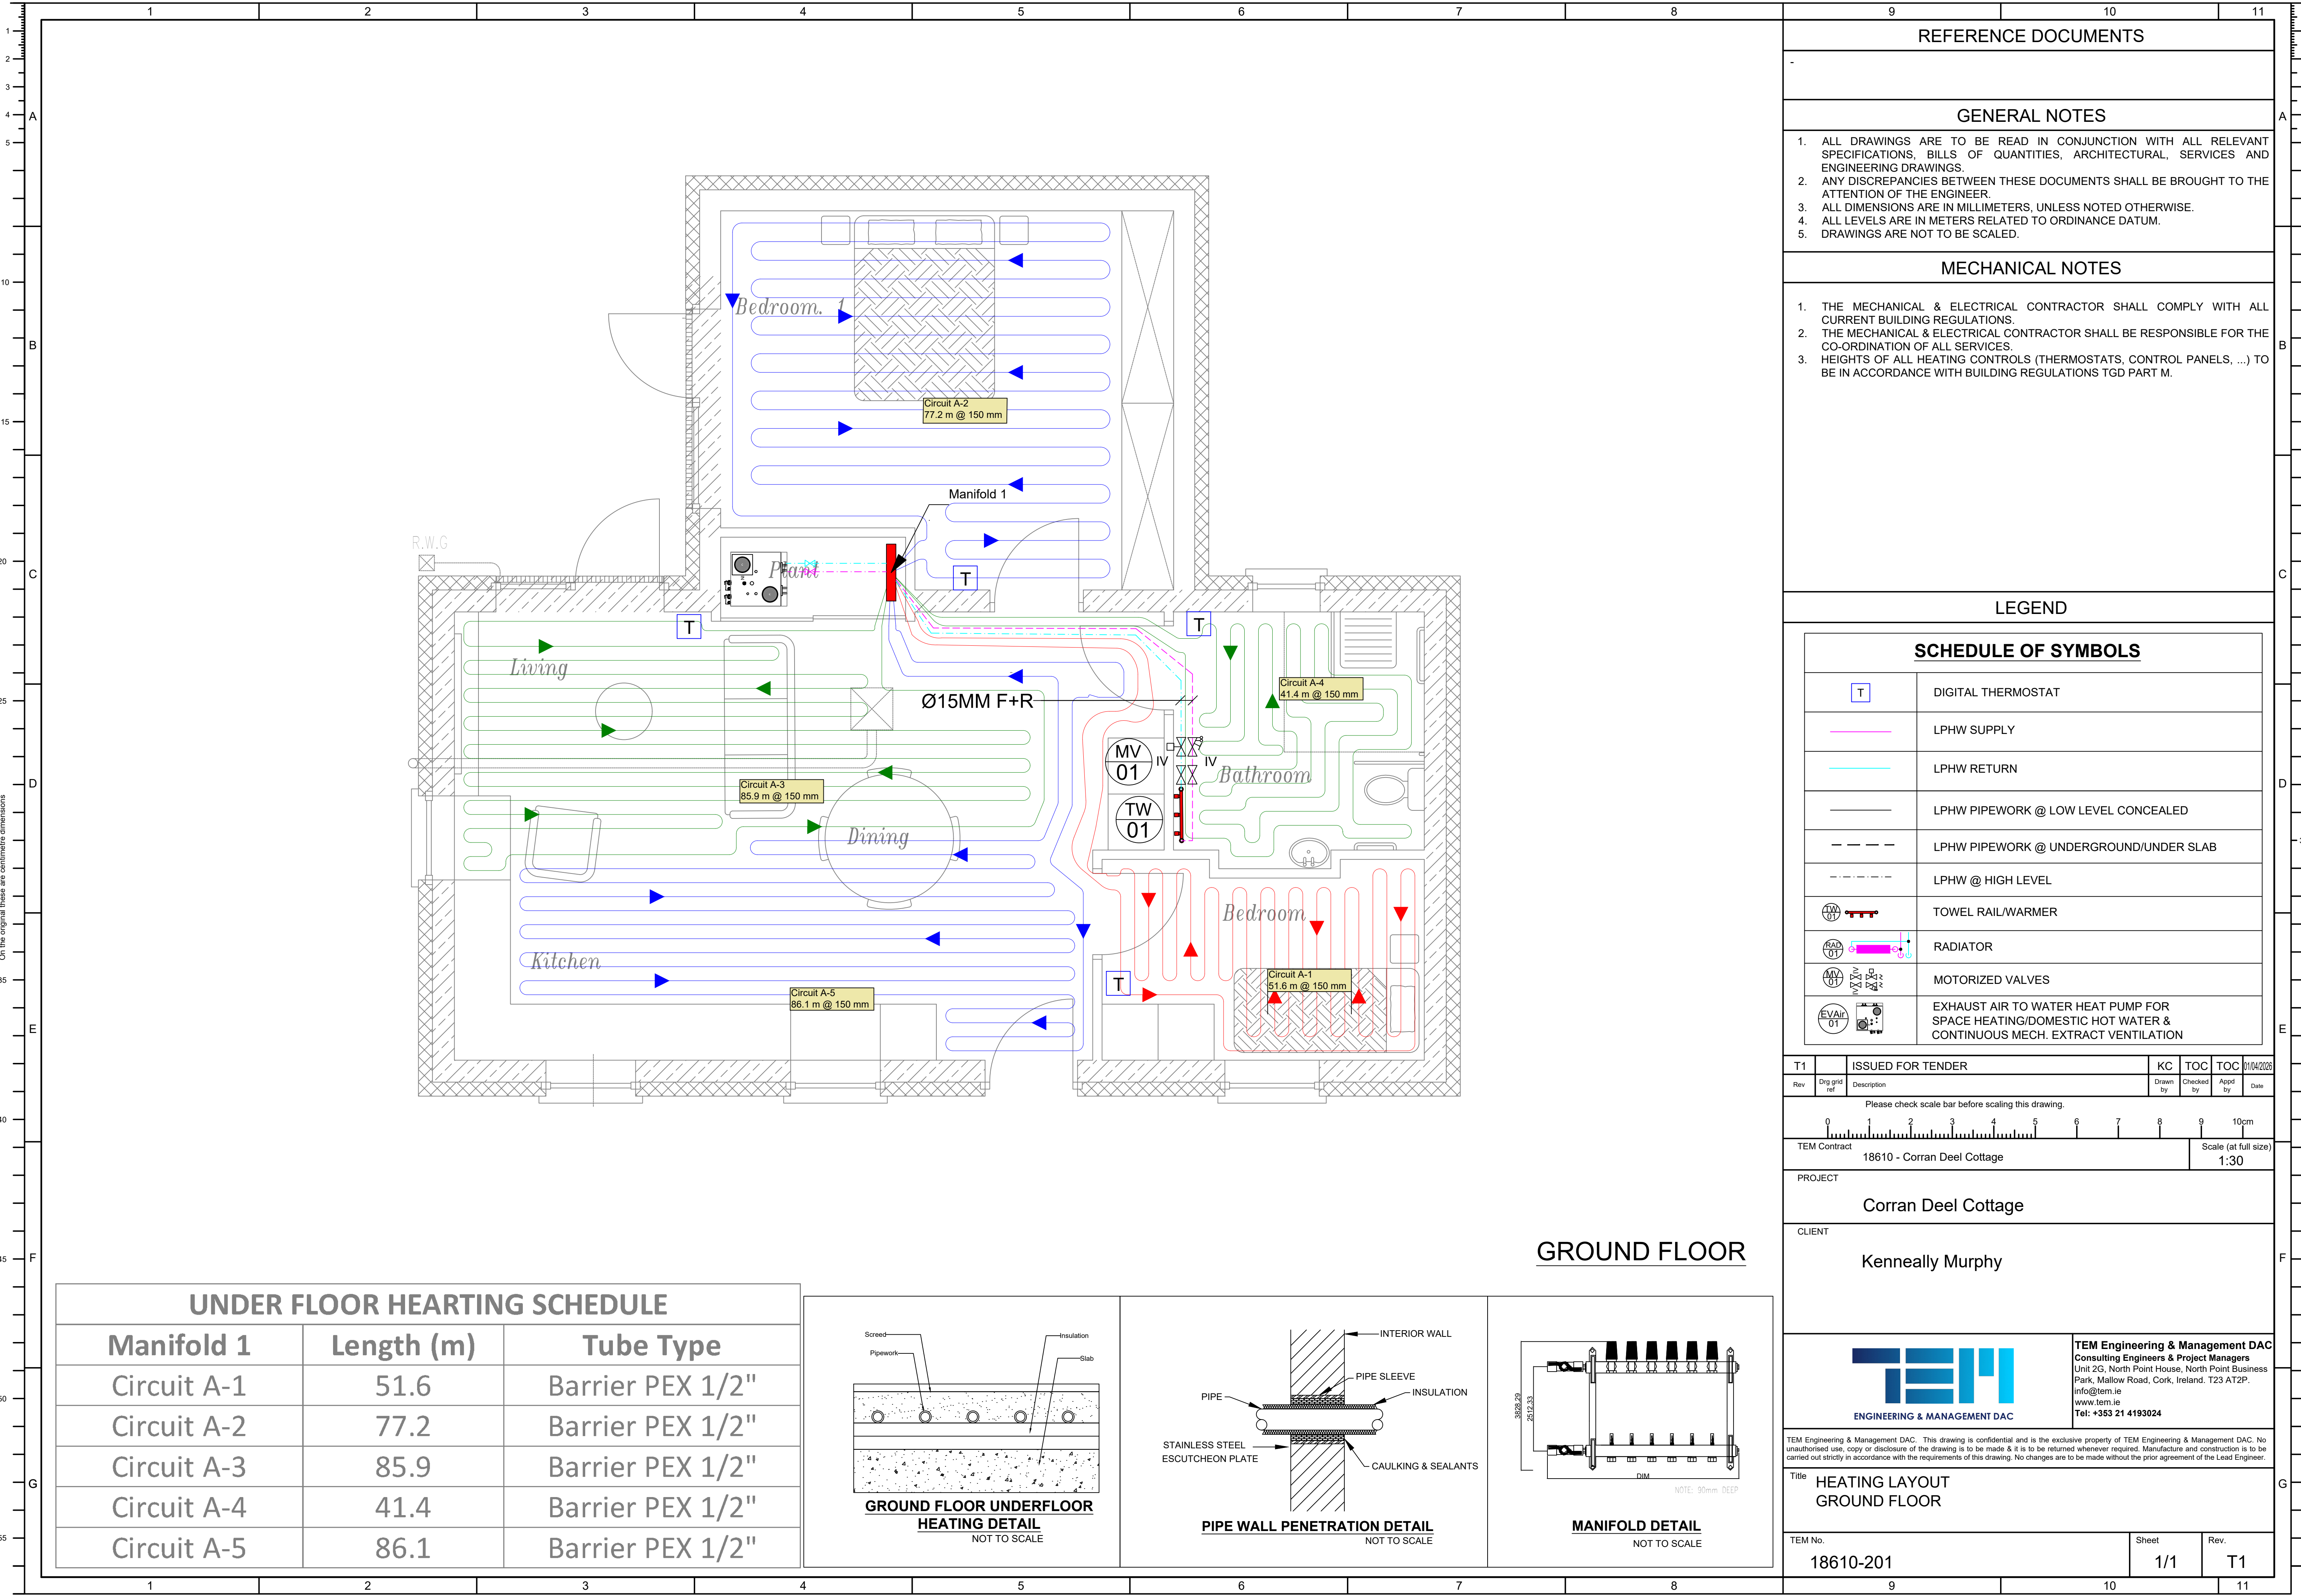

REFERENCE DOCUMENTS

GENERAL NOTES

- ALL DRAWINGS ARE TO BE READ IN CONJUNCTION WITH ALL RELEVANT SPECIFICATIONS, BILLS OF QUANTITIES, ARCHITECTURAL, SERVICES AND ENGINEERING DRAWINGS.
- ANY DISCREPANCIES BETWEEN THESE DOCUMENTS SHALL BE BROUGHT TO THE ATTENTION OF THE ENGINEER.
- ALL DIMENSIONS ARE IN MILLIMETERS, UNLESS NOTED OTHERWISE.
- ALL LEVELS ARE IN METERS RELATED TO ORDINANCE DATUM.
- DRAWINGS ARE NOT TO BE SCALED.

MECHANICAL NOTES


- THE MECHANICAL & ELECTRICAL CONTRACTOR SHALL COMPLY WITH ALL CURRENT BUILDING REGULATIONS.
- THE MECHANICAL & ELECTRICAL CONTRACTOR SHALL BE RESPONSIBLE FOR THE CO-ORDINATION OF ALL SERVICES.
- HEIGHTS OF ALL HEATING CONTROLS (THERMOSTATS, CONTROL PANELS, ...) TO BE IN ACCORDANCE WITH BUILDING REGULATIONS TGD PART M.

LEGEND

SCHEDULE OF SYMBOLS

T	DIGITAL THERMOSTAT
—	LPHW SUPPLY
—	LPHW RETURN
—	LPHW PIPEWORK @ LOW LEVEL CONCEALED
- - -	LPHW PIPEWORK @ UNDERGROUND/UNDER SLAB
—	LPHW @ HIGH LEVEL
TW 01	TOWEL RAIL/WARMER
RAD 01	RADIATOR
MV 01	MOTORIZED VALVES
EVAir 01	EXHAUST AIR TO WATER HEAT PUMP FOR SPACE HEATING/DOMESTIC HOT WATER & CONTINUOUS MECH. EXTRACT VENTILATION

T1		ISSUED FOR TENDER	KC	TOC	TOC	01/04/2025
Rev	Orig grid ref	Description	Drawn by	Checked by	Appd by	Date

 

TEM Contract	18610 - Corran Deel Cottage	Scale (at full size)	1:30
--------------	-----------------------------	----------------------	------

PROJECT	Corran Deel Cottage
---------	---------------------

CLIENT	Kenneally Murphy
--------	------------------

TEM Engineering & Management DAC
Consulting Engineers & Project Managers
Unit 2G, North Point House, North Point Business Park, Mallow Road, Cork, Ireland. T23 AT2P.
info@tem.ie
www.tem.ie
Tel: +353 21 4193024




TEM Engineering & Management DAC. This drawing is confidential and is the exclusive property of TEM Engineering & Management DAC. No unauthorised use, copy or disclosure of the drawing is to be made & it is to be returned whenever required. Manufacture and construction is to be carried out strictly in accordance with the requirements of this drawing. No changes are to be made without the prior agreement of the Lead Engineer.

Title	HEATING LAYOUT GROUND FLOOR
-------	--------------------------------

TEM No.	18610-201	Sheet	1/1	Rev.	T1
---------	-----------	-------	-----	------	----

UNDER FLOOR HEARTING SCHEDULE

Manifold 1	Length (m)	Tube Type
Circuit A-1	51.6	Barrier PEX 1/2"
Circuit A-2	77.2	Barrier PEX 1/2"
Circuit A-3	85.9	Barrier PEX 1/2"
Circuit A-4	41.4	Barrier PEX 1/2"
Circuit A-5	86.1	Barrier PEX 1/2"

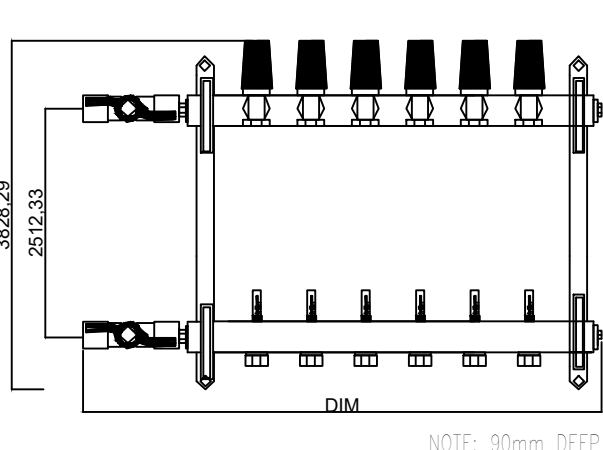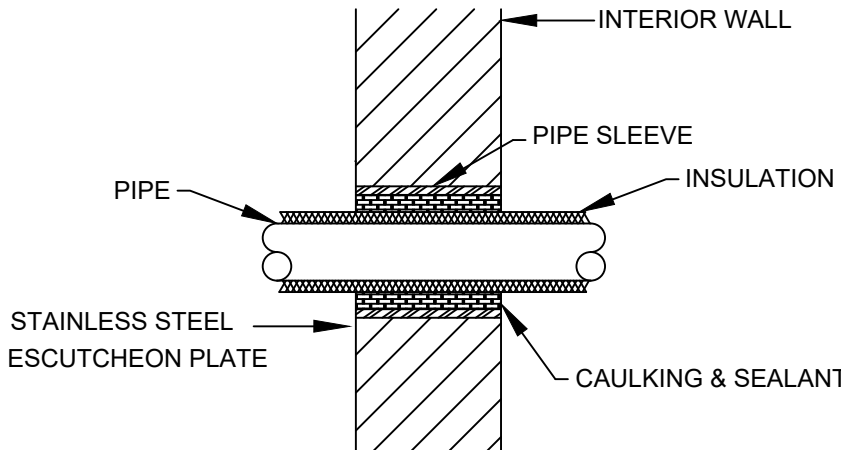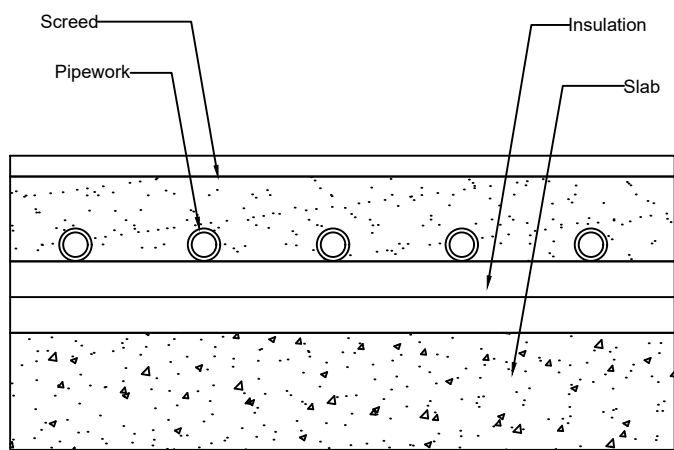

GROUND FLOOR