


LEGEND	
	RECESSED LED LIGHT, 19.5W
	Ø000MM CEILING LIGHT
	DOWNLIGHT RECESSED LED SPOTLIGHT, 10W
	IP65 RATED RECESSED LED SPOTLIGHT, 11W
	IP65 RATED BULK-HEAD LIGHT, 19.5W
	EXTERNAL WALL MOUNTED LIGHT
	ANTI PANIC EMERGENCY BULK HEAD LUMINAIRE C/W 3 HOUR BATTERY PACK- NON MAINTAINED
	BULK HEAD EXTERNAL EMERGENCY LIGHTING
	ONE WAY GANG SWITCH TO COMPLY WITH BS EN 60669-1:2000
	ONE WAY DIMMING SWITCH TO COMPLY WITH BS EN 60669-1:2000
	ONE WAY SWITCH TO COMPLY WITH BS EN 60669-1:2000 2 X 250MM, 3 X 250MM
	TWO WAY SWITCH TO COMPLY WITH BS EN 60669-1:2000
	IP65 PENDANT LIGHT 130 X 150 MM
	PENDANT LIGHT Ø750MM
	PENDANT LIGHT Ø280MM
	PENDANT LIGHT Ø730MM
	PENDANT LIGHT Ø300MM
	WALL LIGHT 145 X 260 MM
	WALL LIGHT 240 X 560 MM
	WALL BRACKET LIGHT 145 X 260 MM
	WALL BRACKET LIGHT 150 X 150 MM
	WALL BRACKET LIGHT 80 X 115 MM
	UPLIGHT 4W
	STAIRS LIGHT 35 X 43 MM
	FLUSH MOUNTED LIGHT Ø203 MM
	FLUSH MOUNTED LIGHT 85 X 100 MM
	CEILING LIGHT Ø1000 MM

LEGEND	
 A	RECESSED LED DOWNLIGHT, 2000LM
 B	RECESSED LED SPOTLIGHT, 850LM
 C1	RECESSED LED SPOTLIGHT, IP65, 1200LM
 C2	RECESSED LED SPOTLIGHT, IP65, 3200LM
 C3	SAUNA LIGHTING BY SPECIALIST
 D	RECESSED LED DOWNLIGHT, 3200LM
 F1	1200MM IP65 LED LUMINAIRE, 3400LM
 P	PENDANT LED LIGHT
 K	STANDARD PENDANT LED LIGHT, 11W
 W1	WALL BRACKET LIGHT
 W2	DIMMABLE WALL BRACKET LIGHT
 DS	STAIRS LIGHT
 M	MIRROR LIGHT
 WxW	EXTERNAL WALL MOUNTED LIGHT
 EM1	ANTI PANIC EMERGENCY BULK HEAD LUMINAIRE C/W 3 HOUR BATTERY PACK- NON MAINTAINED
 EM2	BULK HEAD EXTERNAL EMERGENCY LIGHTING
	ONE WAY, ONE GANG SWITCH TO COMPLY WITH BS EN 60669-1:2000
	ONE WAY DIMMING SWITCH TO COMPLY WITH BS EN 60669-1:2000
	ONE WAY, SWITCH TO COMPLY WITH BS EN 60669-1:2000 2 = 2GANG, 3 = 3GANG
	TWO WAY SWITCH TO COMPLY WITH BS EN 60669-1:2000

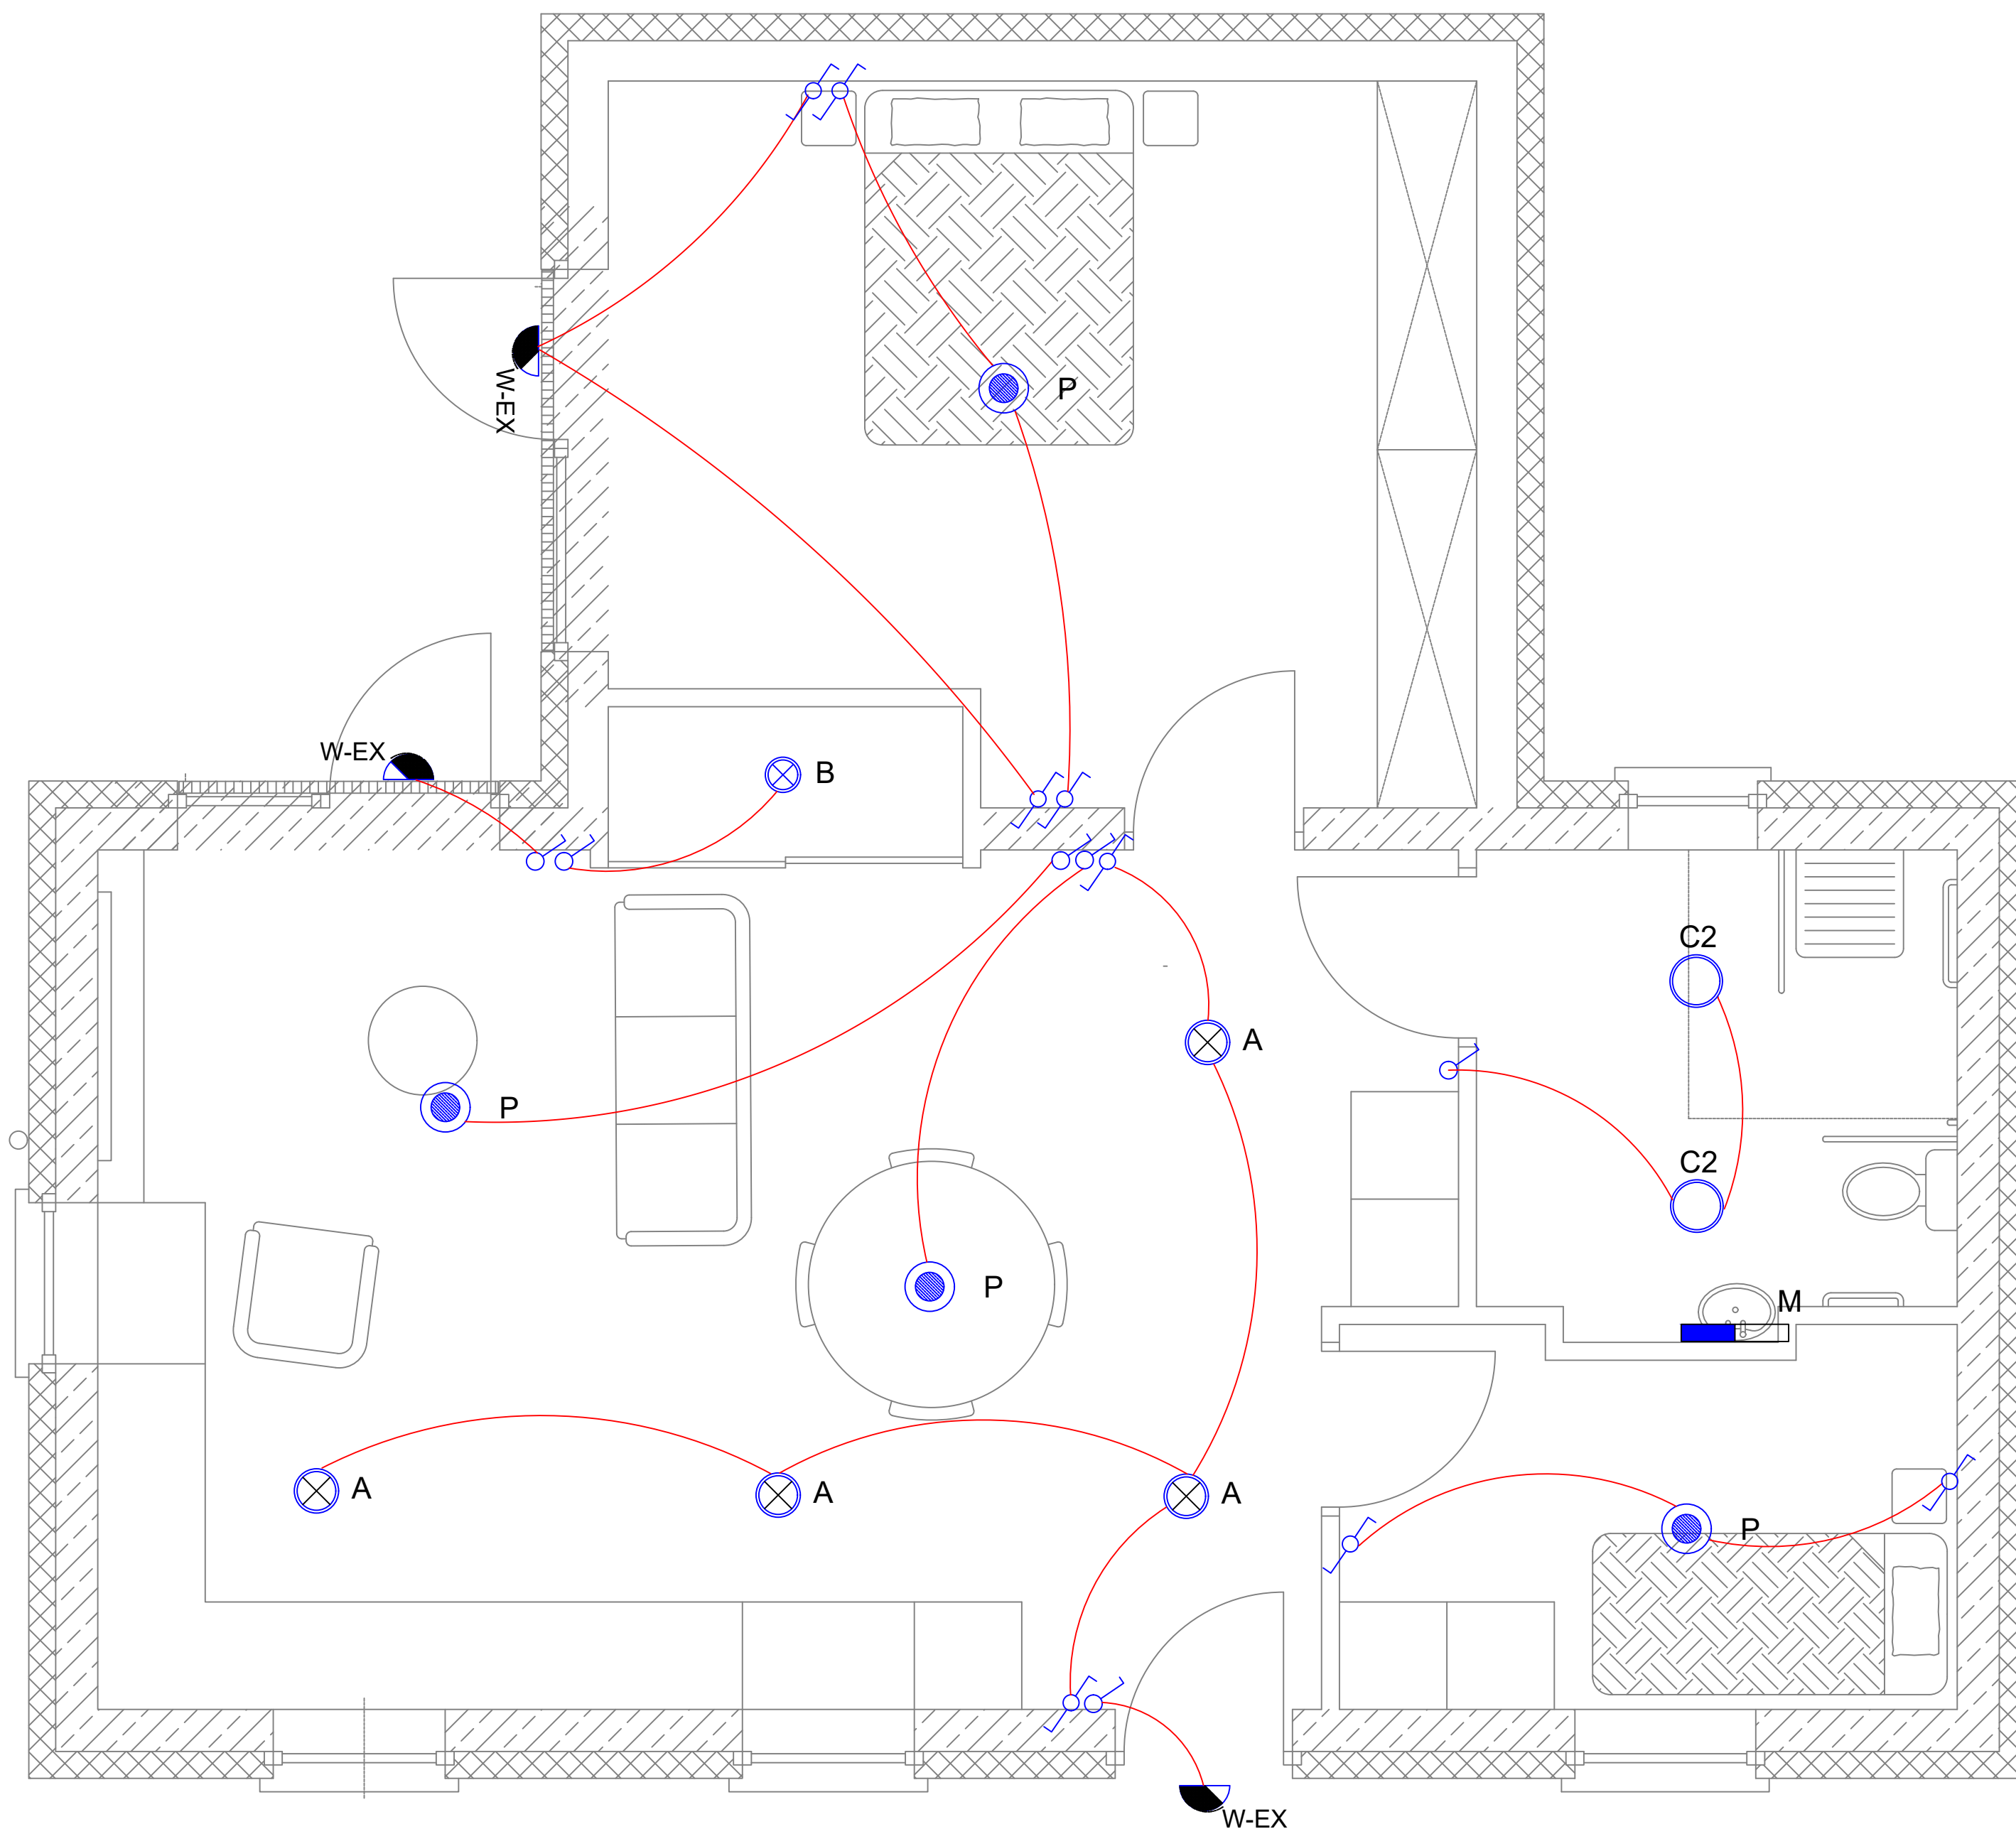

GROUND FLOOR

REFERENCE DOCUMENTS

GENERAL NOTES

- | | |
|----|---|
| 1. | ALL DRAWINGS ARE TO BE READ IN CONJUNCTION WITH ALL RELEVANT SPECIFICATIONS, BILLS OF QUANTITIES, ARCHITECTURAL, SERVICES AND ENGINEERING DRAWINGS. |
| 2. | ANY DISCREPANCIES BETWEEN THESE DOCUMENTS SHALL BE BROUGHT TO THE ATTENTION OF THE ENGINEER. |
| 3. | ALL DIMENSIONS ARE IN MILLIMETRES, UNLESS NOTED OTHERWISE. |
| 4. | ALL LEVELS ARE IN METRES RELATED TO ORDINANCE DATUM. |
| 5. | DRAWINGS ARE NOT TO BE SCALED. |
| 6. | THE MECHANICAL & ELECTRICAL CONTRACTOR SHALL COMPLY WITH ALL CURRENT BUILDING REGULATIONS. |
| 7. | THE MECHANICAL & ELECTRICAL CONTRACTOR SHALL BE RESPONSIBLE FOR THE CO-ORDINATION OF ALL SERVICES. |
| 8. | INSTALLATION TO BE CARRIED OUT IN ACCORDANCE WITH BUILDING REGULATIONS. |
| 9. | HEIGHTS OF ALL ELEMENTS TO BE IN ACCORDANCE WITH BUILDING REGULATIONS TGD PART M. |

ELECTRICAL NOTES


- | | | |
|----|---|--|
| 1. | THE INSTALLATION SHALL COMPLY WITH NATIONAL RULES FOR ELECTRICAL INSTALLATIONS, FIFTH EDITION, IS 10101:2020 AND ALL AMENDMENTS. | |
| 2. | THE MECHANICAL & ELECTRICAL CONTRACTOR SHALL COMPLY WITH ALL CURRENT BUILDING REGULATIONS. | |
| 3. | THE MECHANICAL & ELECTRICAL CONTRACTOR SHALL BE RESPONSIBLE FOR THE CO-ORDINATION OF ALL SERVICES. | |
| 4. | ALL LIGHT FITTINGS TO USE L.E.D. LAMPS IN ACCORDANCE WITH BUILDING REGULATIONS TGD PART L. | |
| 5. | IN ACCORDANCE WITH THE REQUIREMENTS OF PART M OF THE BUILDING REGULATIONS THE FOLLOWING HEIGHTS TO BE APPLIED TO ALL ACCESSORIES: | |
| | - LIGHT SWITCHES - 1050 mm; | |
| | - SOCKET OUTLETS (INTERNAL & EXTERNAL) - 450 mm; | |
| | - ABOVE COUNTER SOCKETS AND SWITCHES - 1050 mm; | |
| | - DOOR BELL - 1050 mm; | |
| | - THERMOSTATS - 1500 mm. | |

LIGHTING NOTES

1. ALL SERVICES WITHIN THE EXTENSION TO BE FLUSH GALVANIZED CONDUIT RUNS.
2. GALVANIZED STEEL TRUNKING TO ENCLOSE MULTIPLE RUNS OF CABLE.
3. ALL SOCKETS AND SWITCHES TO BE ROBUST AND DURABLE IN QUALITY.
4. ALL ELECTRICAL WORKS ARE TO BE PRICED IN ACCORDANCE WITH ALL M&E DRAWINGS AND DOCUMENTATION.
5. THE CONTRACTOR SHALL PROVIDE SAMPLES OF ALL LIGHT FITTINGS AND ACCESSORIES TO THE ARCHITECT FOR APPROVAL PRIOR TO ORDERING.
6. THE LIGHTING INSTALLATION WILL CONSIST OF MANUAL ON/OFF CONTROLS AND TWO WAY SWITCHING, MANUAL DIMMING, AUTOMATIC LIGHTING CONTROLS, ABSENCE DETECTION, AND DAYLIGHT SENSING.
7. LIGHTING SWITCHES IN STORES SHALL BE PUSH TYPE C/W AUTOMATIC TIME DELAY RELEASE.
8. EXTERNAL BUILDING MOUNTED LIGHTING SHALL BE CONTROLLED BY TIMECLOCK & PHOTOCELL.

T1		ISSUED FOR TENDER	KC	TOC	TOC	07/04/2026
Rev	Drg grid ref	Description	Drawn bv	Checked bv	Appd bv	Date

 Please check scale bar before scaling this drawing.



TEM Contract 18610 - Corran Deel Cottage	Scale (at full size) 1:30
---	------------------------------

PROJECT	Corran Deel Cottage, Co. Limerick
---------	-----------------------------------

CLIENT **Kenneally Murphy**



TEM Engineering & Management DAC
Consulting Engineers & Project Managers
 Unit 2G, North Point House, North Point Business
 Park, Mallow Road, Cork, Ireland. T23 AT2P.
info@tem.ie
www.tem.ie
Tel: +353 21 4193024

TEM Engineering & Management DAC. This drawing is confidential and is the exclusive property of TEM Engineering & Management DAC. No unauthorised use, copy or disclosure of the drawing is to be made & it is to be returned whenever required. Manufacture and construction is to be carried out strictly in accordance with the requirements of this drawing. No changes are to be made without the prior agreement of the Lead Engineer.

Title	GENERAL & EMERGENCY LIGHTING LAYOUT
-------	-------------------------------------

TEM No.	Sheet	Rev.
18574-301	1 / 1	T1