


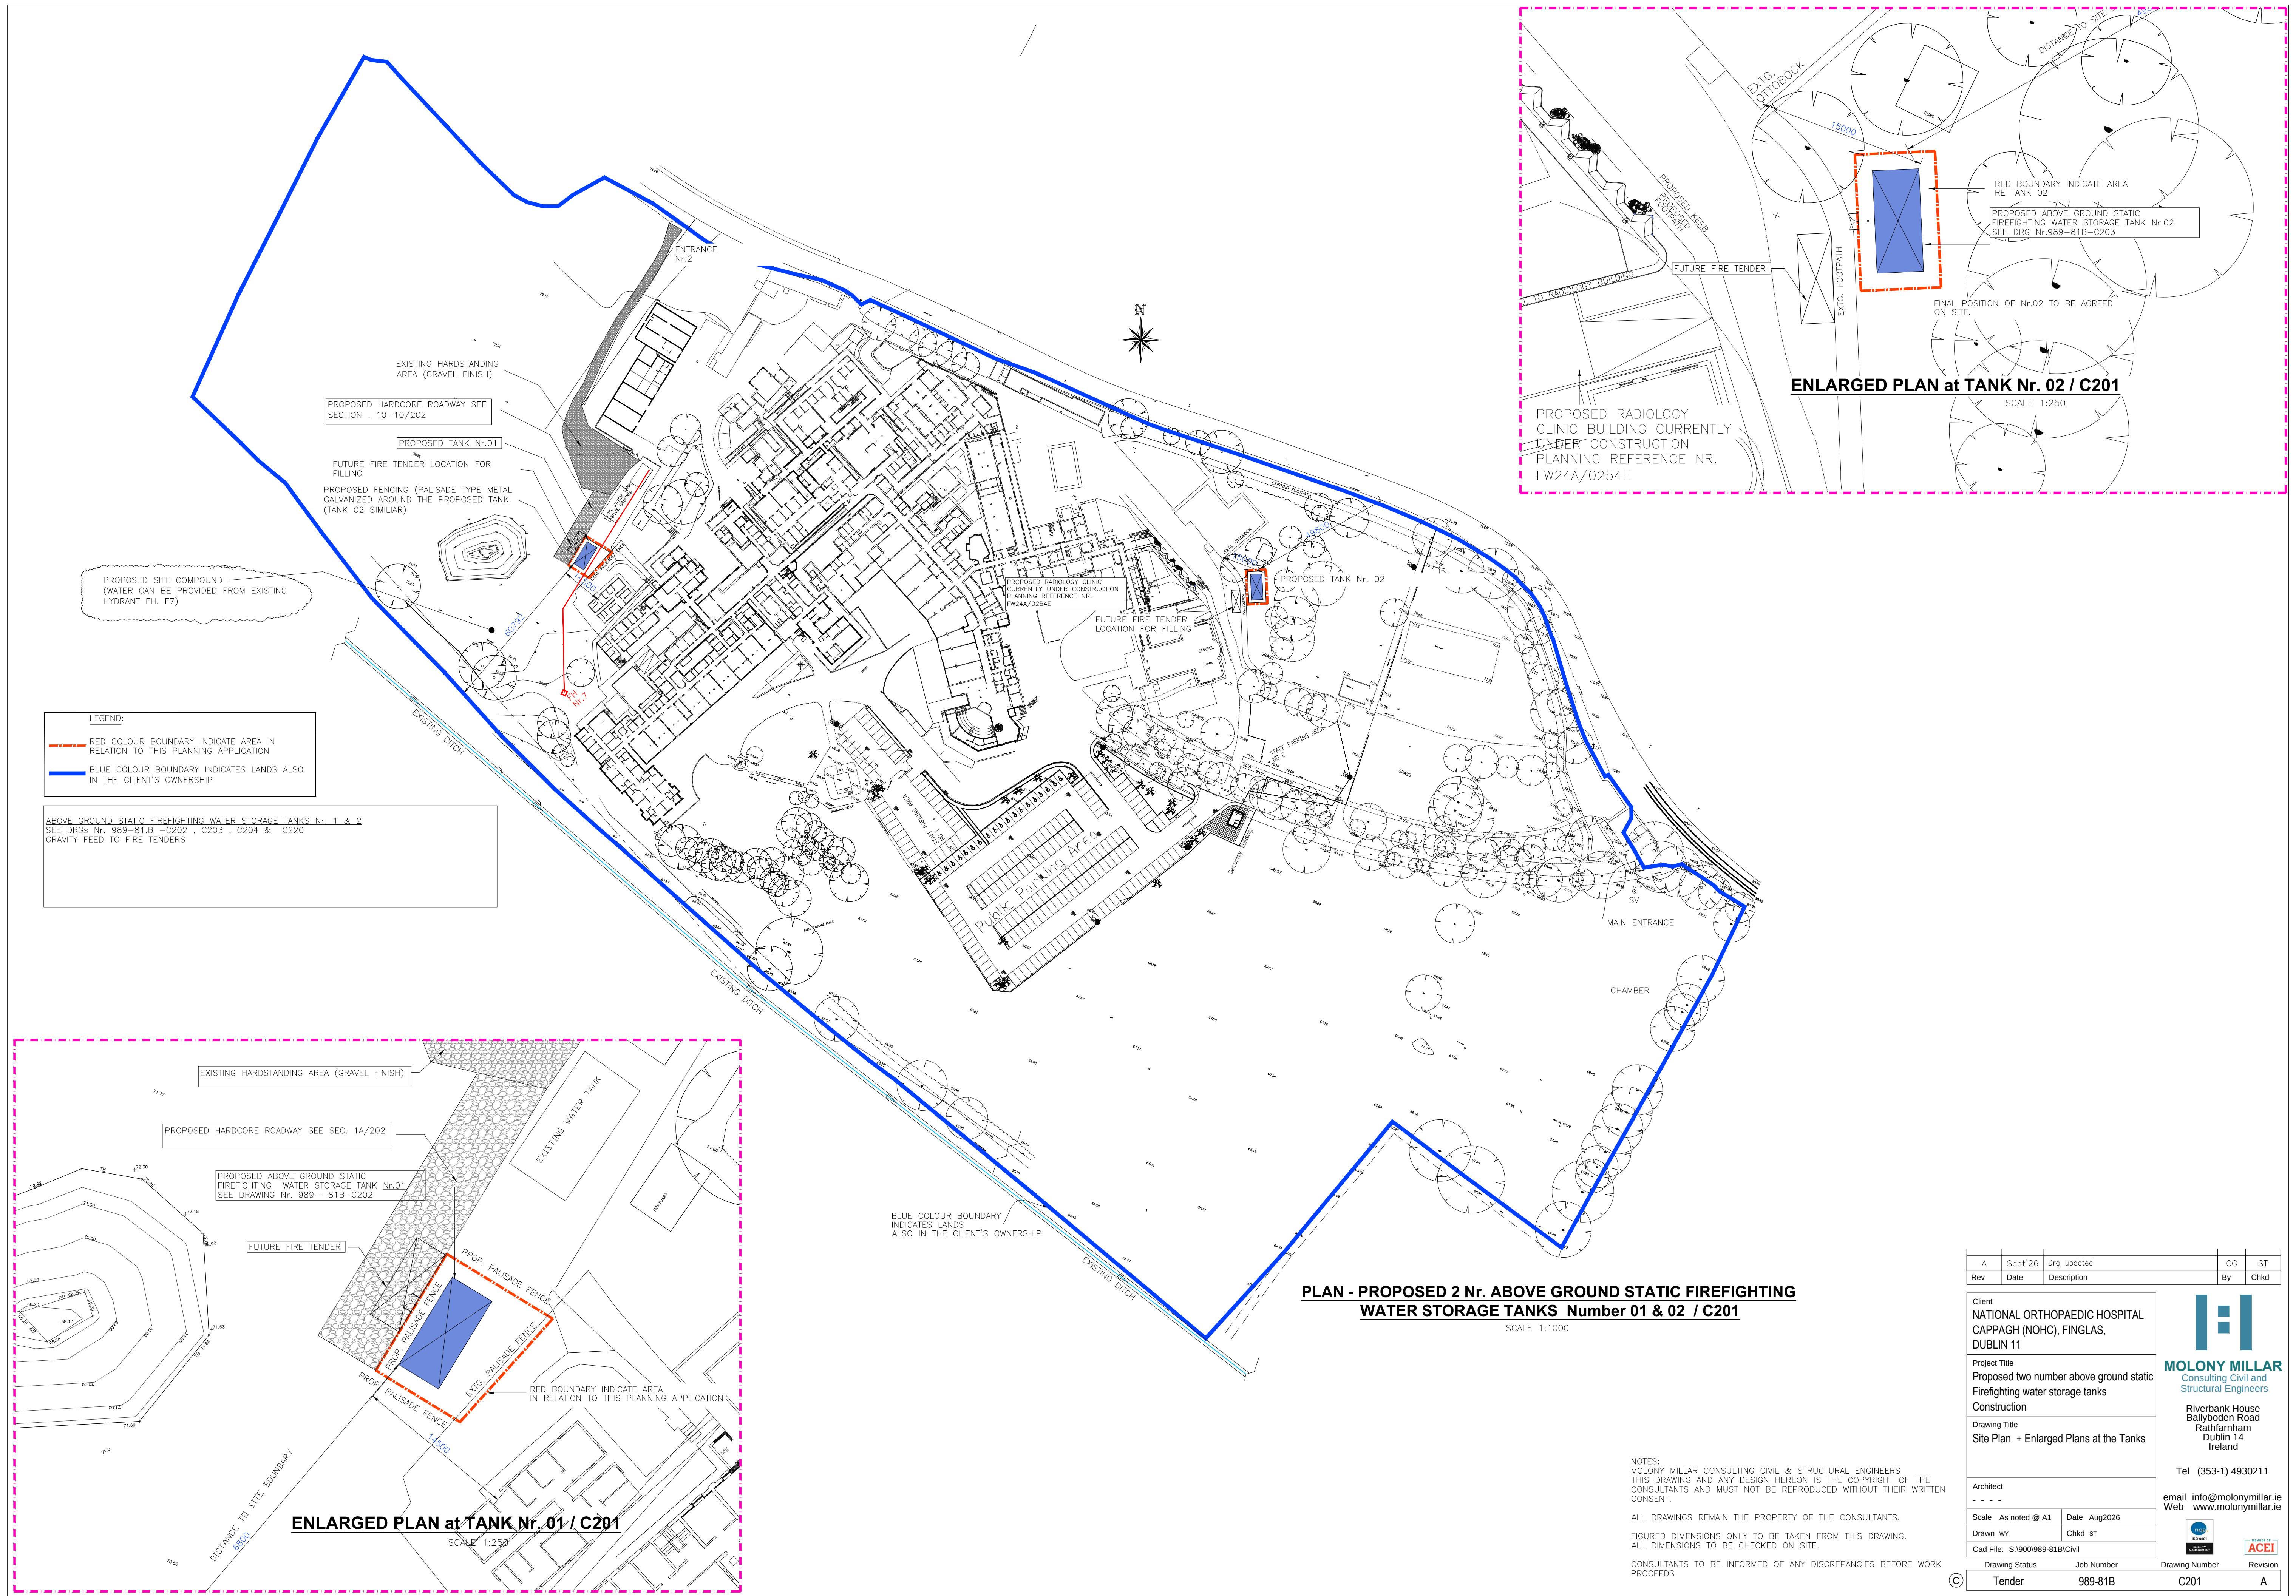

A	Sept'26	Drg updated	CG	ST
Rev	Date	Description	By	Chkd
Client NATIONAL ORTHOPAEDIC HOSPITAL CAPPAGH (NOHC), FINGLAS, DUBLIN 11 Project Title Proposed two number above ground static Firefighting water storage tanks Construction Drawing Title Site Plan + Enlarged Plans at the Tanks Architect - - - Scale As noted @ A1 Drawn wv Cad File S:\900\989-81B\Civil Drawing Status Tender Job Number 989-81B Drawing Number C201 Revision A				
MOLONY MILLAR Consulting Civil and Structural Engineers Riverbank House Ballyboden Road Rathfarnham Dublin 14 Ireland Tel (353-1) 4930211 email info@molonymillar.ie Web www.molonymillar.ie  				