



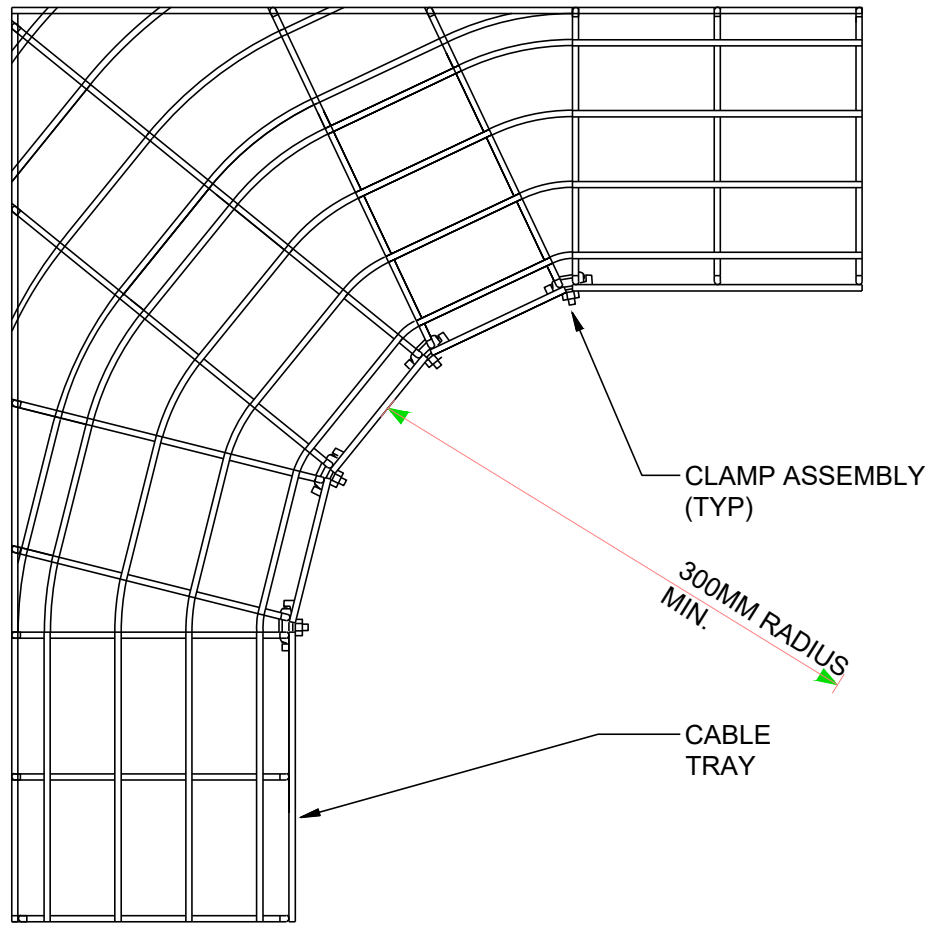


- NOTES:
1. REFER TO MANUFACTURER INSTALLATION PROCEDURES FOR FIELD ASSEMBLY INSTRUCTIONS.
 2. CABLE TRAY ASSEMBLIES MAY DIFFER BY MANUFACTURER. SHOWN HERE AS EXAMPLE.

1 CABLE TRAY - 90-DEGREE BEND
N.T.S.

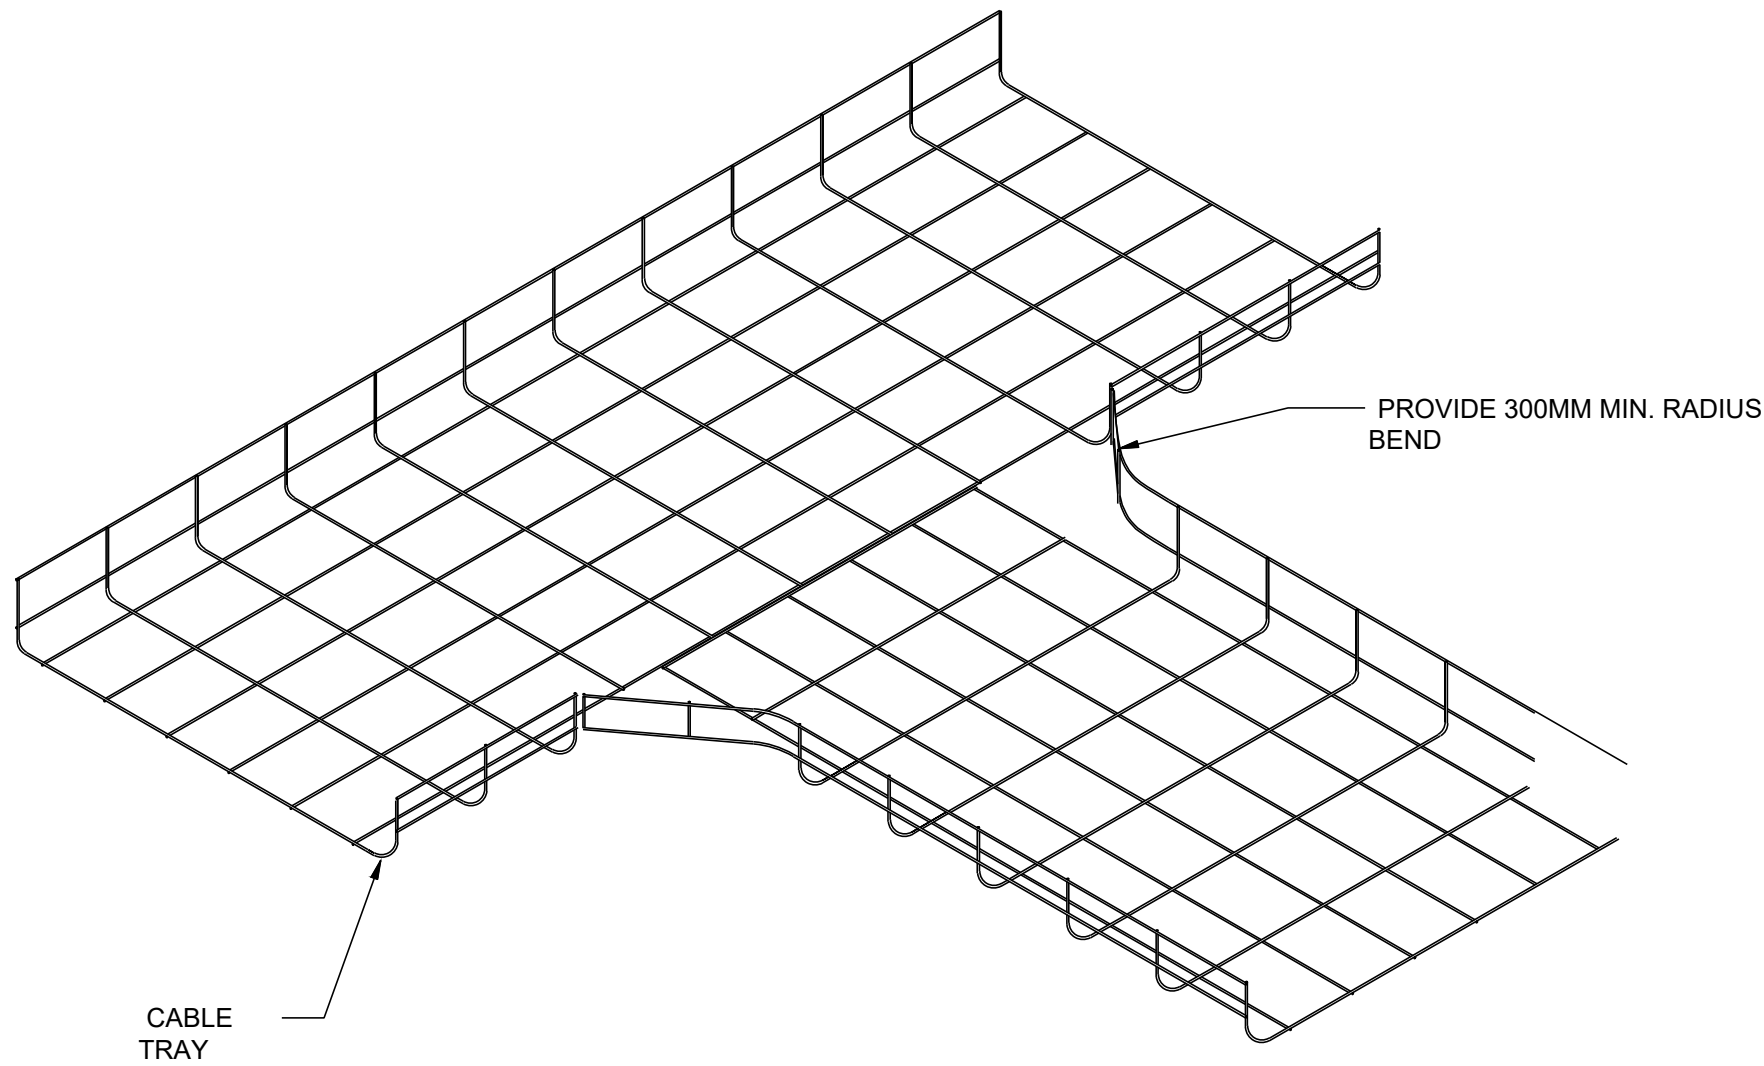


- NOTES:
1. REFER TO MANUFACTURER INSTALLATION PROCEDURES FOR FIELD ASSEMBLY INSTRUCTIONS.

2 CABLE TRAY - TEE INTERSECTION
N.T.S.

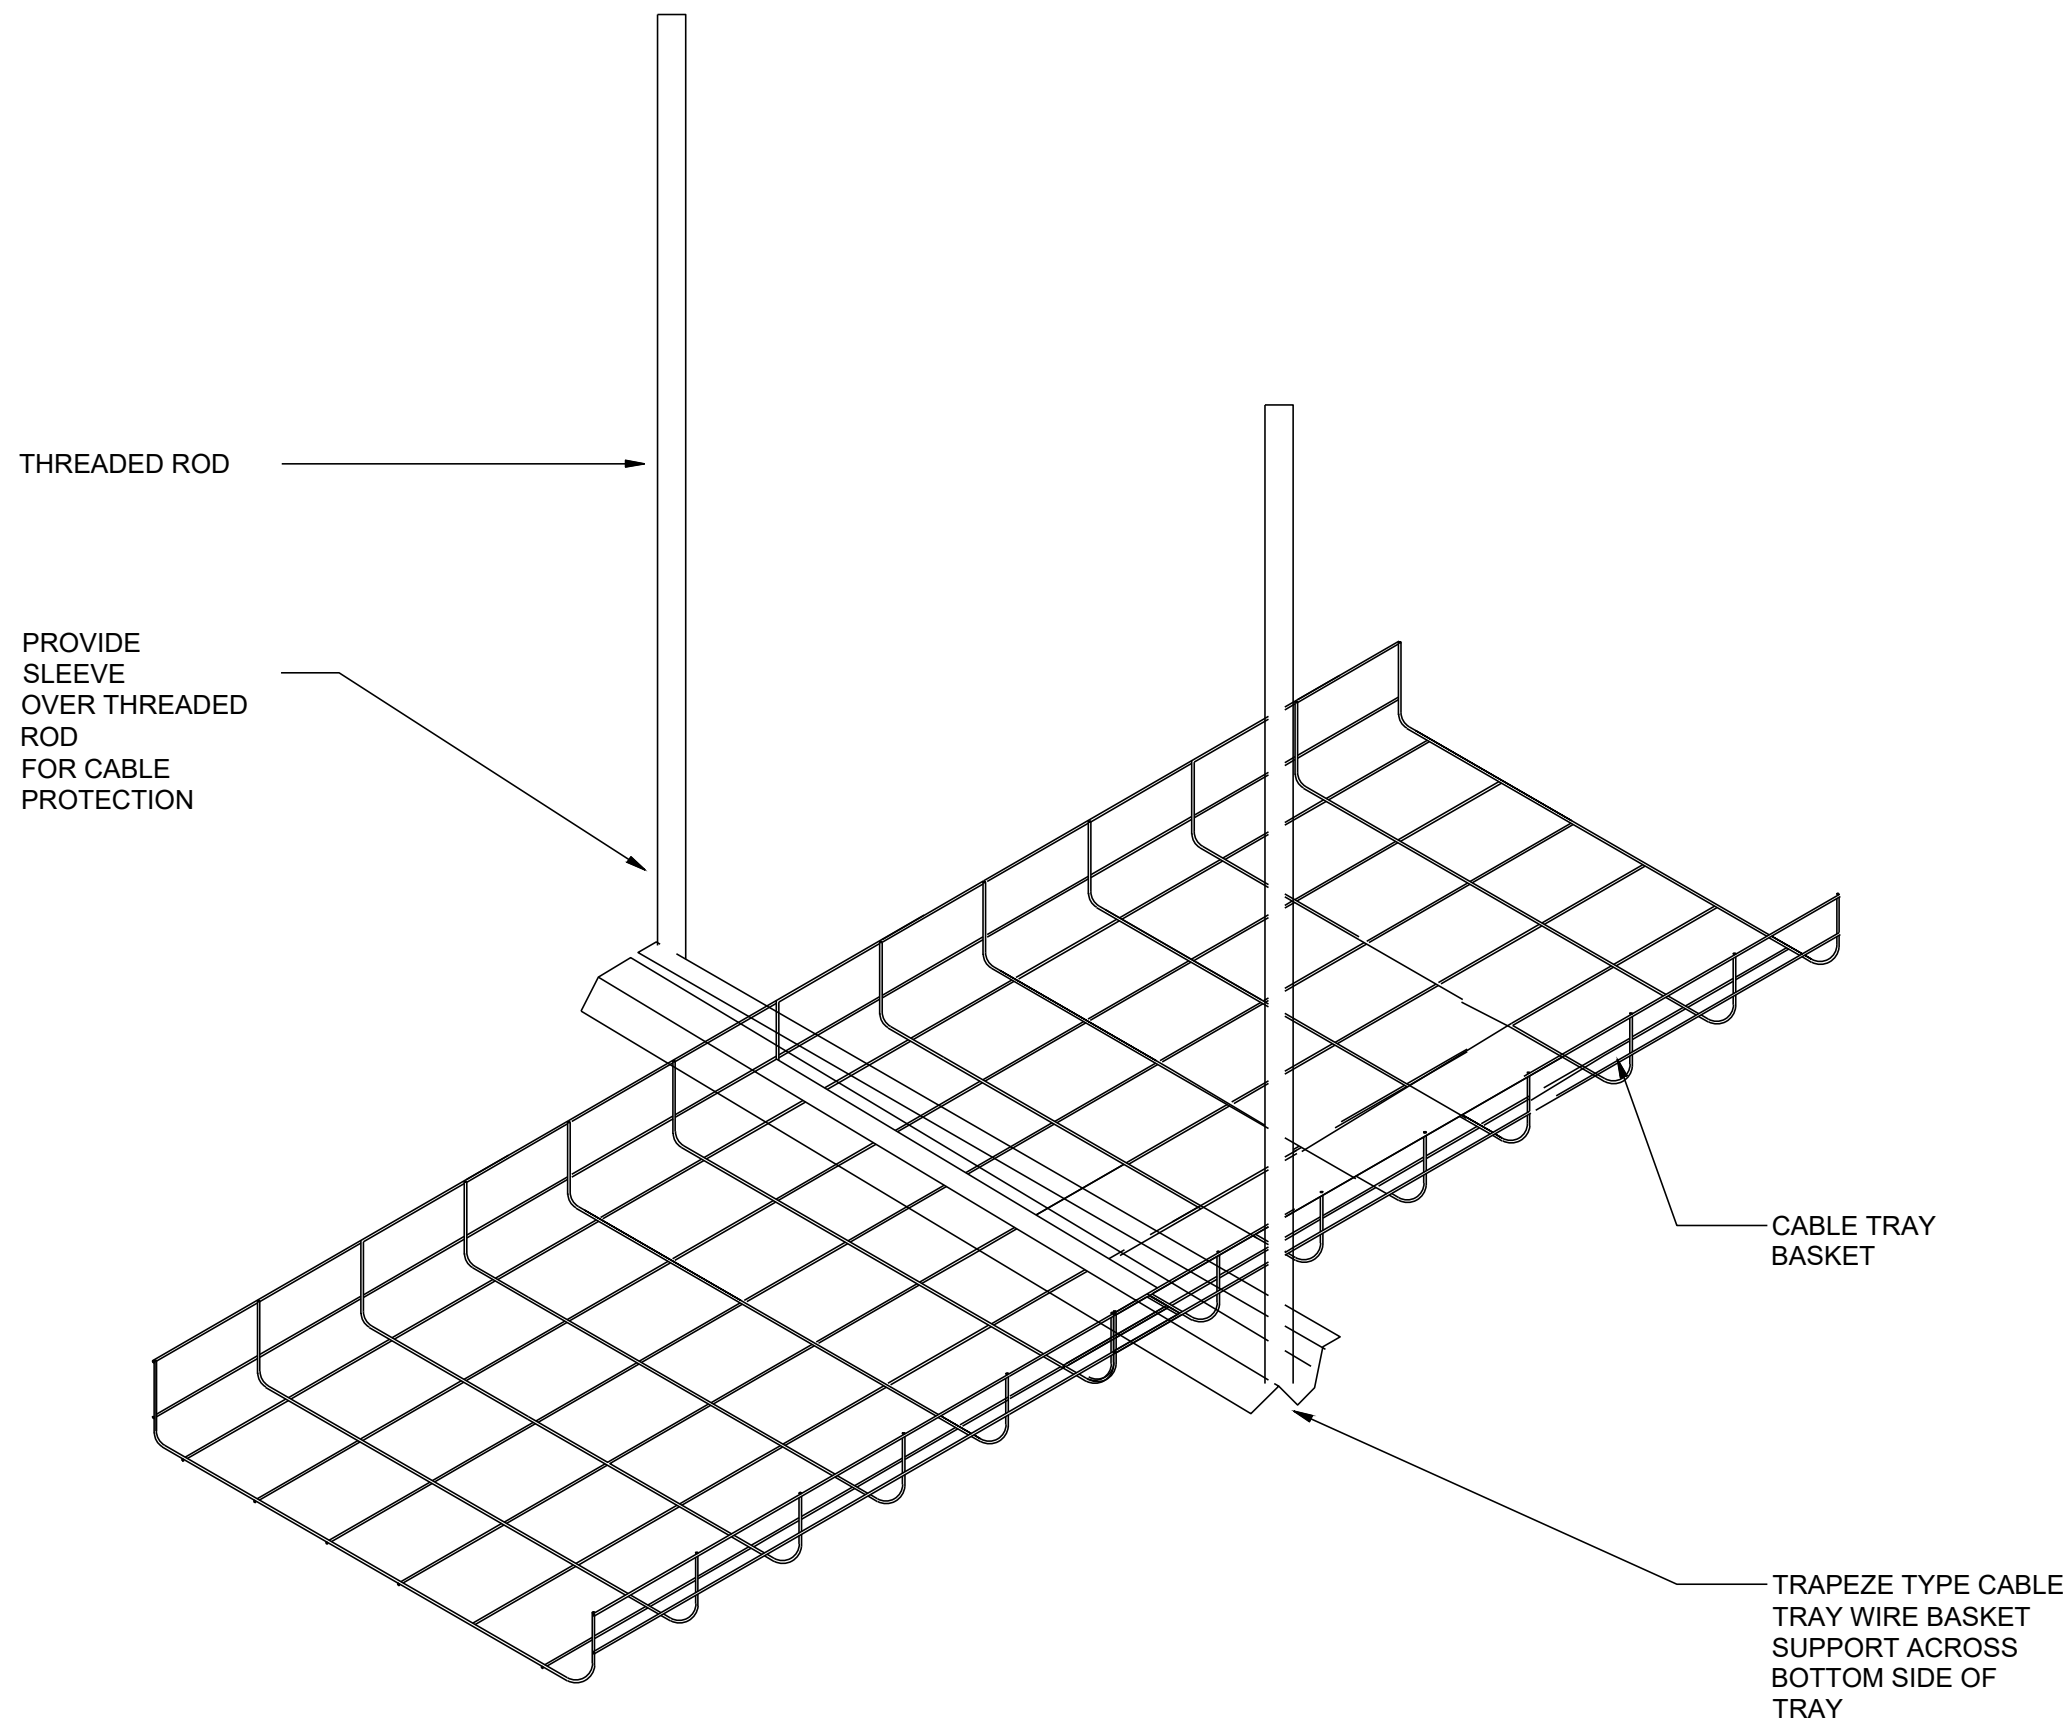

4 TRAPEZE MOUNT
N.T.S.

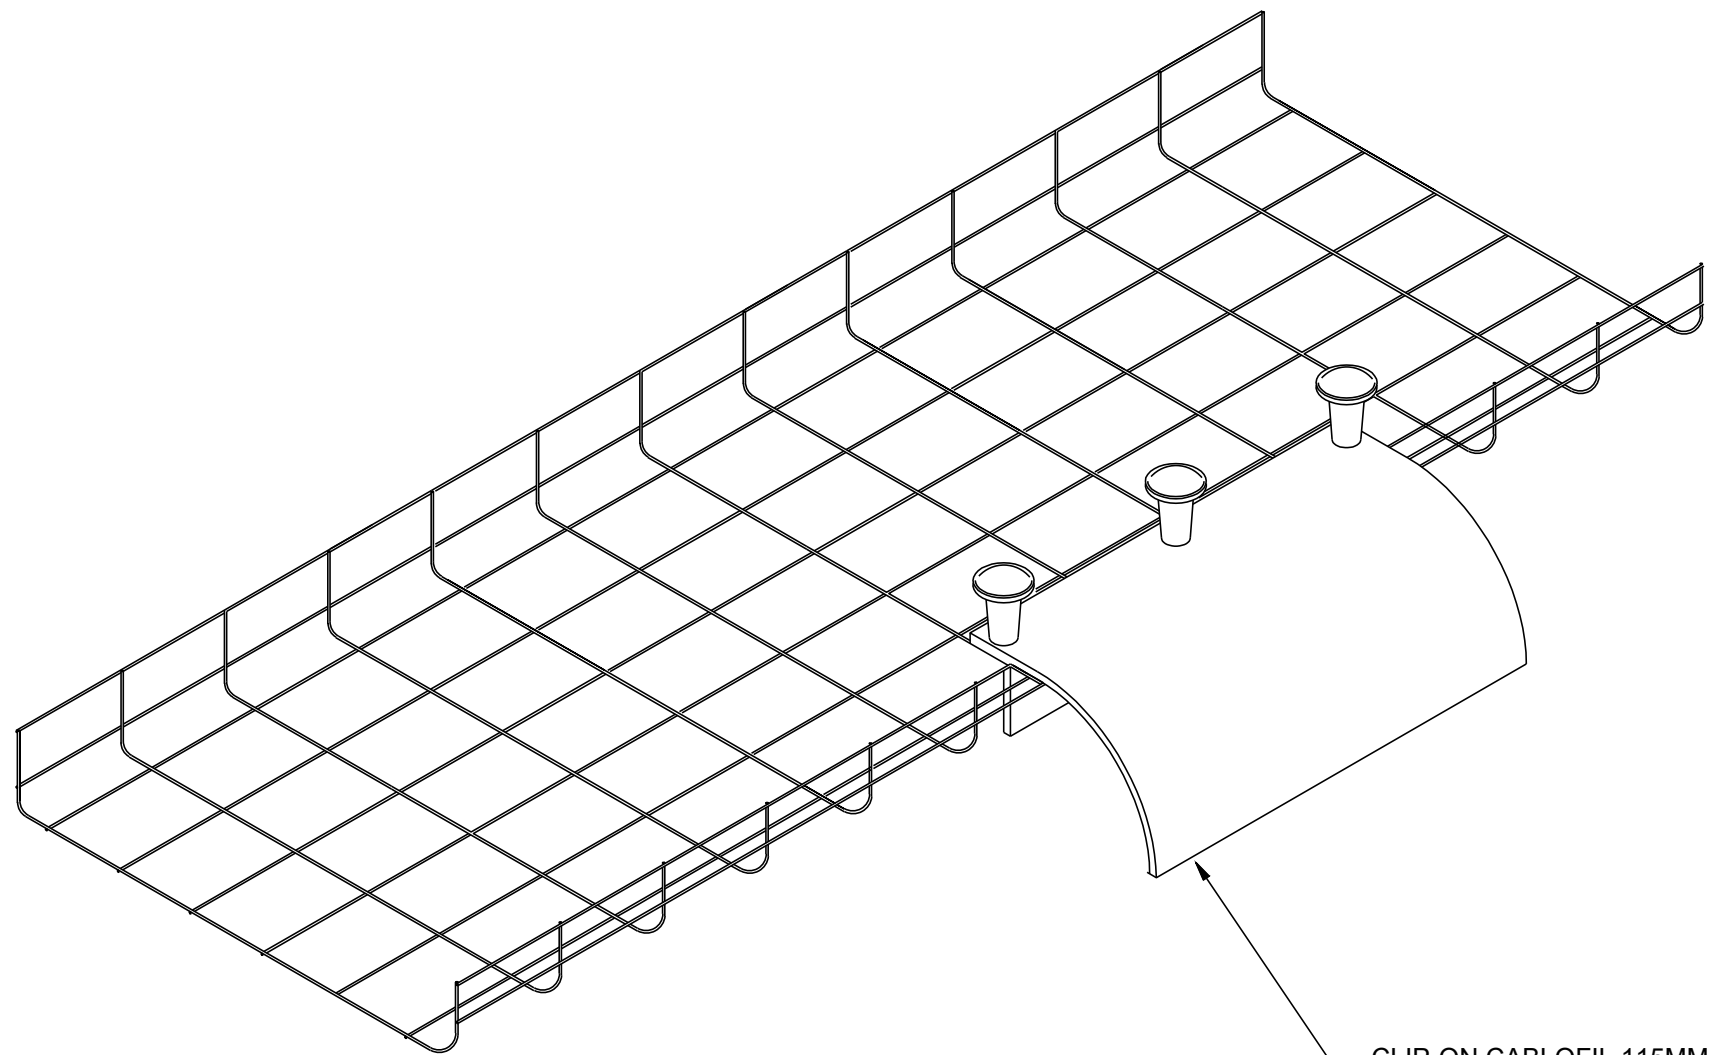

- NOTES:
1. REFER TO MANUFACTURER INSTALLATION PROCEDURES FOR FIELD ASSEMBLY INSTRUCTIONS.

3 CABLE TRAY - DROP OUT
N.T.S.

GENERAL NOTES

- DO NOT SCALE FROM THIS DRAWING.
- THE CONTRACTOR MUST VERIFY ALL DIMENSIONS TOLERANCES AND REFERENCES BEFORE PROCEEDING WITH WORKS.
- ANY DISCREPANCY FOUND BETWEEN THIS DRAWING AND ANY OTHER DOCUMENTS MUST BE REPORTED IMMEDIATELY TO THE CONTRACT ADMINISTRATOR.
- REMOVE THIS DRAWING FROM CURRENCY WHEN REVISED DRAWING IS ISSUED.
- COPYRIGHT OF DESIGNS SHOWN ON THIS DRAWING REMAINS WITH INTROBA
- THIS DRAWING IS TO BE READ IN CONJUNCTION WITH THE SPECIFICATION AND ALL OTHER CONTRACT PROJECT DOCUMENTS.
- NEW 200A COPPER BUS AND CUBICLE SHALL BE ADDED TO THE EXISTING SWITCHGEAR. SWITCHGEAR SHALL BE RECERTIFIED ONCE MODIFICATIONS ARE COMPLETE.
- SHUTDOWN ON SYSTEM SHALL BE AFTER HOURS WHEN BUILDING IS UNOCCUPIED. CLOSE COORDINATION IS REQUIRED WITH THE CLIENT TO SCHEDULE SHUTDOWN. MODIFICATIONS ARE PENDING DISCUSSIONS WITH SPECIALIST CONTRACTOR.
- ELECTRICAL ONE LINE DIAGRAM PROVIDED BY OTHERS. EQUIPMENT SHOWN IN BLACK LINES ARE DESIGN BY INTROBA, GREY IS EXISTING.

A1 ORIGINAL SIZE DRAWING

02	STAGE 4 ISSUED FOR TENDER	JM	28/08/26
01	STAGE 2b FOR REVIEW	JM	17/07/26
No:	REVISION	CHK	DATE



INTROBA IRELAND LTD
CATHEDRAL COURT
NEW ST SOUTH
THE LIBERTIES
DUBLIN 8
D08 C525



PROJECT

RSTC DUNDALK

TITLE

ELECTRICAL DETAILS

DATE	28.08.2026	SCALE	AS NOTED
DESIGNED	JP	CHECKED	JM
SUITABILITY CODE	STAGE 4		
DRAWING STATUS	STAGE 4		

DRAWING No.	10005-IRB-XX-GF-D-E-62-01	REVISION	
-------------	---------------------------	----------	--