


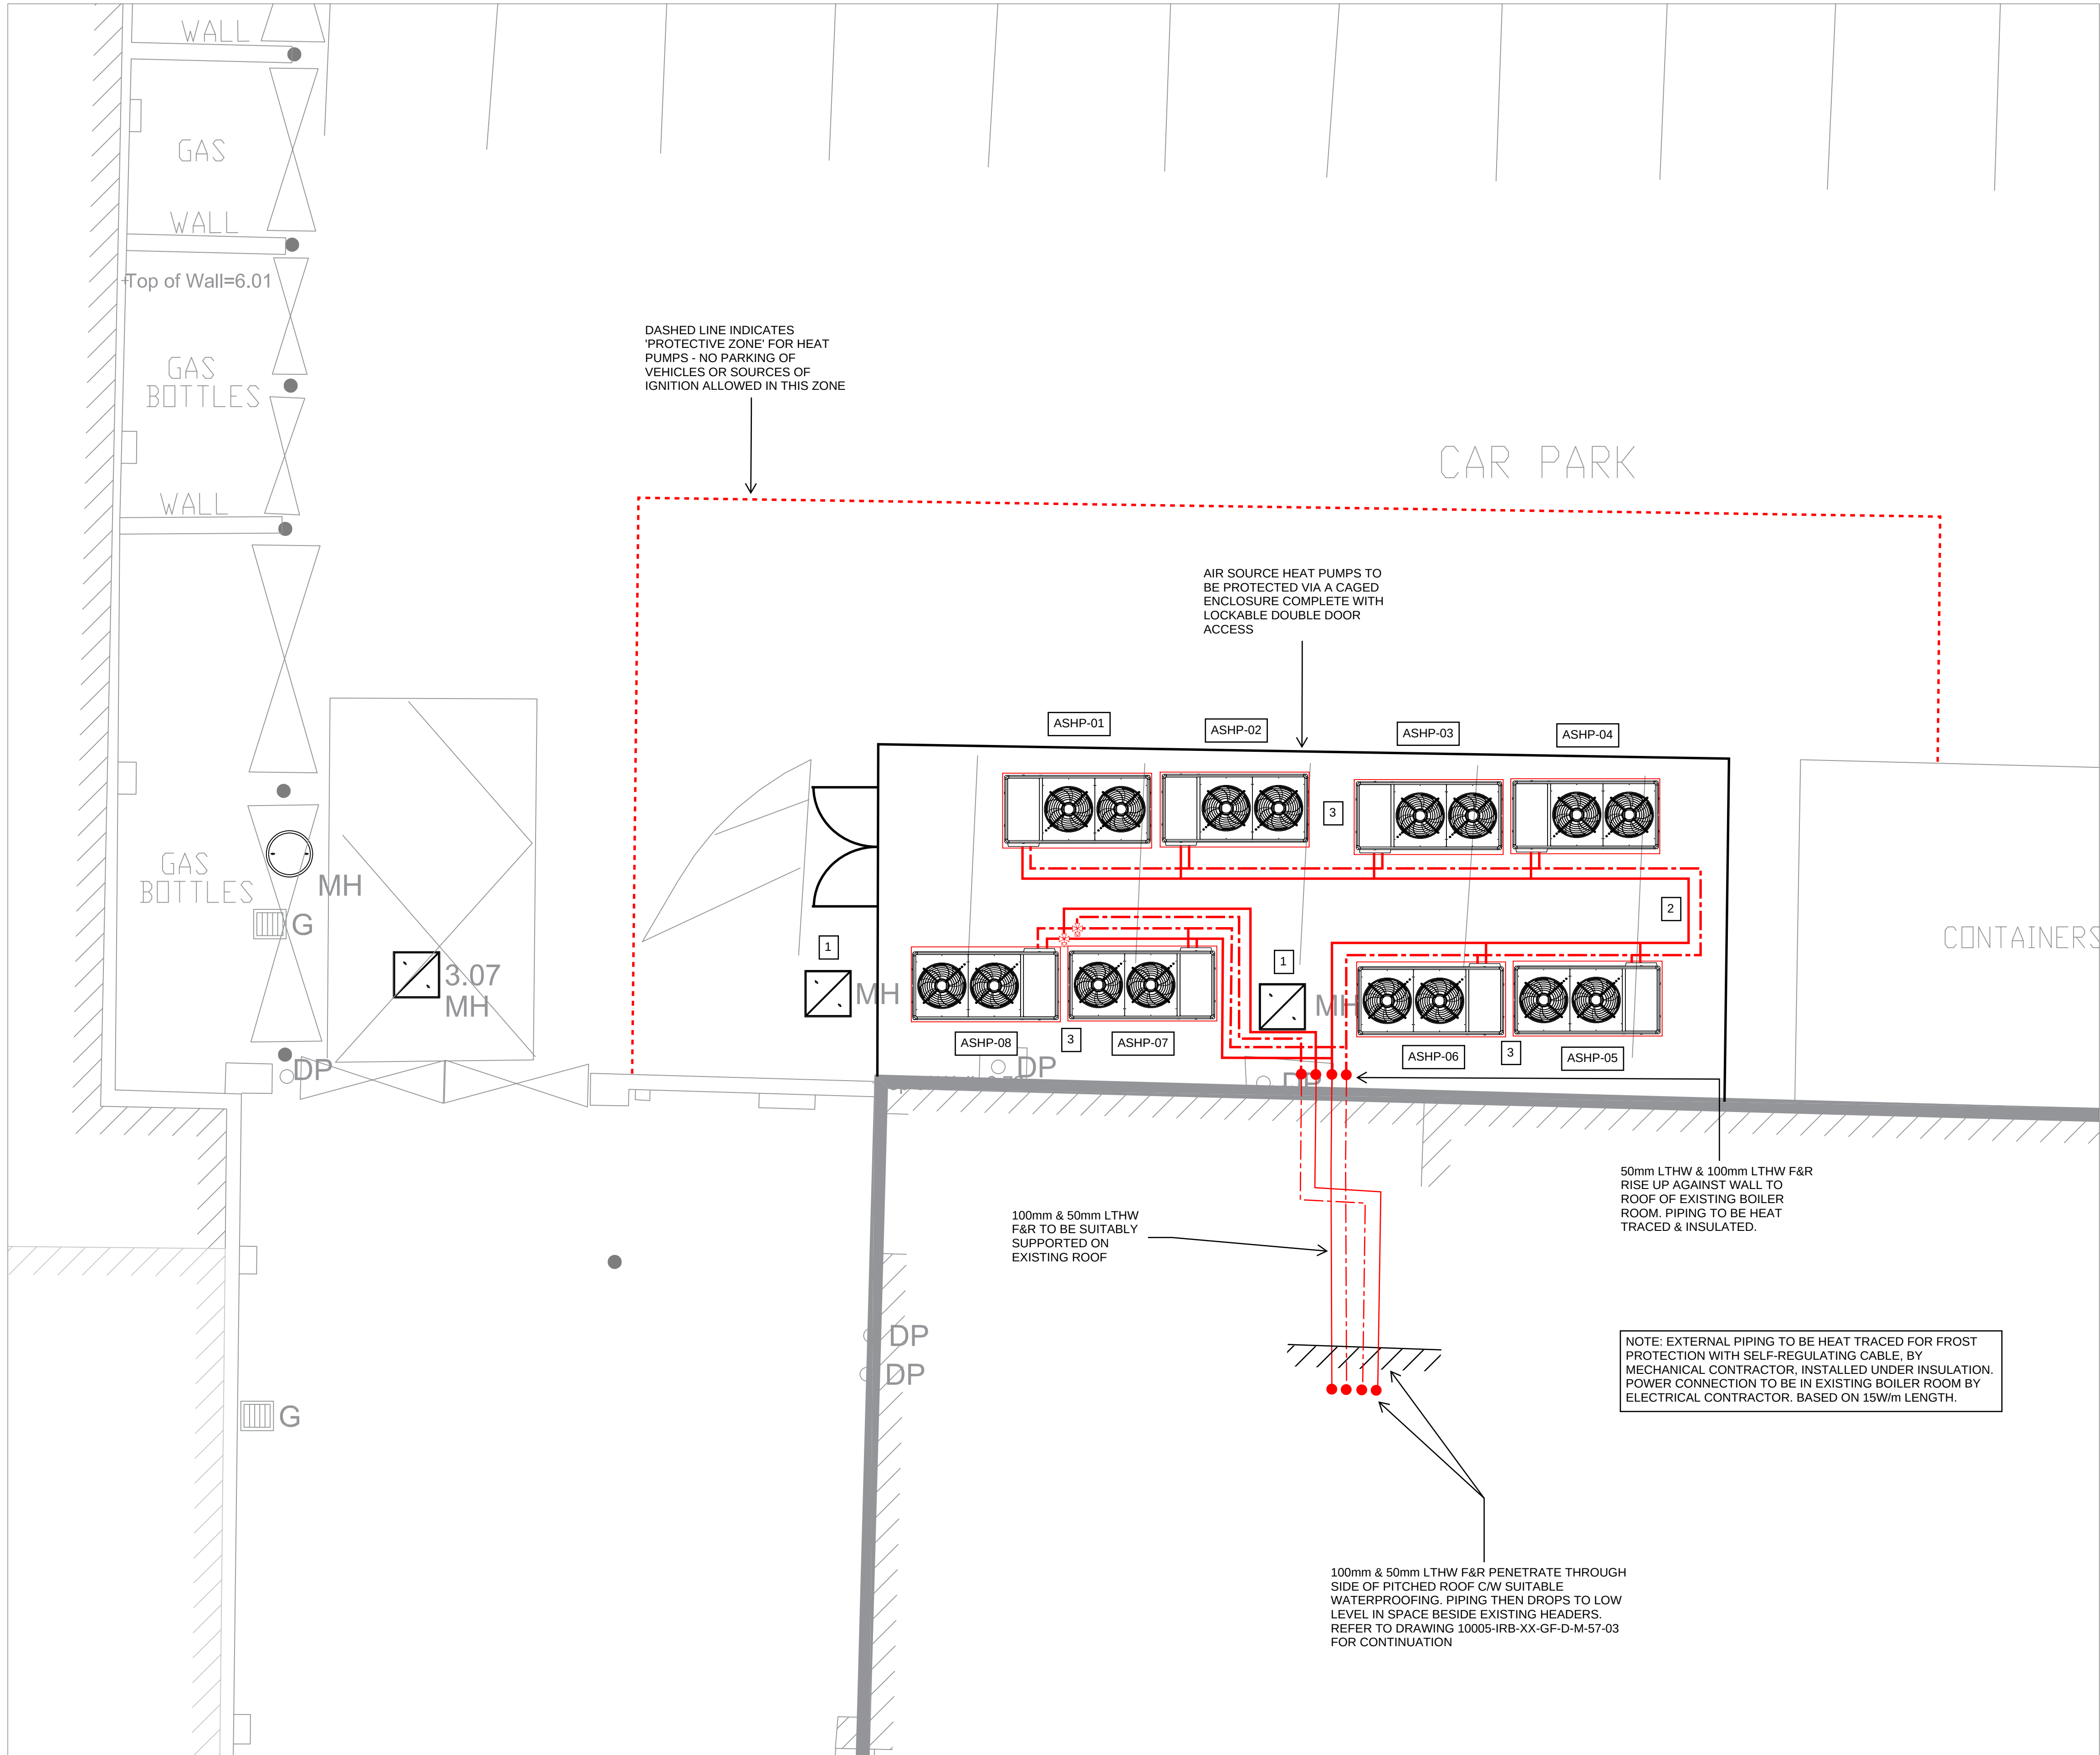

KEYNOTES:

1. MAINTAIN CLEARANCE AROUND EXISTING MANHOLE FOR ACCESS.
2. PIPE ROUTING SHOWN FOR CLARITY - CAN BE ROUTED UNDER THE HEAT PUMPS IF MOUNTED ON SUPPORT FRAME OFF THE GROUND.
3. CONDENSATE DRAINS FROM EACH HEAT PUMP TO BE DIRECTED TO NEAREST OPEN DRAIN AND TERMINATED C/W AIR GAP. TO BE COORDINATED ON SITE.

GENERAL NOTES

1. DO NOT SCALE FROM THIS DRAWING.
2. THE CONTRACTOR MUST VERIFY ALL DIMENSIONS TOLERANCES AND REFERENCES BEFORE PROCEEDING WITH WORKS.
3. ANY DISCREPANCY FOUND BETWEEN THIS DRAWING AND ANY OTHER DOCUMENTS MUST BE REPORTED IMMEDIATELY TO THE CONTRACT ADMINISTRATOR.
4. REMOVE THIS DRAWING FROM CURRENCY WHEN REVISED DRAWING IS ISSUED.
5. COPYRIGHT OF DESIGNS SHOWN ON THIS DRAWING REMAINS WITH INTROBA
6. THIS DRAWING IS TO BE READ IN CONJUNCTION WITH THE SPECIFICATION AND ALL OTHER CONTRACT PROJECT DOCUMENTS.

A1 ORIGINAL SIZE DRAWING

03	ISSUED FOR TENDER	AM	28/08/26
02	STAGE 2b FOR FINAL REVIEW	AM	05/08/26
01	STAGE 2b FOR REVIEW	AM	17/07/26
No.	REVISION	CHK	DATE

Introba
INTROBA IRELAND LTD
CATHEDRAL COURT
NEW ST SOUTH
THE LIBERTIES
DUBLIN 8
D08 C525

CLIENT
LMETB

PROJECT
RSTC DUNDALK

TITLE
SITE PLAN
ASHP COMPOUND

DATE 28.08.2026 SCALE AS NOTED
DESIGNED SPM CHECKED AM APPROVED AM

SUITABILITY CODE A3 SUITABILITY DESCRIPTION FOR TENDER

DRAWING STATUS
STAGE 2b

DRAWING No. 10005-IRB-XX-GF-D-M-57-02 REVISION T01