



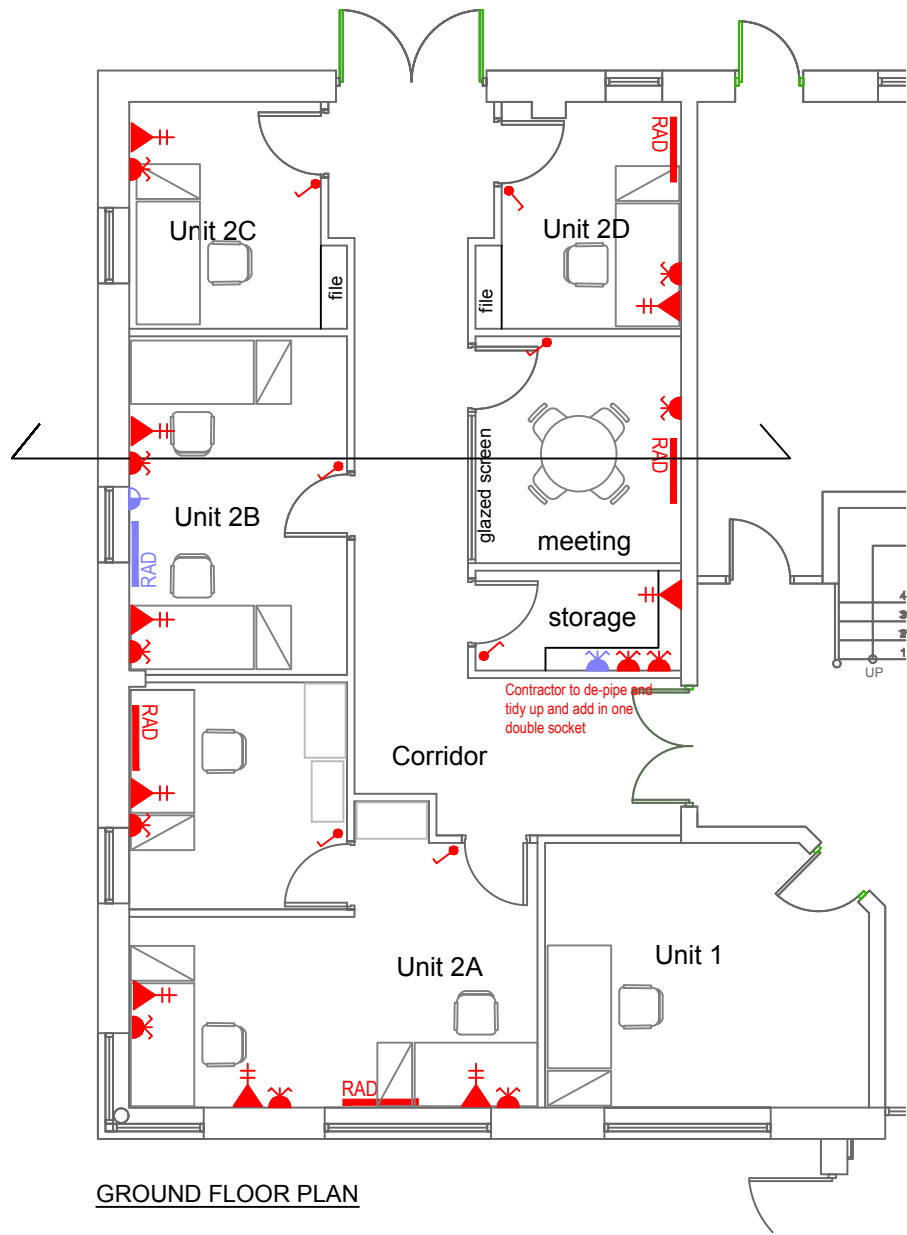

GROUND FLOOR PLAN

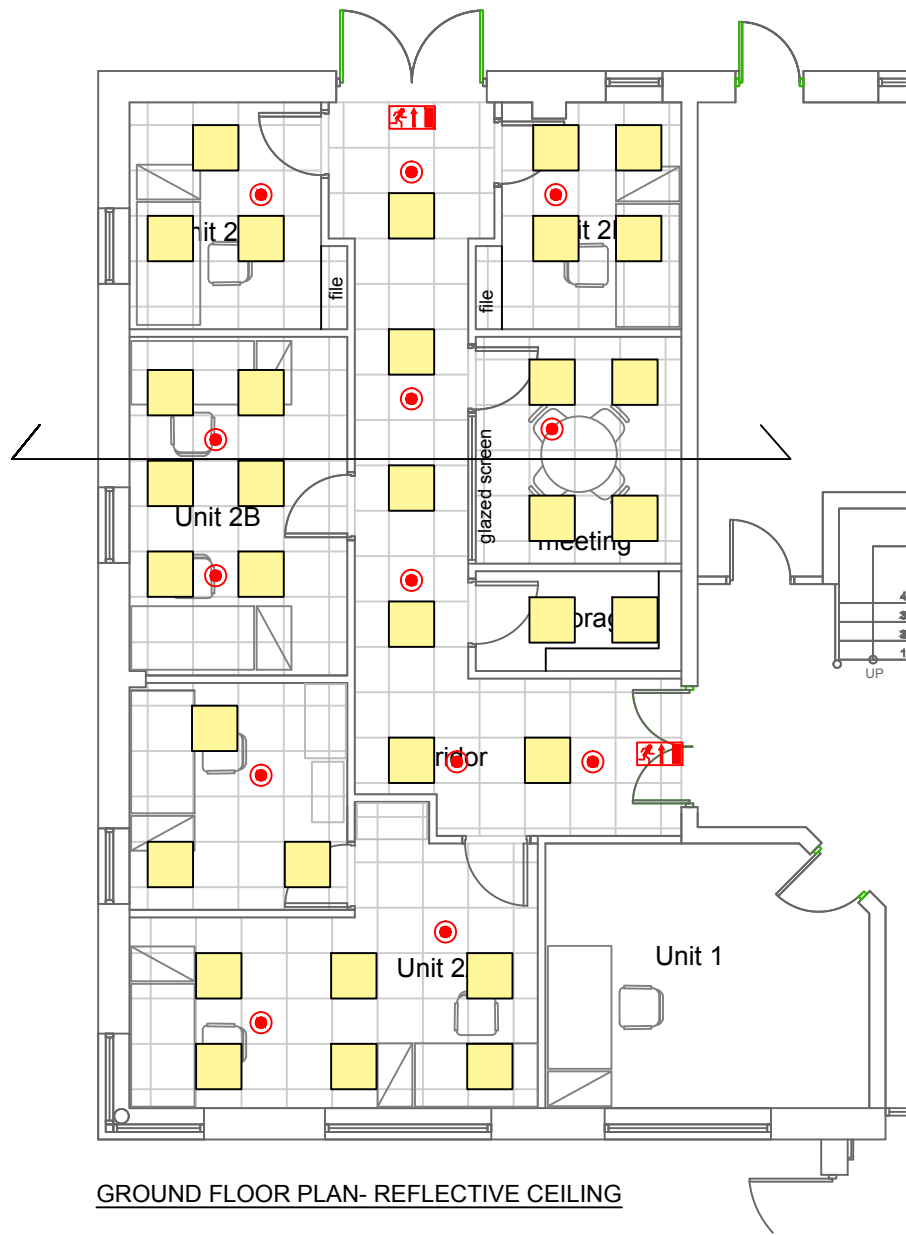

GROUND FLOOR PLAN- REFLECTIVE CEILING

SYMBOLS KEY	
	SINGLE POLE LIGHT SWITCH
	TWIN SOCKET (EXISTING)
	TWIN DATA POINT (EXISTING)
	EMERGENCY LED (NON MAINTAINED)
	FUSED SPUR (PROPOSED)
	PROPOSED RADIATOR (DIMPLEX Q-RAD 75KW)
	TWIN SOCKET (PROPOSED)

LIGHTING KEY	
	600mm x 600mm TEGRAL LOW GALRE LED
	RUNNING MAN
	EMERGENCY LED (NON MAINTAINED)

Scale 1:100

1	Updated to latest design	GT	05/09/26
Issue	Revision / Serial No.	Sig.	Date
	Grogan Lodge Hilltown Tacumshane Co. Wexford Y35 KO94		
Consulting Mechanical + Electrical Engineers Tel: 00 353 (0)87 2295767 Email: info@gmechservices.com Web: www.gmechservices.com			
Client CARLOW COMMUNITY ENTERPRISE CENTRES CLG		Scale 1:100@A3	
Location ENTERPRISE HOUSE, O'BRIEN RD., CARLOW		Date 05/09/26	
Project BUILDING REFURBISHMENT WORKS		Drawn GT	
A3	Title: LIGHTING, EMERGENCY LIGHTING, SMALL POWER & MISCELLANEOUS		
DRG No.	CCC - E01		001
THIS IS A CAD DRAWING DO NOT ALTER			