



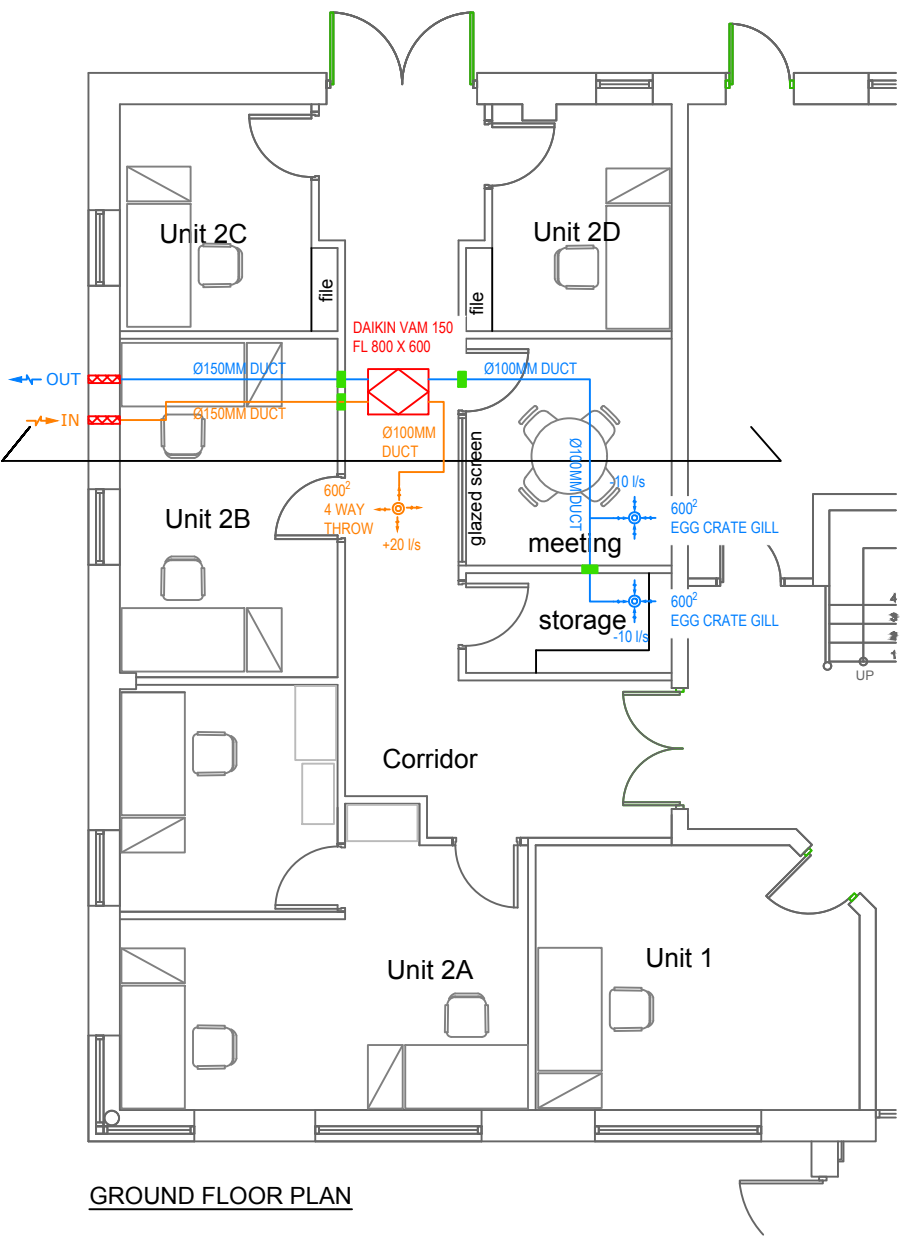

GROUND FLOOR PLAN

SYMBOLS KEY	
	DAIKIN VAM 150 FL 800 X 600
	AIR SUPPLY THROW
	EGG CRATE GRILL
	EXTRACT DUCT
	INTAKE DUCT
	200L EWL ALUMINIMUM GILL
	60MIN MANUAL FIRE DAMPER Ø150mm

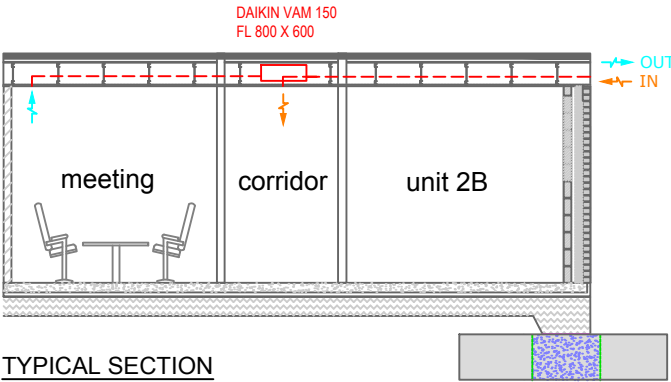

TYPICAL SECTION

Scale 1:100

3			
2			
1	Updated to latest design	GT	09/02/26
Issue	Revision / Serial No.	Sig.	Date
G-MECH SERVICES LTD		Grogan Lodge Hilltown Tacumshane Co. Wexford Y35 KO94	
Consulting Mechanical + Electrical Engineers Tel: 00 353 (0)87 2295767 Email: info@gmechservices.com Web: www.gmechservices.com			
Client CARLOW COMMUNITY ENTERPRISE CENTRES CLG		Scale 1:100@A3	
Location ENTERPRISE HOUSE, O'BRIEN RD., CARLOW		Date 05/09/26	
Project BUILDING REFURBISHMENT WORKS		Drawn GT	
A3	Title: HEATING & VENTILATION		
DRG No.	CCC - M02		001
THIS IS A CAD DRAWING DO NOT ALTER			