


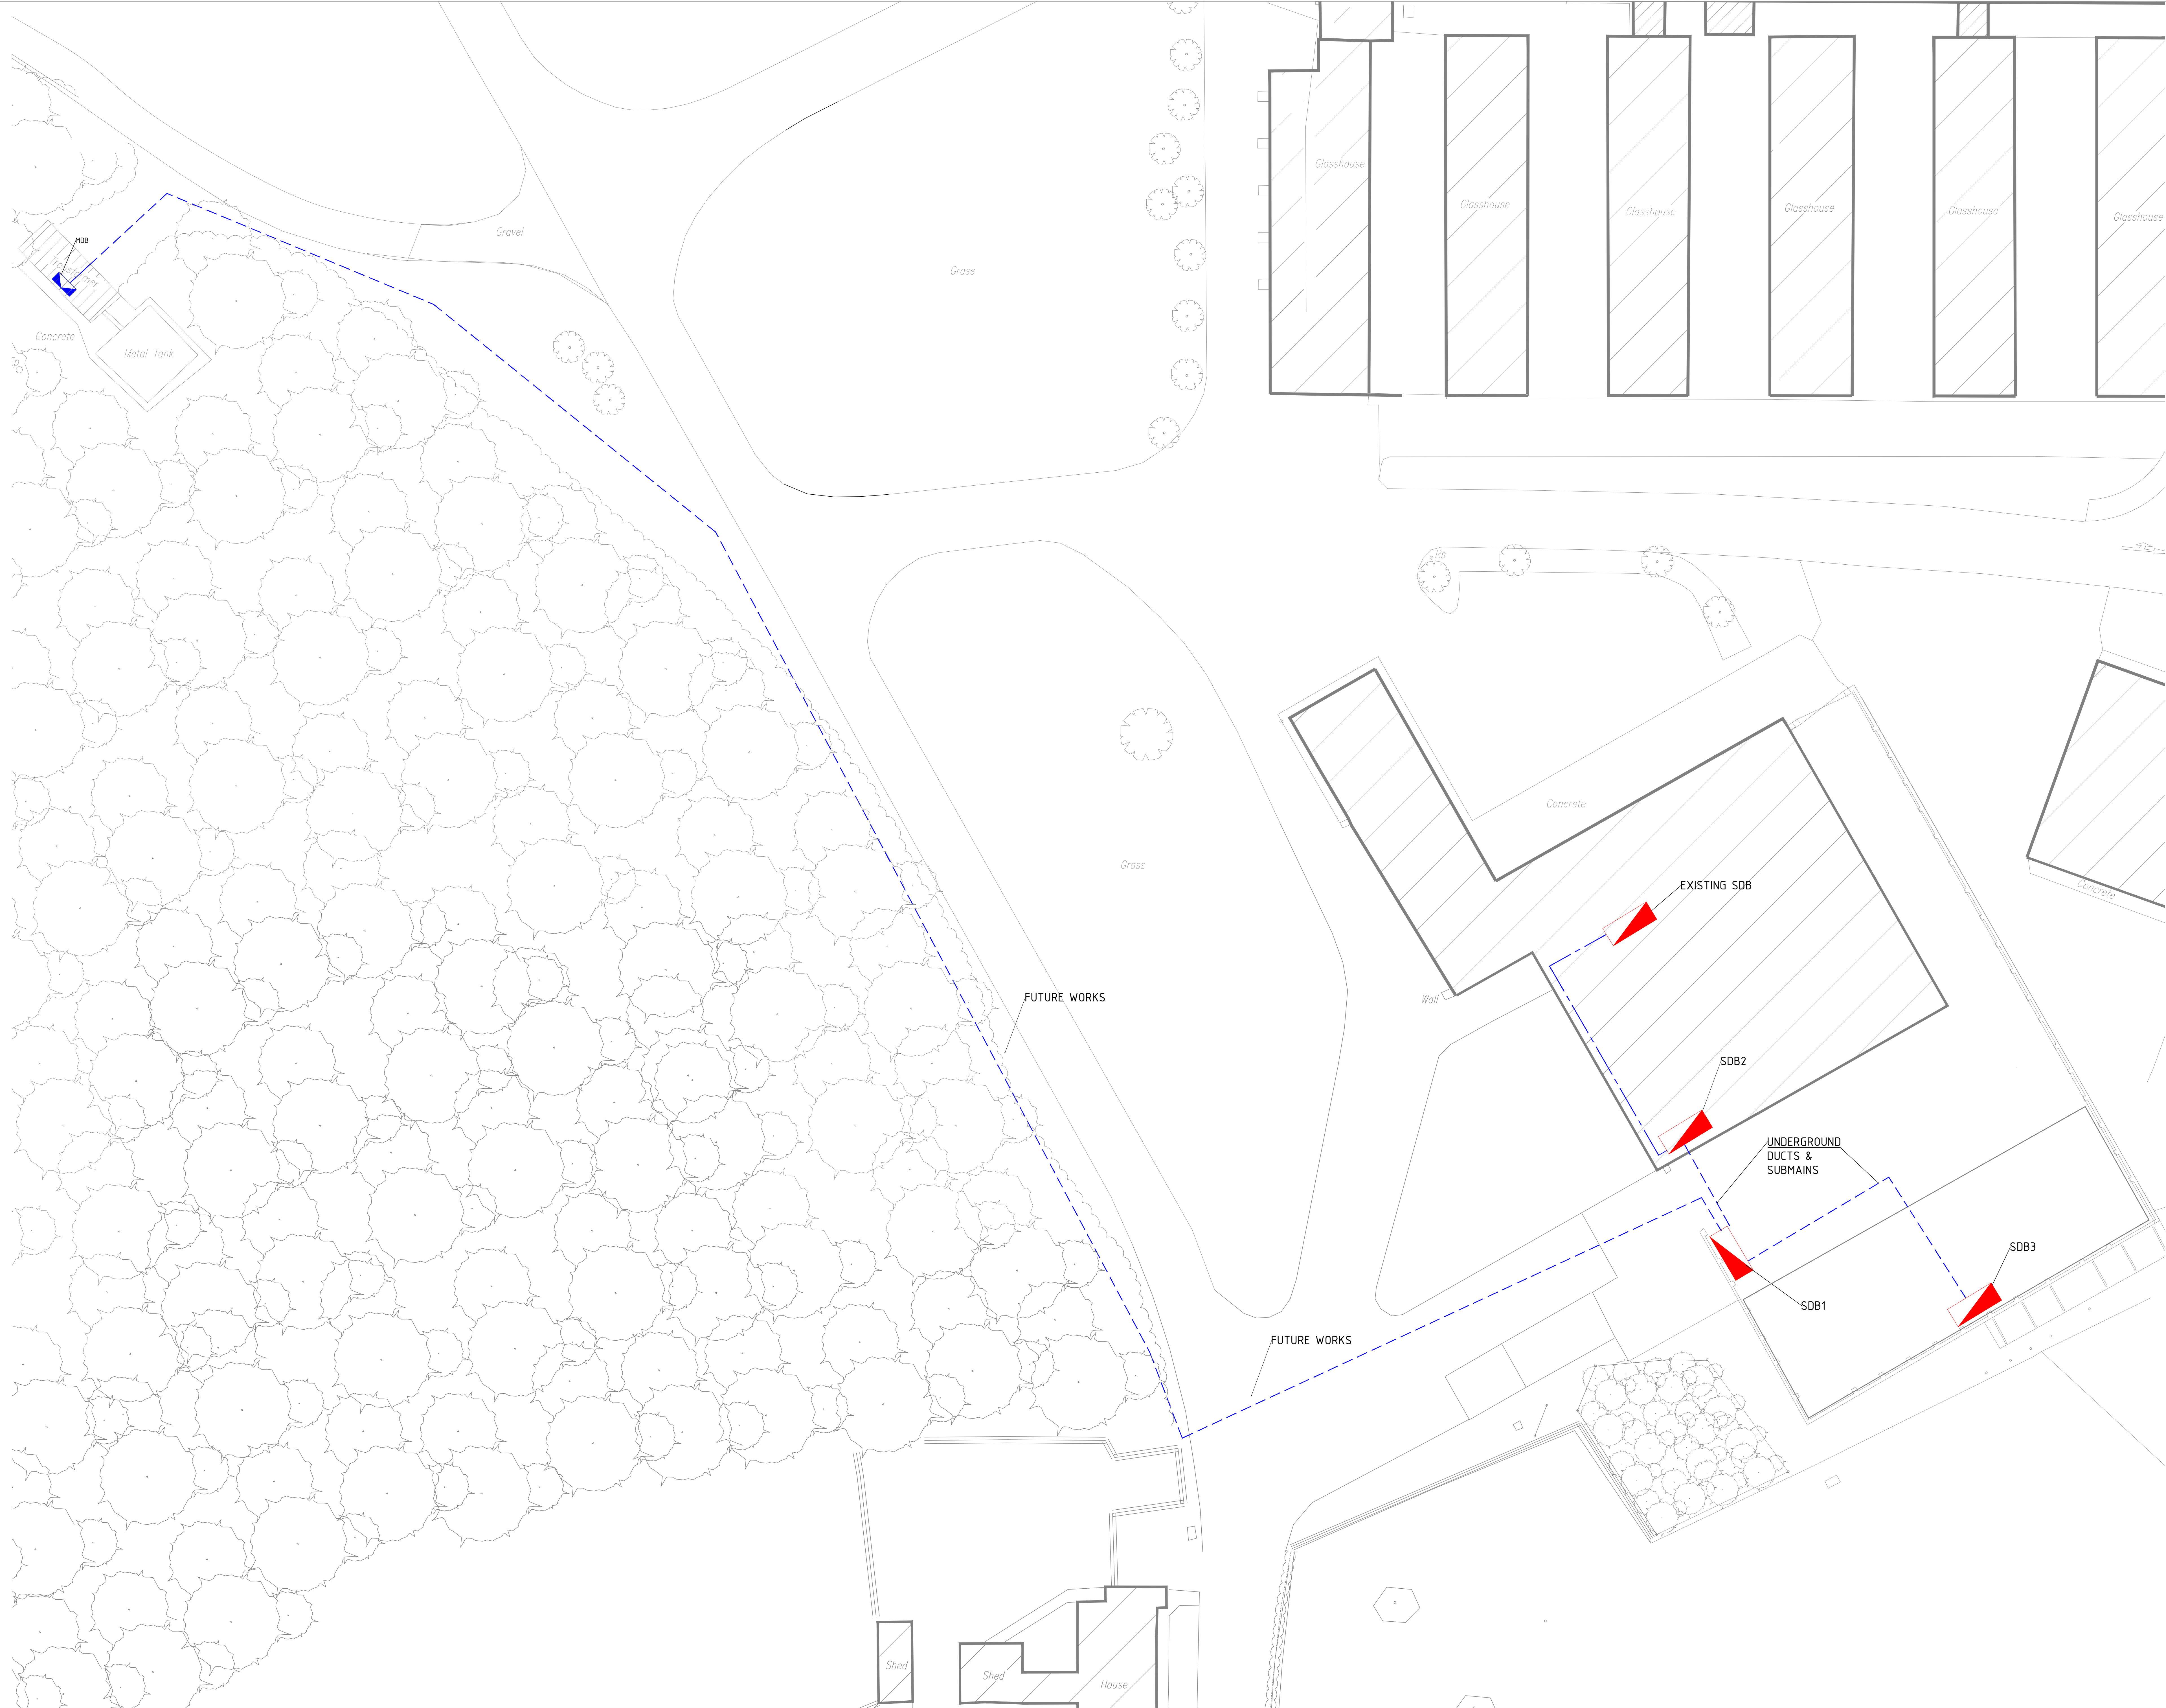

LEGEND

NOTES

- EXISTING MAIN DISTRIBUTION BOARD
- NEW SUB DISTRIBUTION BOARD LOCATION
- SERVICES AT HIGH LEVEL
- UNDERGROUND SERVICES

1	16.07.26	TENDER ISSUE
Rev	Date	Amendments

7 Patrick Street
Kilbenny
Telephone 056 7721115
Email info@lawlerconsulting.com
Web www.lawlerconsulting.com

LAWLER CONSULTING

Title

5 HL BREWERY /DISTILERY - TEAGASC OAKPARK
SITE PLAN
ELECTRICAL SERVICES

Drawn by	LI	Scale	1:200@A0	Date	JULY26
Checked by	RB	Drawing no.	1811-E100		