
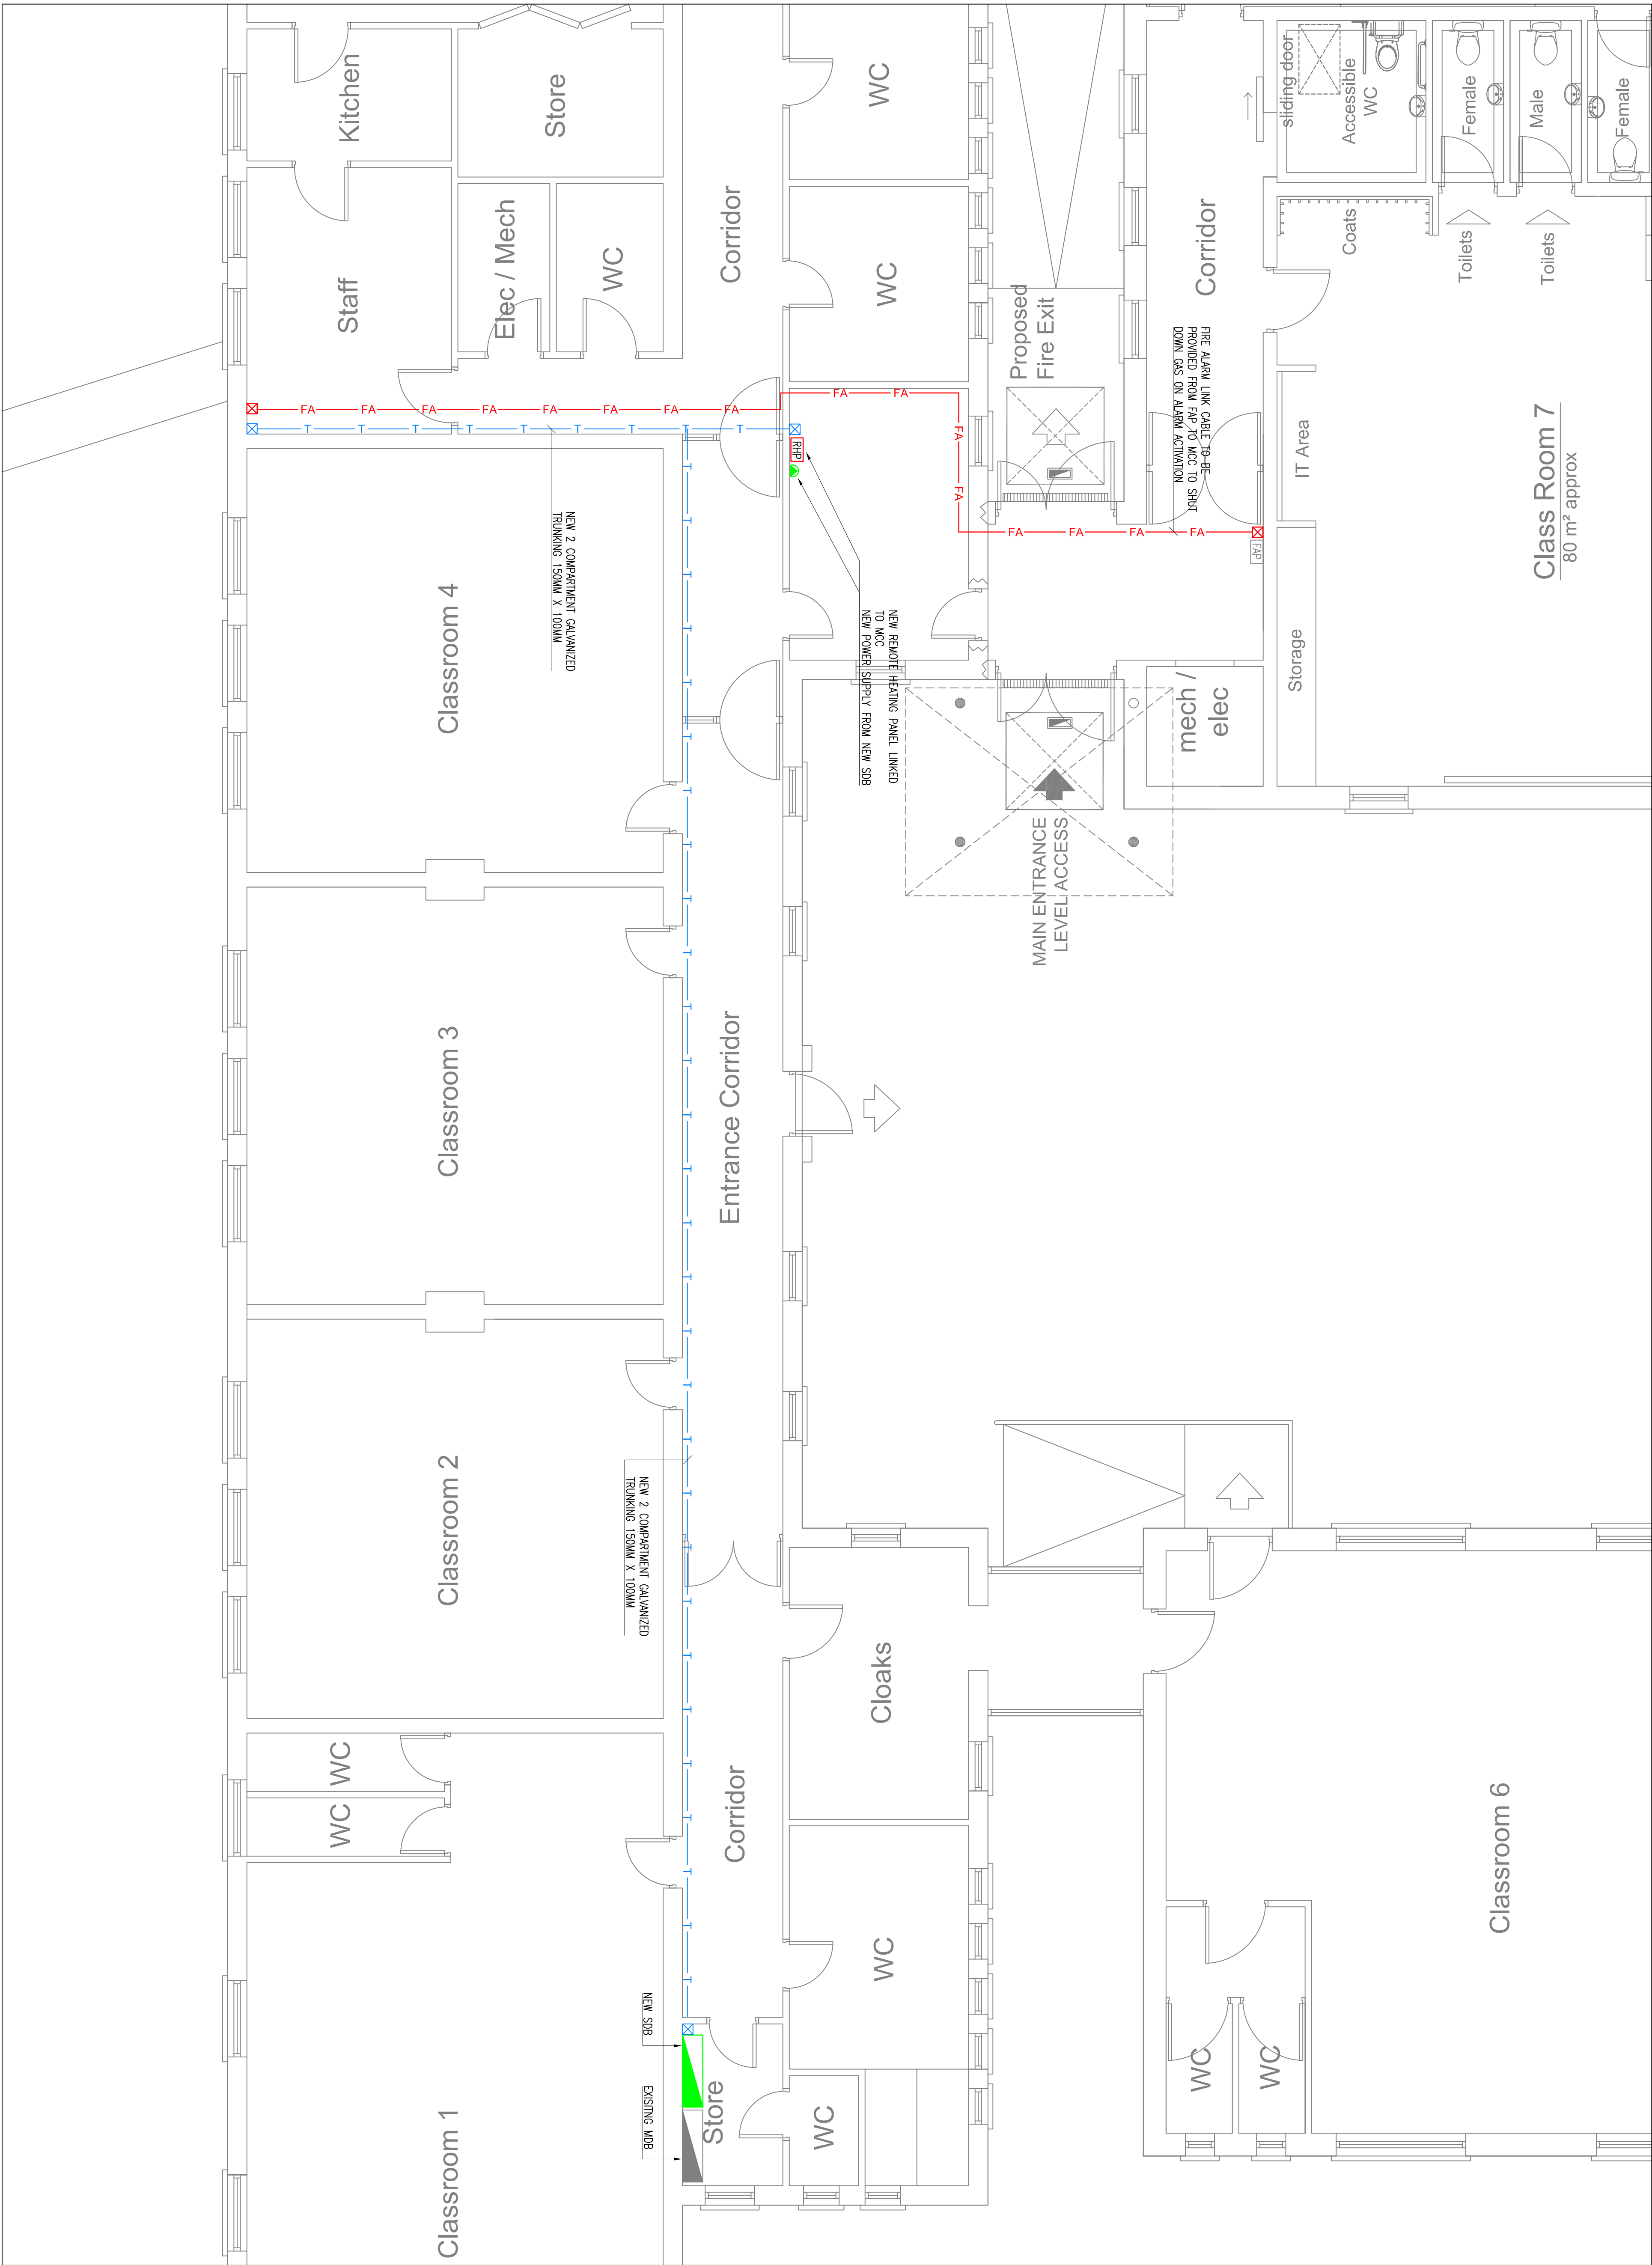



GENERAL NOTES

- THIS DRAWING SHALL BE READ IN CONJUNCTION WITH THE SPECIFICATION AND ALL OTHER RELEVANT DRAWINGS.
- THIS DRAWING MUST NOT BE SCALED FOR INSTALLATION PURPOSES. WORK TO FIGURED AND SITE OBTAINED DIMENSION ONLY.
- THE ELECTRICAL SERVICES CONTRACTOR IS FULLY RESPONSIBLE FOR ALL ON-SITE CO-ORDINATION OF HIS AND ALL OTHER SERVICES.

LEGEND OF SYMBOLS

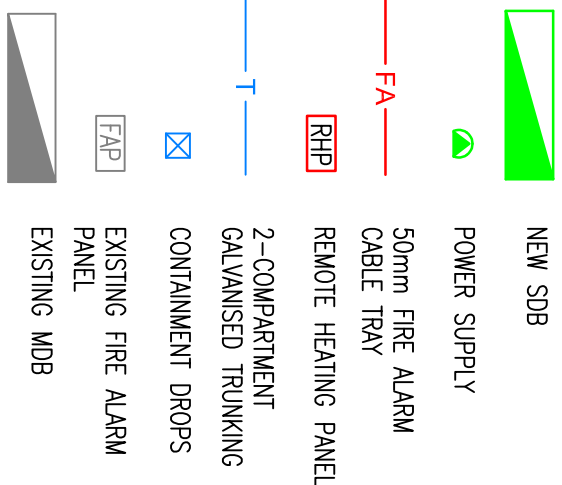

Revisions	TO	ISSUE FOR TENDER	25.09.26	OR
			Date	Checked

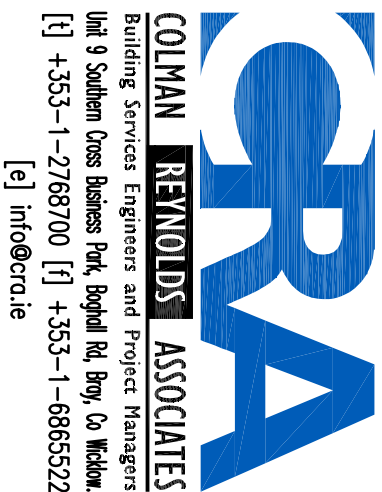

Project PF2025-HP LOT W3-10.3
SN RATHIN

POWER LAYOUT

Date	Drawn	Checked	Scale
13.03.26	PH	OR	1:50 @ A1 1:100 @ A3
Project No.	Drawing No.	Rev.	
A1197-W3-10.3	E200	TO	