


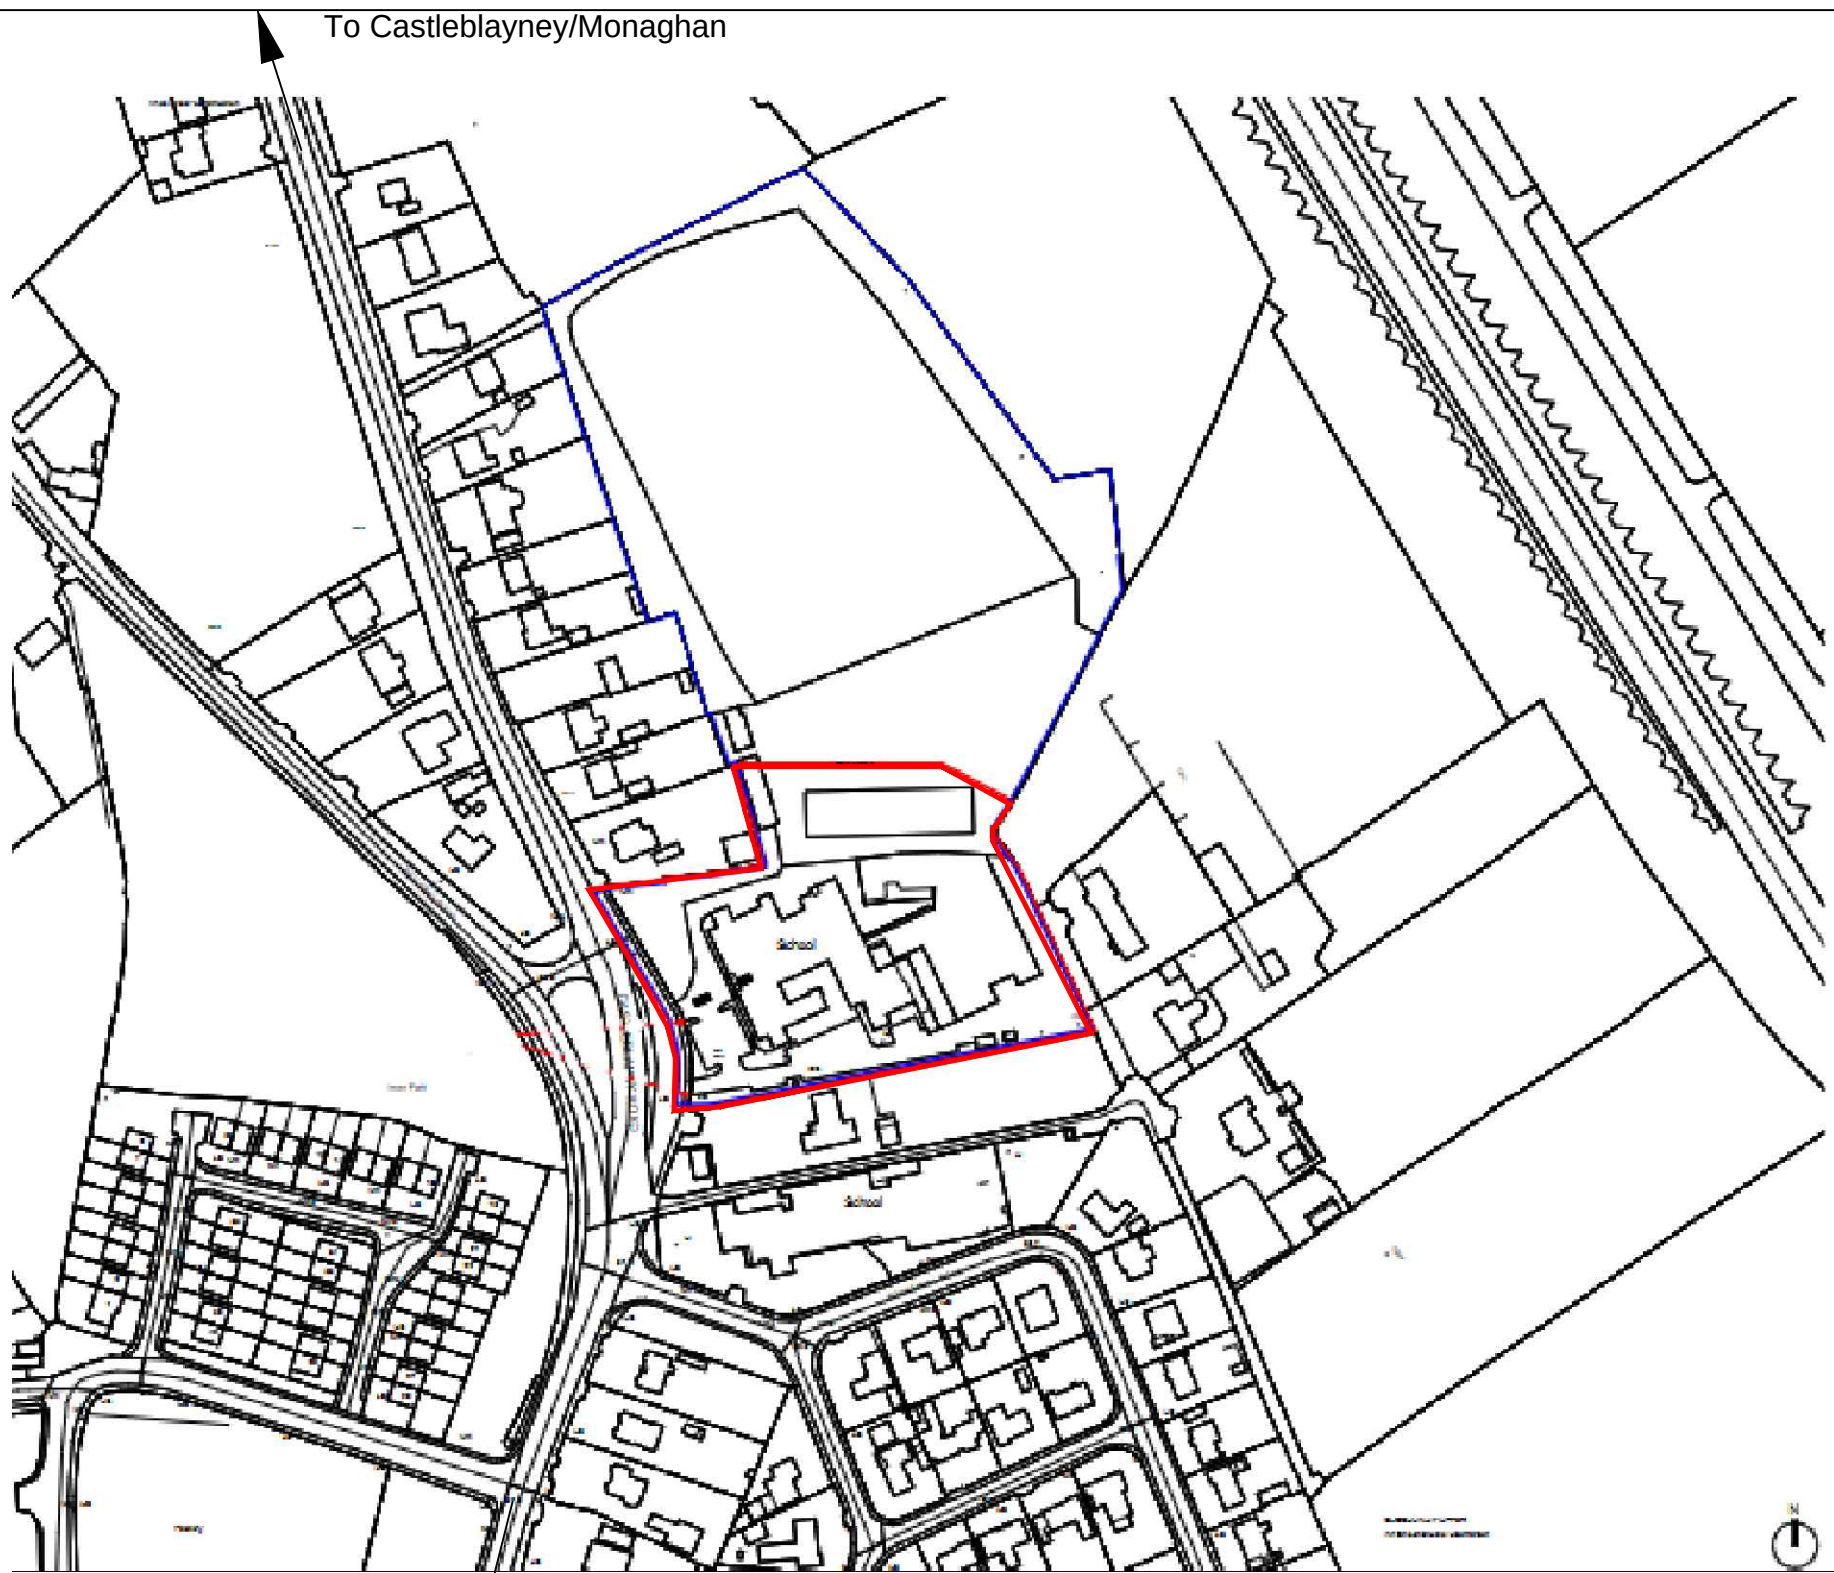

LOCATION PLAN 1: 2500



SITE LAYOUT 1: 500

Rev:		
Date:	Amended by:	Checked by:
Rev:		
Date:	Amended by:	Checked by:
KEYS & MONAGHAN ARCHITECTS		
12 Main St, Irvinestown, Co.Fermanagh BT94 1GJ also at: M TEK 1, Armagh Rd., Monaghan H18 K038. Tel NI: 028 686 28088 / Rol:04767807 email: admin@keysandmonaghan.com website: www.keysandmonaghan.com		
R.I.B.A + R.I.A.I CHARTERED ARCHITECTS		
Job Title: REFURBISHMENT OF SCIENCE CLASSROOM AT INVER COLLEGE, CARRICKMACROSS		
Drwg Title: LOCATION MAP & SITE PLAN		
Drwg. Ref. L-01	Rev: -	
Sc=Scheme Design/ PI =Planning/ WD=Working Drawings	Scale: 1-2500 1-500@A1	
Job No. 26-015	Drawn by: RB	Checked by: EV
Date: 07.08.2026	Planning Ref: / /	
Building Control Ref:		
© Copyright.		