
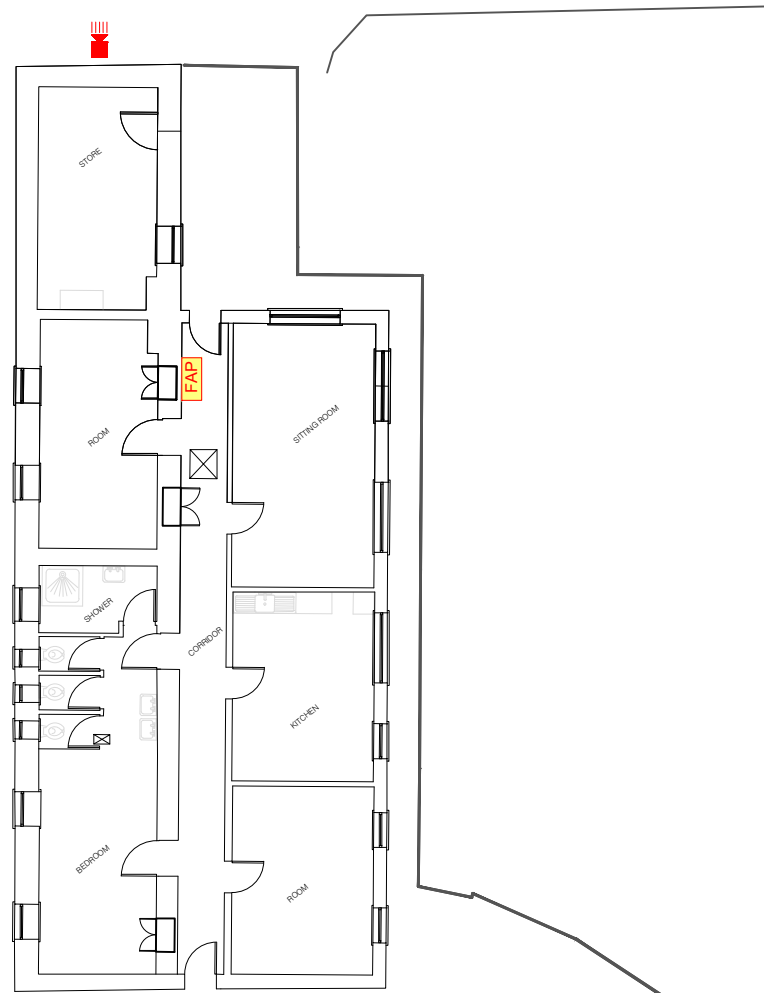
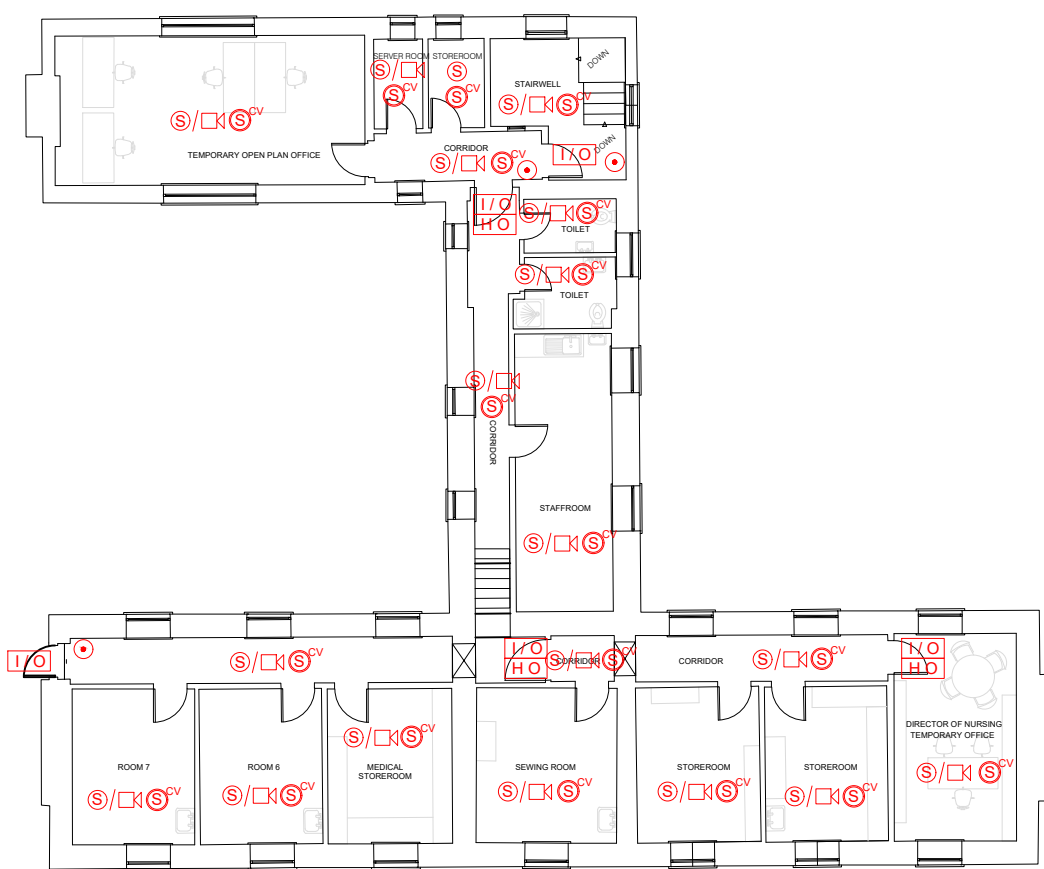


INDICATIVE LAYOUT - DESIGN INTENT

NOTES
ALL DIMENSIONS TO BE CHECKED ON SITE
NO DIMENSIONS TO BE SCALED FROM THIS DRAWING
THIS DRAWING TO BE READ IN CONJUNCTION WITH FIRE CERT CONSULTANTS' WRITTEN SUBMISSION

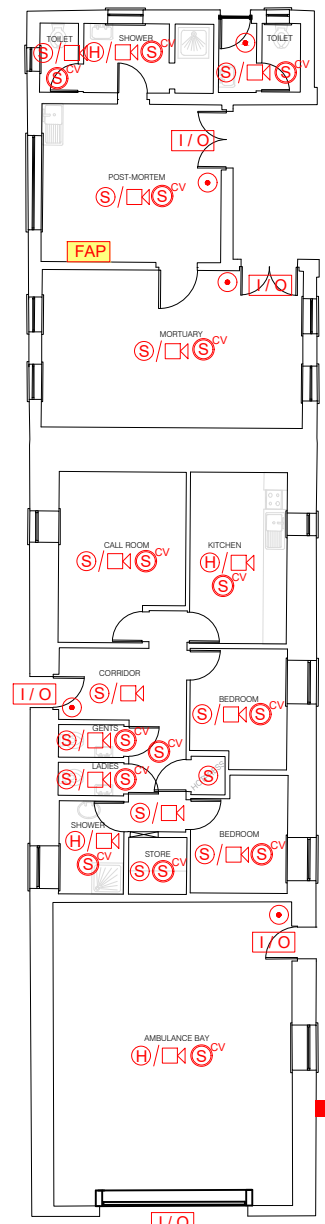

- MANUAL CALL POINT
- SMOKE DETECTOR
- SMOKE DETECTOR / SOUNDER
- SMOKE DETECTOR IN CEILING VOID
- HEAT DETECTOR / SOUNDER
- SOUNDER / BEACON
- INTERFACE UNIT
- INTERFACE UNIT
- FIRE ALARM PANEL

2 FIRST FLOOR PLAN
Scale: 1:100@A1

1 GROUND FLOOR PLAN
Scale: 1:100@A1

REV	DATE	ITEM			
 Unit A4, Nutgrove Office Park Rathfarnham, Dublin 14, D14 H1X4 ph +353 (0)1 663 0013 fc +353 (0)1 663 0014 info@fire-cert.com www.fire-cert.com					
Client: HEALTH SERVICE EXECUTIVE					
Project: BALTINGLASS COMMUNITY HOSPITAL, BALTINGLASS, Co. WICKLOW -					
Drawing: GROUND AND FIRST FLOOR PLANS STAGE 3 - FIRE SAFETY TENDER BASE DRAWING					
Scale(s): 1:200	Date: Oct '26	Drawn: DT	Checked: SM	Project No. 26048	Status Code T
Dwg: 26048-XX-ZZZ-DR-FCC-FS-3001				Rev:	Sheet: A
Status: For Tender			Stage: 3		