
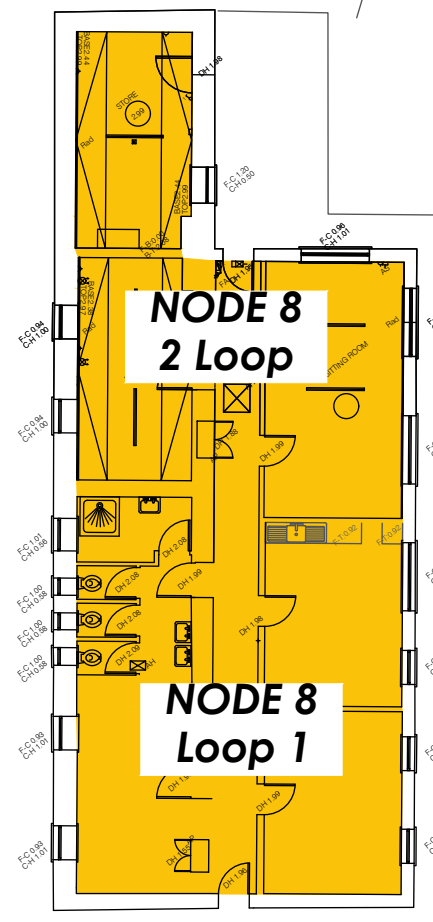


INDICATIVE LAYOUT - DESIGN INTENT

NOTES
ALL DIMENSIONS TO BE CHECKED ON SITE
NO DIMENSIONS TO BE SCALED FROM THIS DRAWING
THIS DRAWING TO BE READ IN CONJUNCTION WITH FIRE CERT CONSULTANTS' WRITTEN SUBMISSION

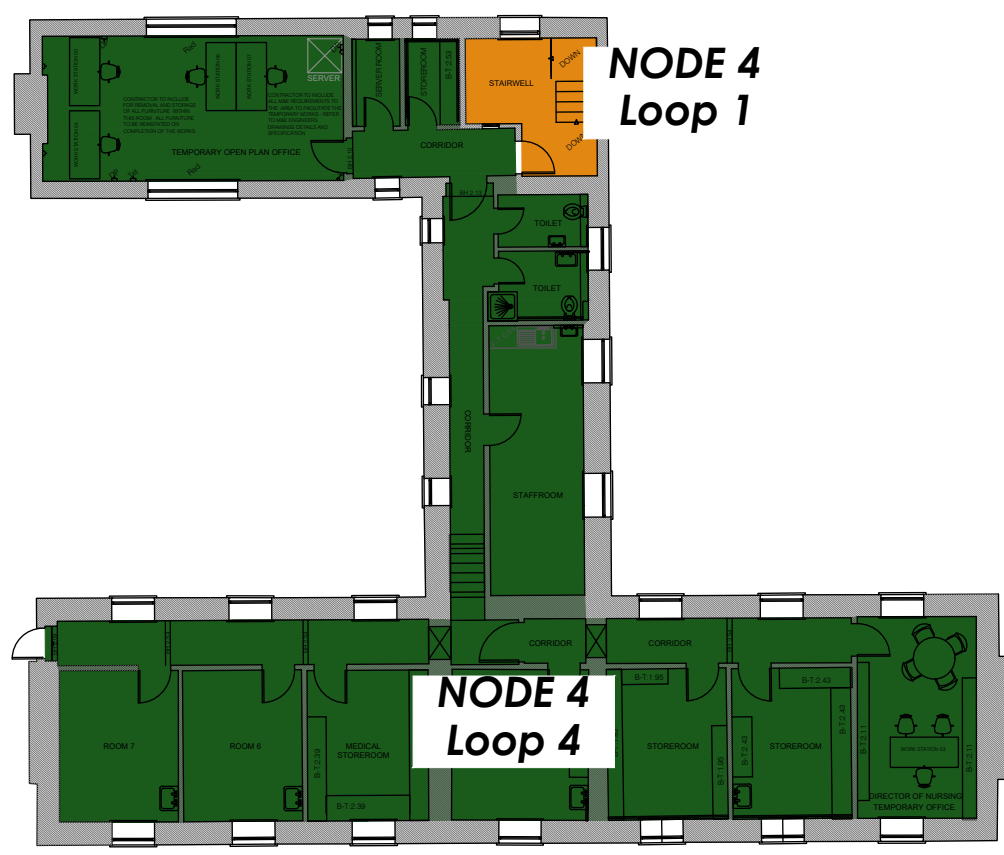

2 FIRST FLOOR PLAN - FIRE ALARM PANEL & NODES (FAP-NODES)
Scale: 1:200@A1

1 GROUND FLOOR PLAN - FIRE ALARM PANEL & NODES (FAP-NODES)
Scale: 1:200@A1

REV	DATE	ITEM
 FCC THE FIRE SAFETY ENGINEERS		
Unit A4, Nutgrove Office Park, Rathfarnham, Dublin 14, D14 H1X4 ph +353 (0)1 663 0013 fc +353 (0)1 663 0014 info@fire-cert.com www.fire-cert.com		
Client: HEALTH SERVICE EXECUTIVE		
Project: BALTINGLASS COMMUNITY HOSPITAL, BALTINGLASS, Co. WICKLOW -		
Drawing: GROUND & FIRST FLOOR PLANS - FIRE ALARM PANELS & NODES STAGE 3 - FIRE SAFETY TENDER DRAWING (FAP-NODES)		
Scale(s): 1:200	Date: Oct '26	Drawn: ApT
Checked: SM	Project No. 26048	Status Code: T
Dwg: 26048-XX-ZZZ-DR-FCC-FS-6001		Rev: Sheet: A1
Status: For Tender		Stage: 3