

INDICATIVE LAYOUT - DESIGN INTENT


NOTES
ALL DIMENSIONS TO BE CHECKED ON SITE
NO DIMENSIONS TO BE SCALED FROM THIS DRAWING
THIS DRAWING TO BE READ IN CONJUNCTION WITH FIRE CERT CONSULTANTS' WRITTEN SUBMISSION




LEGEND:

INFECTION CONTROL PROVISIONS,
NORMAL WORKING HOURS / OUT OF
WORKING HOURS.
(REFER TO ASPERGILLOSIS
SPECIFICATION AND GUIDANCE).

- DAY TIME WORK
• NO PATIENTS
• STAFF TO BE MOVED BY
HOSPITAL MANAGEMENT
- NIGHT-TIME WORK
• NO PATIENTS
• NO STAFF
- DAY TIME WORK
• GENERALLY GROUP 1 - IF ANY
GROUP 2 PATIENTS, HOSPITAL TO
MOVE PATIENTS
- DAY TIME WORK
• GROUP 2 TO 4 PATIENTS
- WEEKEND WORK
• IF ANY GROUP 2 TO 4 PATIENTS
HOSPITAL TO ARRANGE
SHUTDOWN.

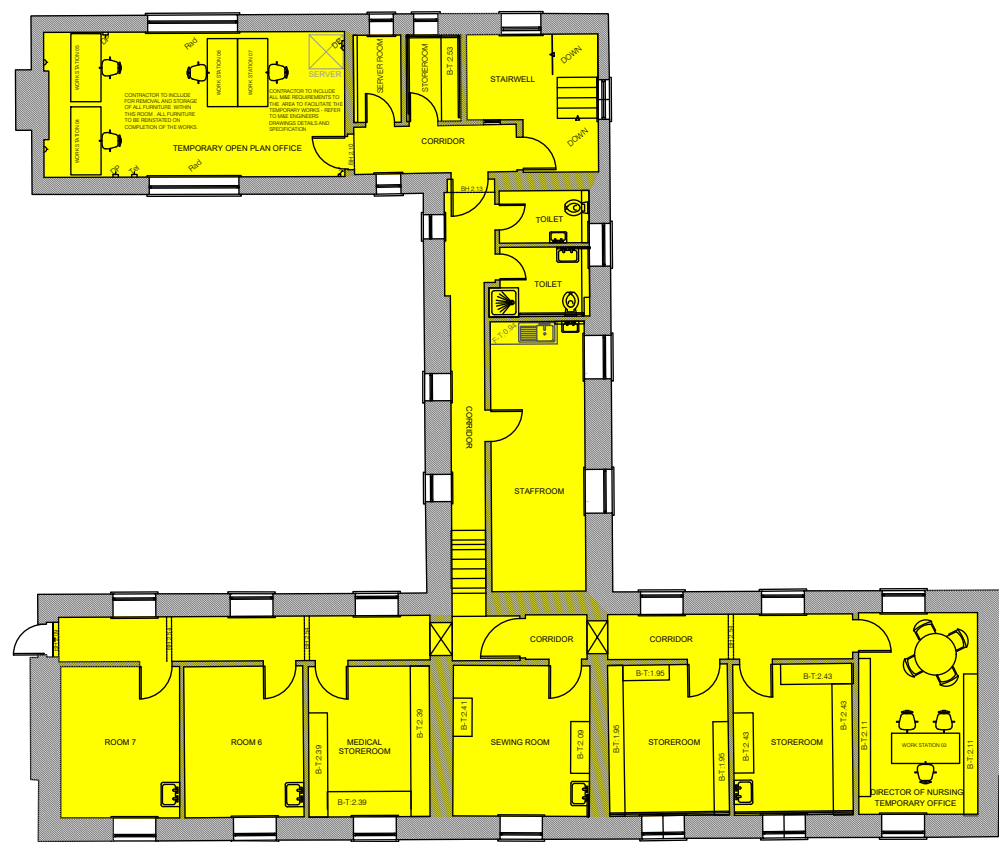

2 FIRST FLOOR PLAN - WORKING TIMES (WT)
Scale: 1:200@A1

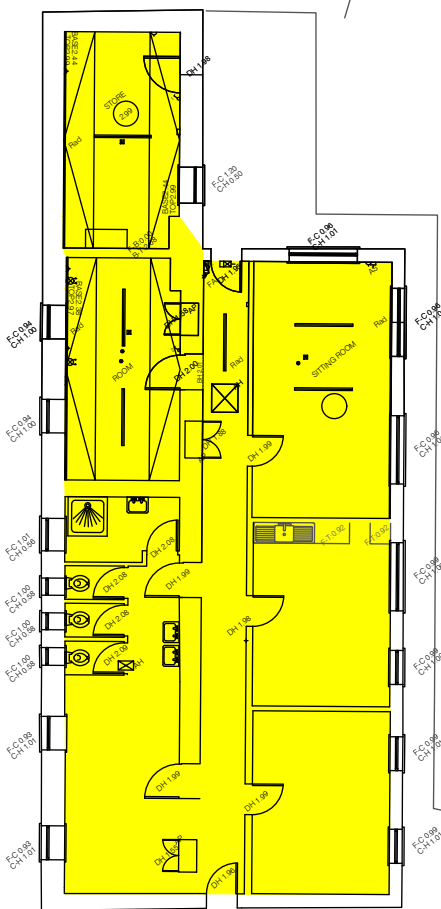

1 GROUND FLOOR PLAN - WORKING TIMES (WT)
Scale: 1:200@A1

REV	DATE	ITEM
 FCC THE FIRE SAFETY ENGINEERS Unit A4, Nutgrove Office Park, Rathfarnham, Dublin 14, D14 H1X4 ph +353 (0)1 663 0013 fc +353 (0)1 663 0014 info@fire-cert.com www.fire-cert.com		
Client: HEALTH SERVICE EXECUTIVE		
Project: BALTINGLASS COMMUNITY HOSPITAL, BALTINGLASS, Co. WICKLOW -		
Drawing: GROUND & FIRST FLOOR PLANS - WORKING TIMES (WT) STAGE 3 - FIRE SAFETY TENDER DRAWING		
Scale(s): 1:200	Date: Oct '26	Drawn: ApT
Checked: SM	Project No. 26048	Status Code: T
Dwg: 26048-XX-ZZZ-DR-FCC-FS-1001		Rev: Sheet: A1
Status: For Tender		Stage: 3