


INDICATIVE LAYOUT - DESIGN INTENT

NOTES
ALL DIMENSIONS TO BE CHECKED ON SITE
NO DIMENSIONS TO BE SCALED FROM THIS DRAWING
THIS DRAWING TO BE READ IN CONJUNCTION WITH FIRE CERT CONSULTANTS' WRITTEN SUBMISSION




LEGEND: REFLECTED CEILINGS

-  SUSPENDED CEILINGS
-  METAL CEILINGS
-  CONCRETE CEILINGS
-  PLASTERBOARD CEILINGS
-  TIMBER CEILINGS

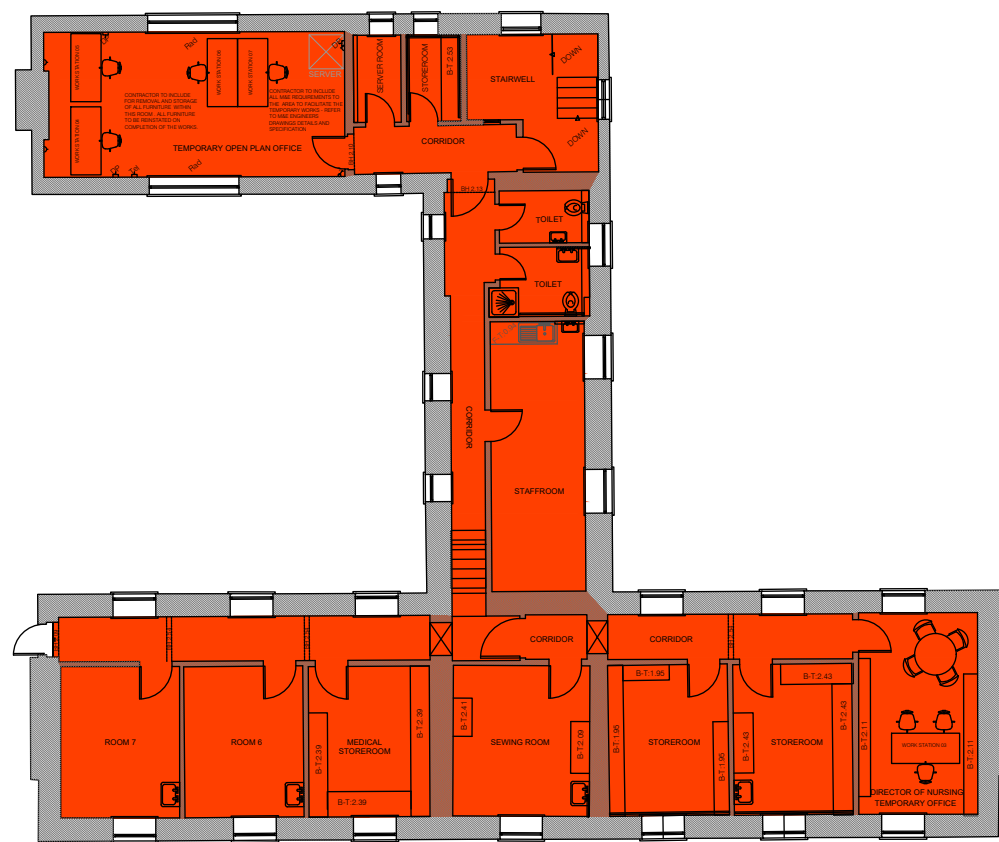

2 FIRST FLOOR PLAN - REFLECTED CEILINGS (RC)

Scale: 1:200@A1

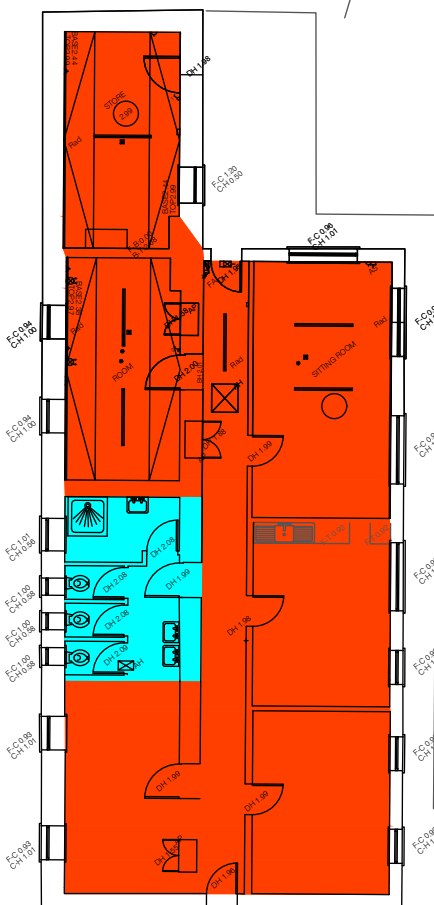

1 GROUND FLOOR PLAN - REFLECTED CEILINGS (RC)

Scale: 1:200@A1

REV	DATE	ITEM
 FCC THE FIRE SAFETY ENGINEERS		
Unit A4, Nutgrove Office Park, Rathfarnham, Dublin 14, D14 H1X4 ph +353 (0)1 665 0013 fc +353 (0)1 665 0014 info@fire-cert.com www.fire-cert.com		
Client: HEALTH SERVICE EXECUTIVE		
Project: BALTINGLASS COMMUNITY HOSPITAL, BALTINGLASS, Co. WICKLOW -		
Drawing: GROUND & FIRST FLOOR PLANS - REFLECTED CEILINGS (RC) STAGE 3 - FIRE SAFETY TENDER DRAWING		
Scale(s): 1:200	Date: Oct '26	Drawn: ApT
Checked: SM	Project No. 26048	Status Code: T
Dwg: 26048-XX-ZZZ-DR-FCC-FS-2001		Rev: Sheet: A1
Status: For Tender		Stage: 3