


NOTES

ALL DIMENSIONS TO BE CHECKED ON SITE
NO DIMENSIONS TO BE SCALED FROM THIS DRAWING
THIS DRAWING TO BE READ IN CONJUNCTION WITH FIRE CERT CONSULTANTS' WRITTEN
SUBMISSION

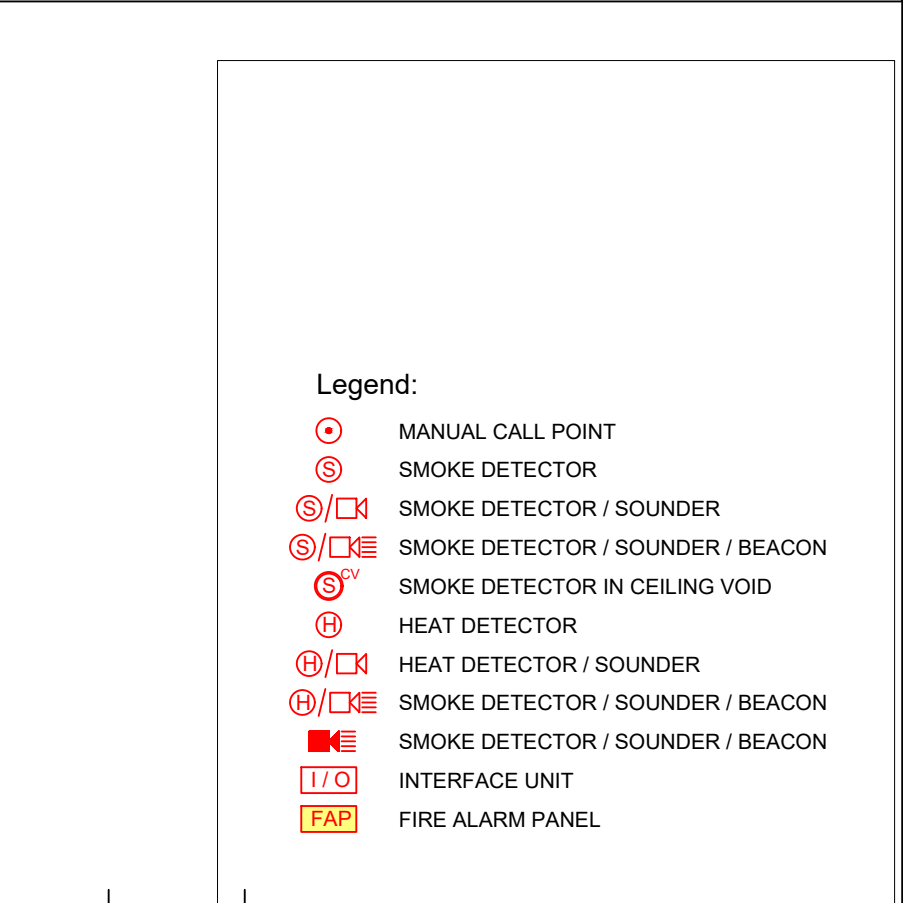

Scale: 1:150@A1

REV	DATE	ITEM		
			Unit A4, Nutgrove Office Park, Rathfarnham, Dublin 14, D14 H1X4 ph +353 (0)1 463 0313 f: +353 (0)1 463 014 info@fire-cert.com www.fire-cert.com	
Client: HEALTH SERVICE EXECUTIVE			 <i>HeALTH SERVICE EXECUTIVE</i>	
Project: MONAGHAN GENERAL HOSPITAL MULLAGHMONAGHAN, MONAGHAN, H18 NV91				
Drawing: GROUND FLOOR PLAN FIRE DETECTION ALARM SYSTEM (FDAS) TENDER DRAWING				
Scale(s): 1:150	Date: Sept '26	Drawn: SB	Checked: SM	Project No: 26045
			Rev:	Status Code: S13
Dwg: 26045-XX-L00-DR-FCC-FS-3001				Sheet: A1
Status: For Tender			Stage: 3	