


INDICATIVE LAYOUT - DESIGN INTENT

NOTES
ALL DIMENSIONS TO BE CHECKED ON SITE
NO DIMENSIONS TO BE SCALED FROM THIS DRAWING
THIS DRAWING TO BE READ IN CONJUNCTION WITH FIRE CERT CONSULTANTS' WRITTEN SUBMISSION

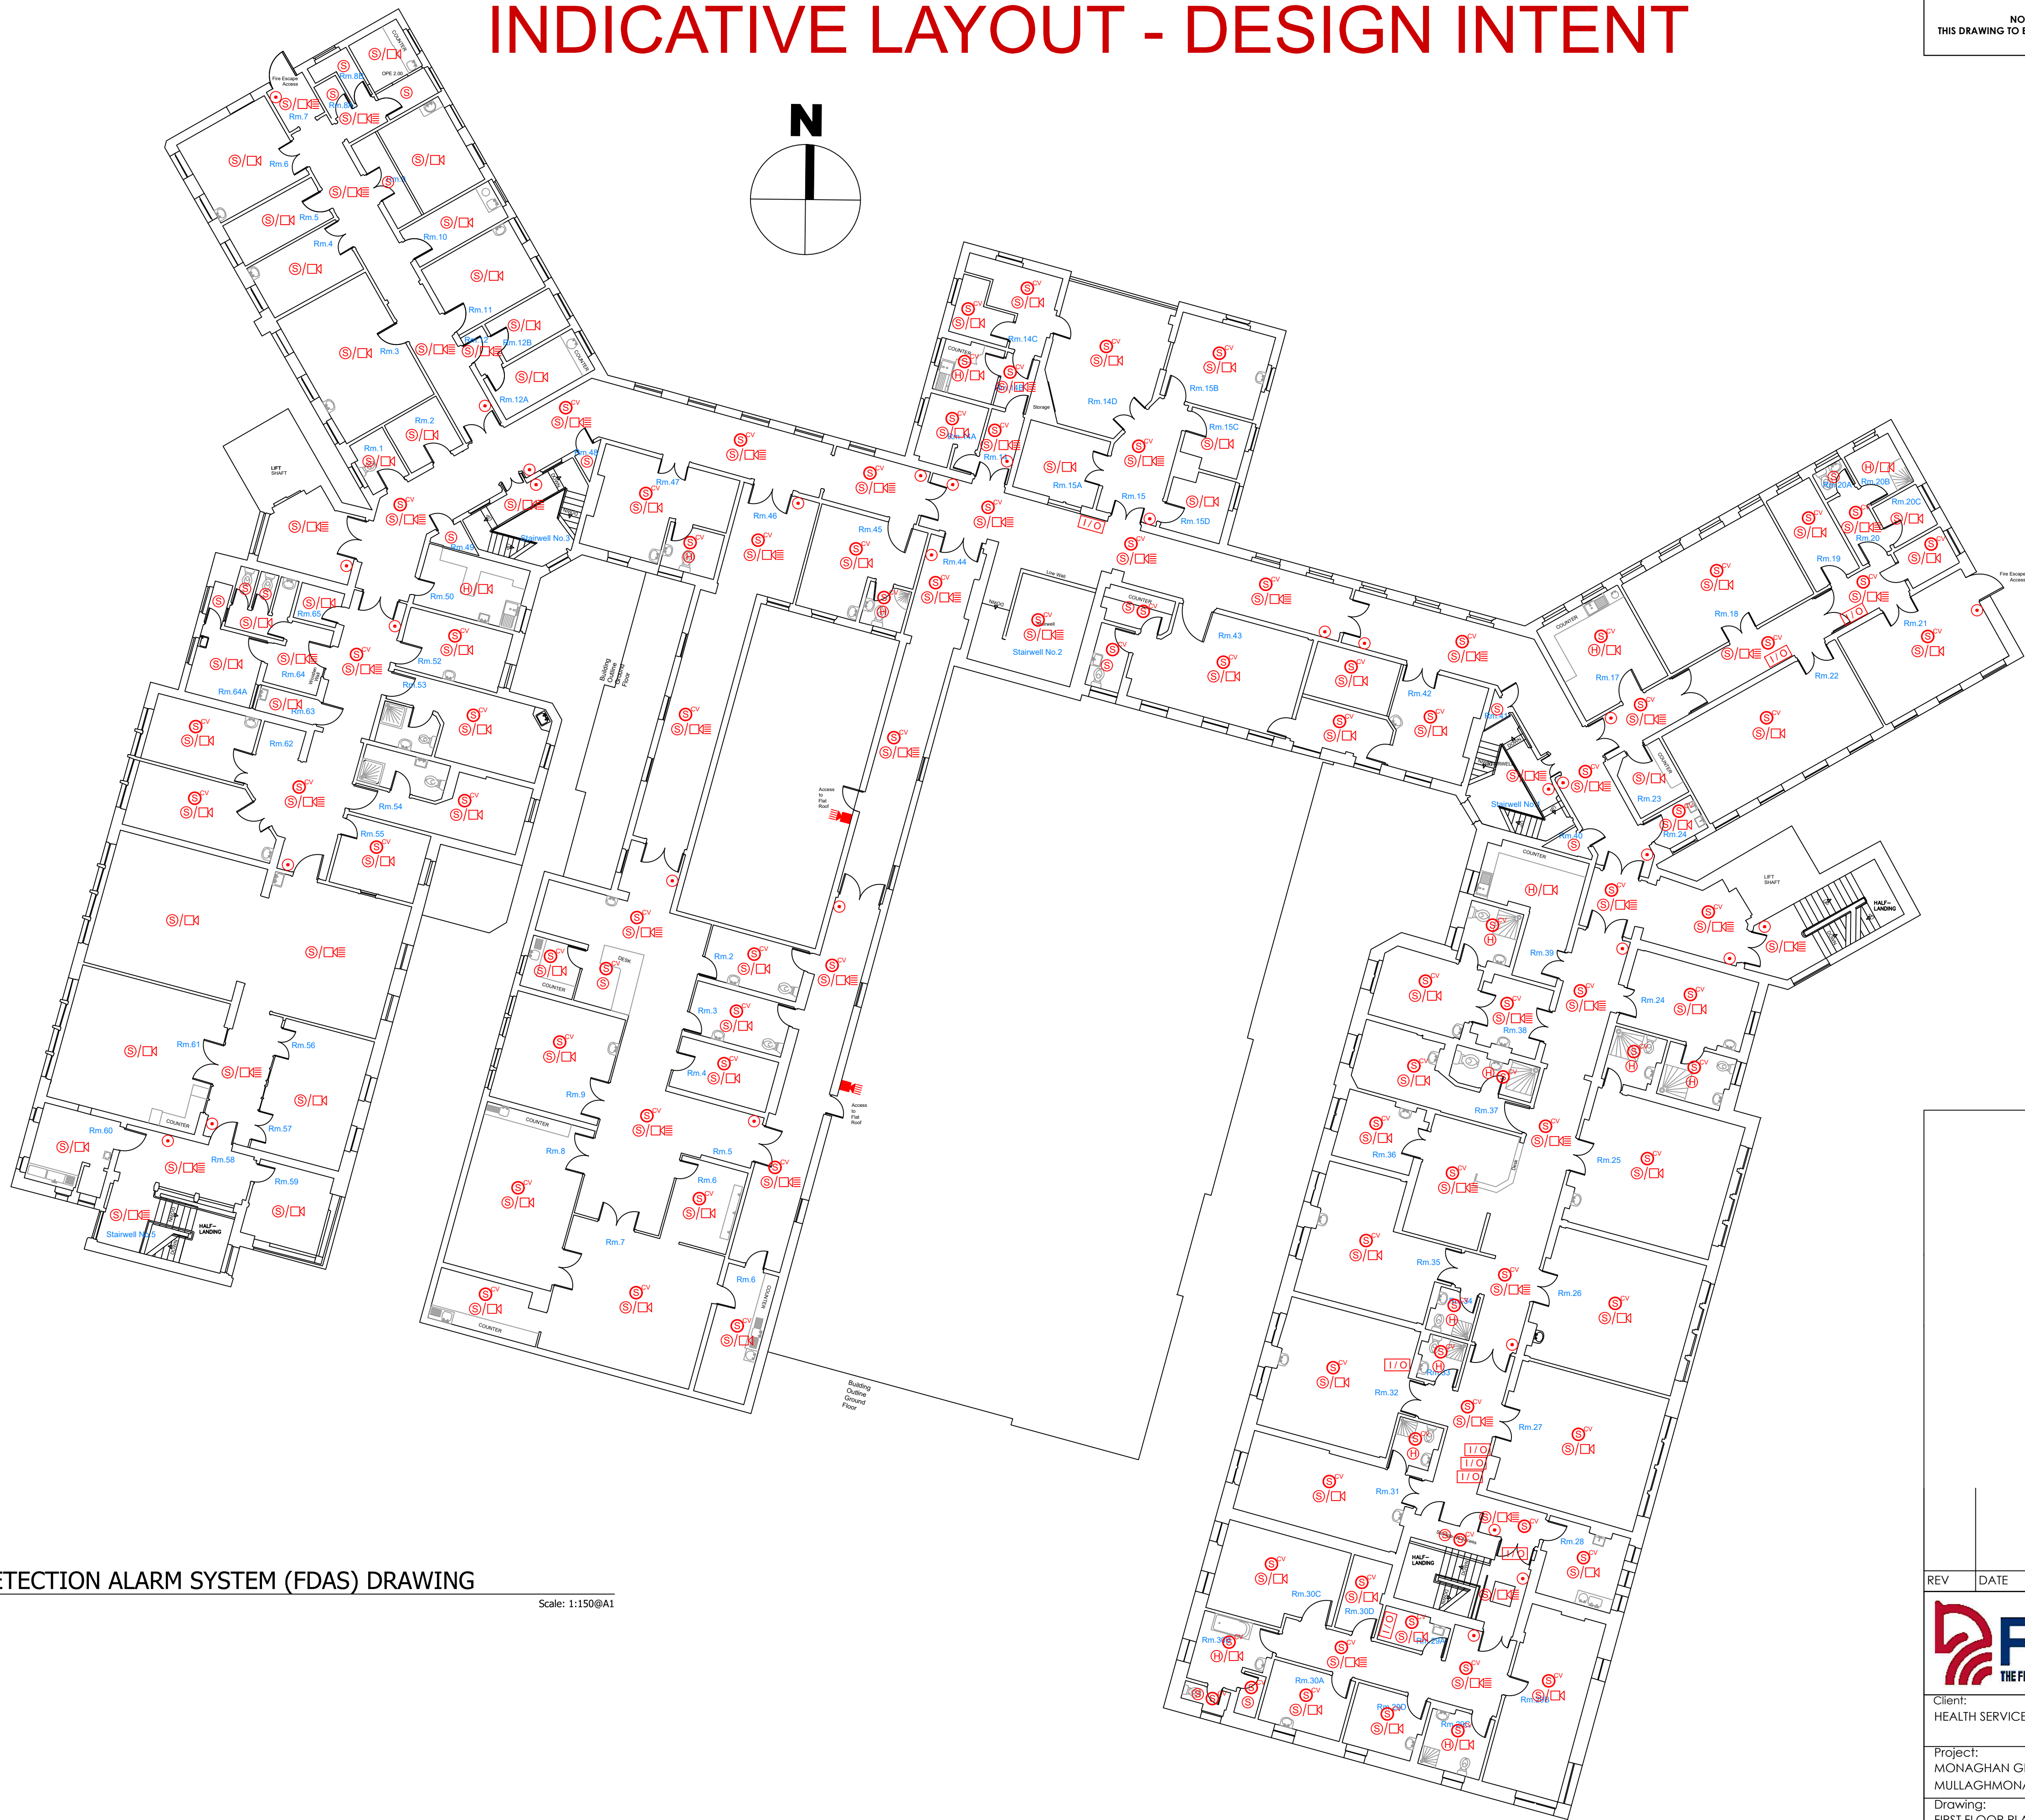

1 FIRST FLOOR PLAN - FIRE DETECTION ALARM SYSTEM (FDAS) DRAWING

Scale: 1:150@A1

- Legend:
- MANUAL CALL POINT
 - SMOKE DETECTOR
 - SMOKE DETECTOR / SOUNDER
 - SMOKE DETECTOR / SOUNDER / BEACON
 - SMOKE DETECTOR IN CEILING VOID
 - HEAT DETECTOR
 - HEAT DETECTOR / SOUNDER
 - SMOKE DETECTOR / SOUNDER / BEACON
 - SMOKE DETECTOR / SOUNDER / BEACON
 - INTERFACE UNIT
 - FIRE ALARM PANEL

REV	DATE	ITEM
FCC THE FIRE SAFETY ENGINEERS Unit A4, Nutgrove Office Park, Rathfarnham, Dublin 14, D14 H1X4 ph +353 (0)1 443 0013 fc +353 (0)1 443 0014 info@fire-cert.com www.fire-cert.com Client: HEALTH SERVICE EXECUTIVE HE Health Service Executive		
Project: MONAGHAN GENERAL HOSPITAL MULLAGHMONAGHAN, MONAGHAN, H18 NV91		
Drawing: FIRST FLOOR PLAN FIRE DETECTION ALARM SYSTEM (FDAS) TENDER DRAWING		
Scale(s): 1:150	Date: Sept '26	Drawn: SB
Checked: SM	Project No. 26045	Status Code: S13
Dwg: 26045-XX-L01-DR-FCC-FS-3002		Rev: Sheet: A1
Status: For Tender		Stage: 3