


BUILDING 1

INDICATIVE LAYOUT - DESIGN INTENT

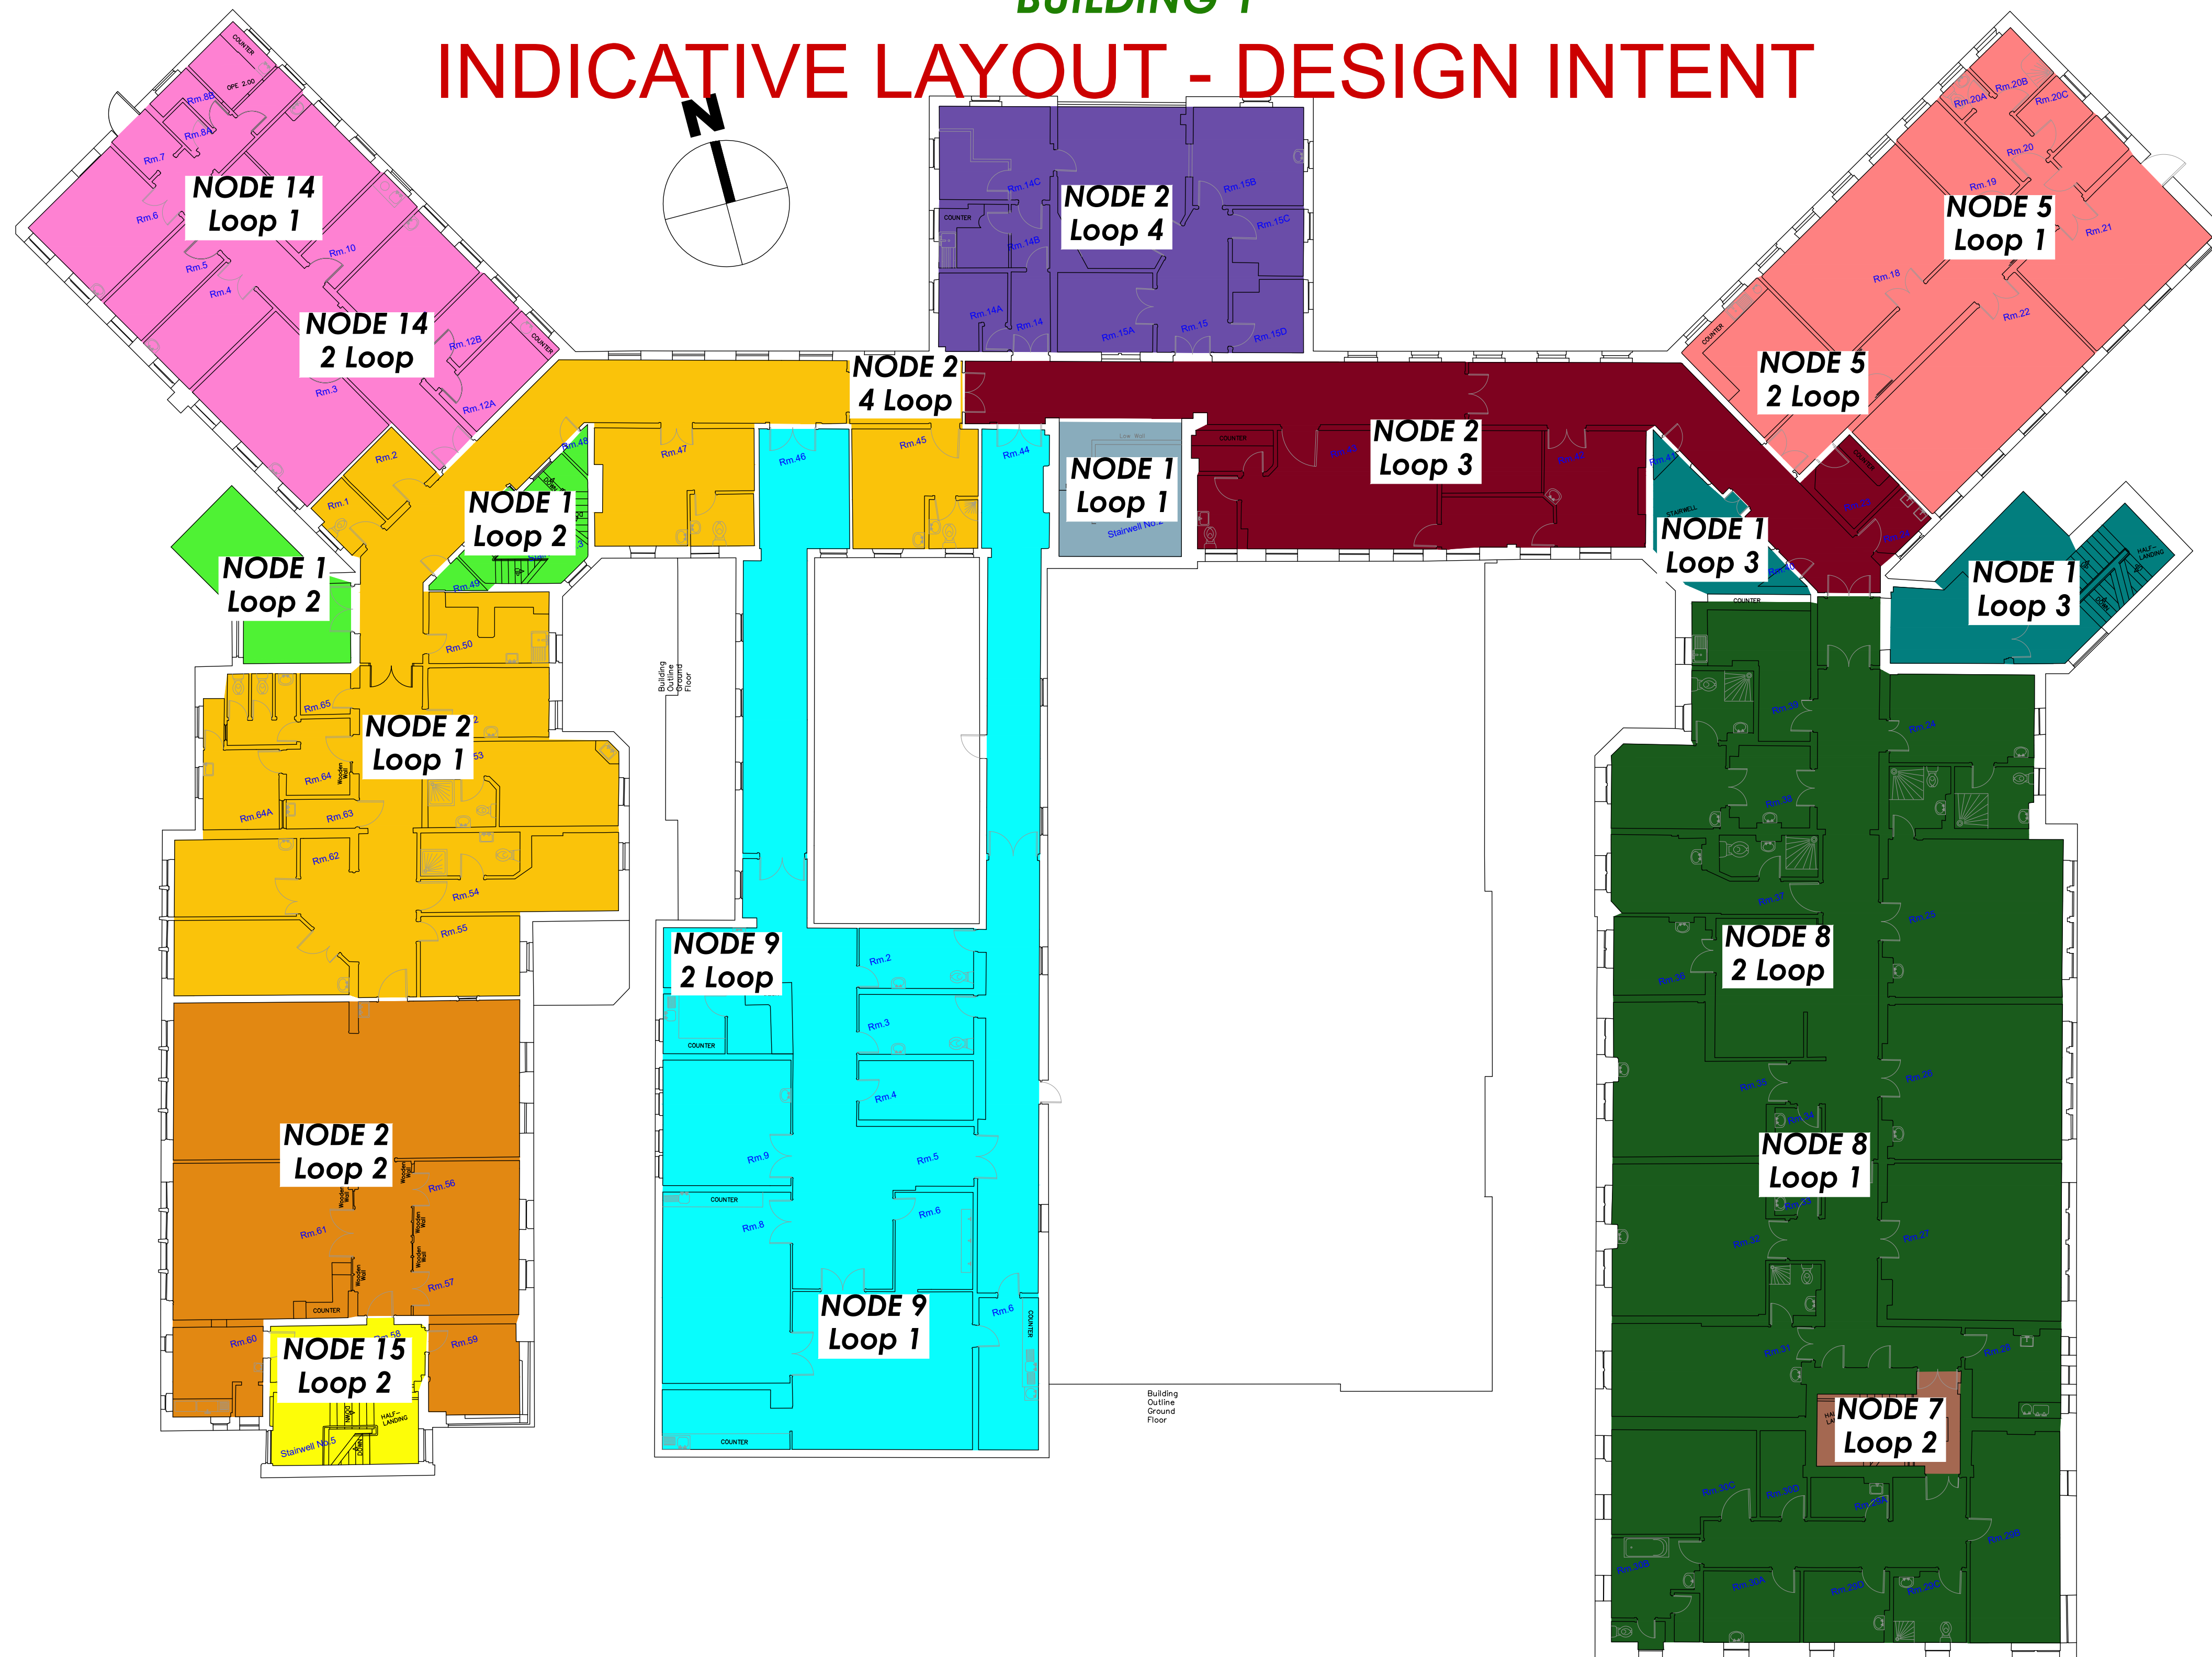

1 FIRST FLOOR PLAN - FIRE ALARM PANEL & NODES (FAP) DRAWING

Scale: 1:150@A1

NOTES

ALL DIMENSIONS TO BE CHECKED ON SITE
NO DIMENSIONS TO BE SCALED FROM THIS DRAWING
THIS DRAWING TO BE READ IN CONJUNCTION WITH FIRE CERT CONSULTANTS' WRITTEN SUBMISSION

REV	DATE	ITEM
FCC THE FIRE SAFETY ENGINEERS Unit A4, Nutgrove Office Park, Rathfarnham, Dublin 14, D14 H1X4 ph +353 (0)1 663 0013 fc +353 (0)1 663 0014 info@fire-cert.com www.fire-cert.com		
Client: HEALTH SERVICE EXECUTIVE		 páirtíomhartha na Seirbhíse Sláinte Health Service Executive
Project: MONAGHAN GENERAL HOSPITAL MULLAGHMONAGHAN, MONAGHAN, H18 NV91		
Drawing: FIRST FLOOR PLAN FIRE ALARM PANEL & NODES (FAP) TENDER DRAWING		
Scale(s): 1:150	Date: Sept '26	Drawn: ApT
		Checked: SM
		Project No. 26045
		Status Code S13
Dwg: 26045-XX-L01-DR-FCC-FS-6002		Rev:
Status: For Tender		Sheet: A1
		Stage: 3