


INDICATIVE LAYOUT - DESIGN INTENT



NOTES

ALL DIMENSIONS TO BE CHECKED ON SITE
NO DIMENSIONS TO BE SCALED FROM THIS DRAWING
THIS DRAWING TO BE READ IN CONJUNCTION WITH FIRE CERT CONSULTANTS' WRITTEN SUBMISSION

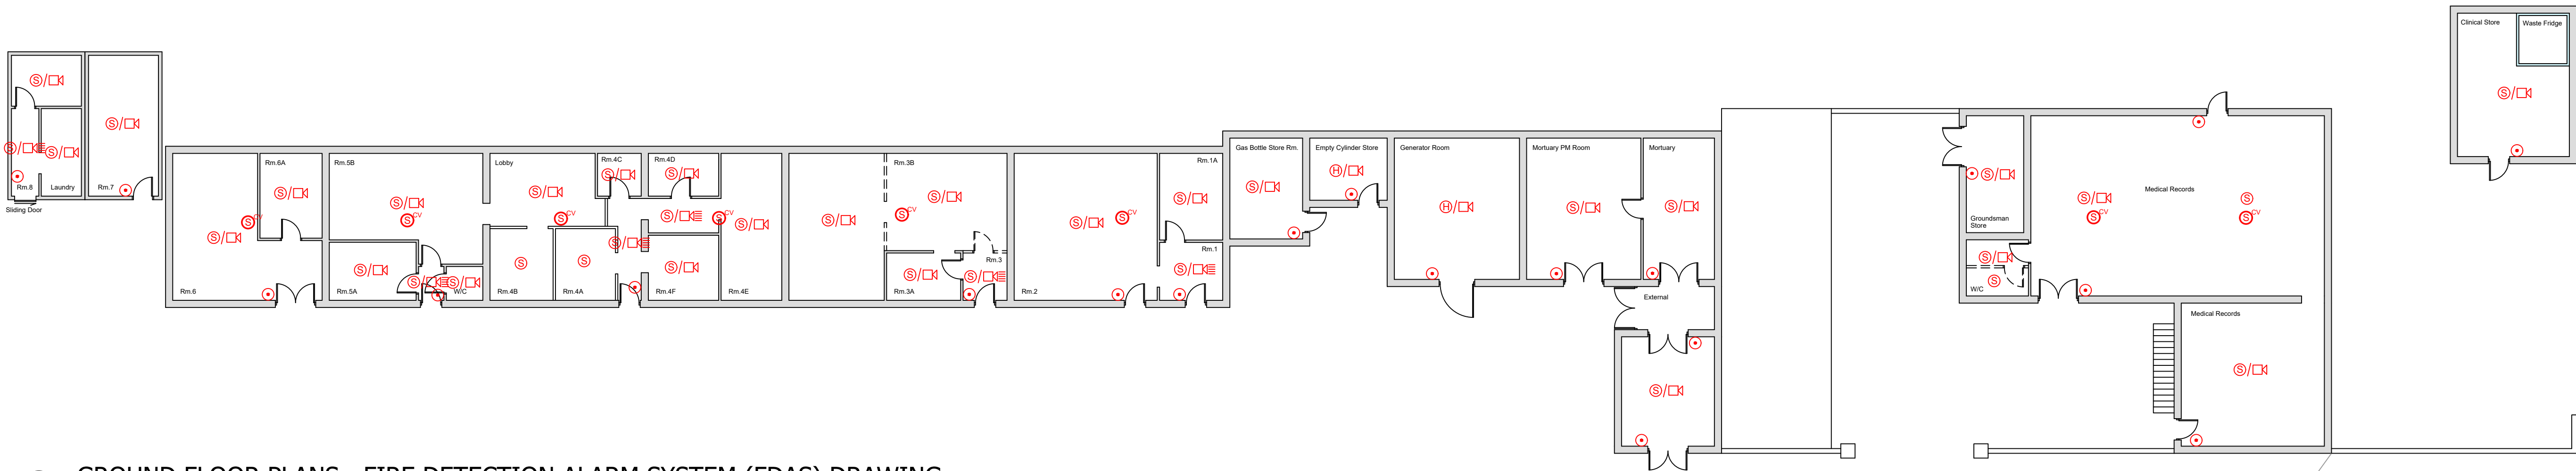

1 GROUND FLOOR PLANS - FIRE DETECTION ALARM SYSTEM (FDAS) DRAWING

Scale: 1:150@A1

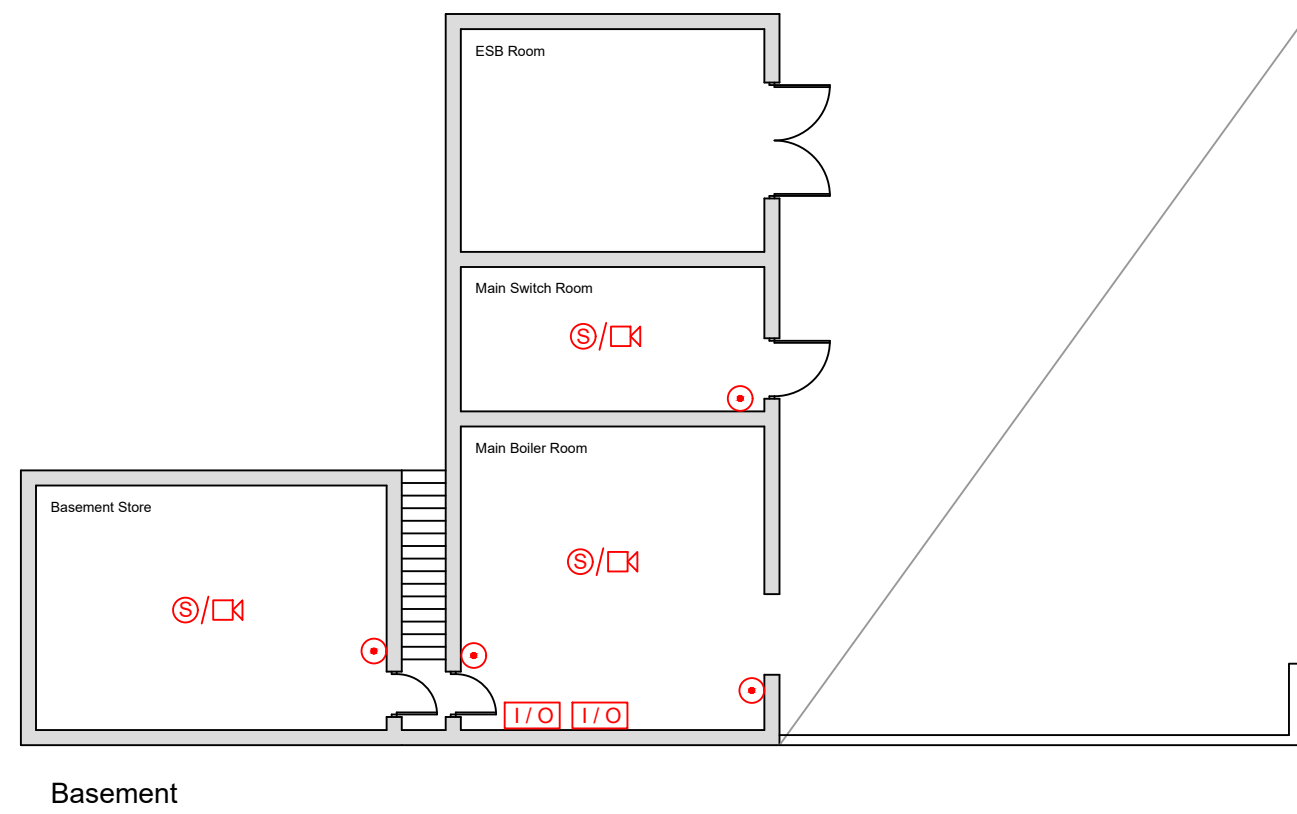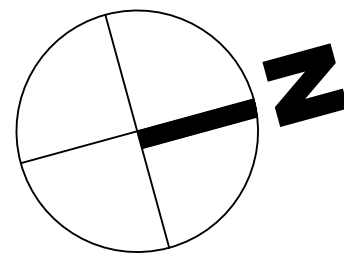

2 OUTBUILDINGS BASEMENT FLOOR PLAN - FIRE DETECTION ALARM SYSTEM (FDAS)

Scale: 1:150@A1

Legend:

- MANUAL CALL POINT
- SMOKE DETECTOR
- SMOKE DETECTOR / SOUNDER
- SMOKE DETECTOR / SOUNDER / BEACON
- SMOKE DETECTOR IN CEILING VOID
- HEAT DETECTOR
- HEAT DETECTOR / SOUNDER
- SMOKE DETECTOR / SOUNDER / BEACON
- SMOKE DETECTOR / SOUNDER / BEACON
- INTERFACE UNIT
- FIRE ALARM PANEL

REV	DATE	ITEM
 Unit A4, Nutgrove Office Park, Rathfarnham, Dublin 14, D14 H1X4 ph +353 (0)1 663 0013 fc +353 (0)1 663 0014 info@fire-cert.com www.fire-cert.com Client: HEALTH SERVICE EXECUTIVE Project: MONAGHAN GENERAL HOSPITAL MULLAGHMONAGHAN, MONAGHAN, H18 NV91 Drawing: OUTBUILDINGS GROUND & BASEMENT FLOOR PLANS FIRE DETECTION ALARM SYSTEM (FDAS) TENDER DRAWING Scale(s): 1:150 Date: Sept '26 Drawn: SB Checked: SM Project No. 26045 Status Code: S13 Dwg: 26045-XX-ZZZ-DR-FCC-FS-3004 Rev: Sheet: A1 Status: For Tender Stage: 3		