


NOTES

ALL DIMENSIONS TO BE CHECKED ON SITE
NO DIMENSIONS TO BE SCALED FROM THIS DRAWING
THIS DRAWING TO BE READ IN CONJUNCTION WITH FIRE CERT CONSULTANTS' WRITTEN SUBMISSION

INDICATIVE LAYOUT - DESIGN INTENT

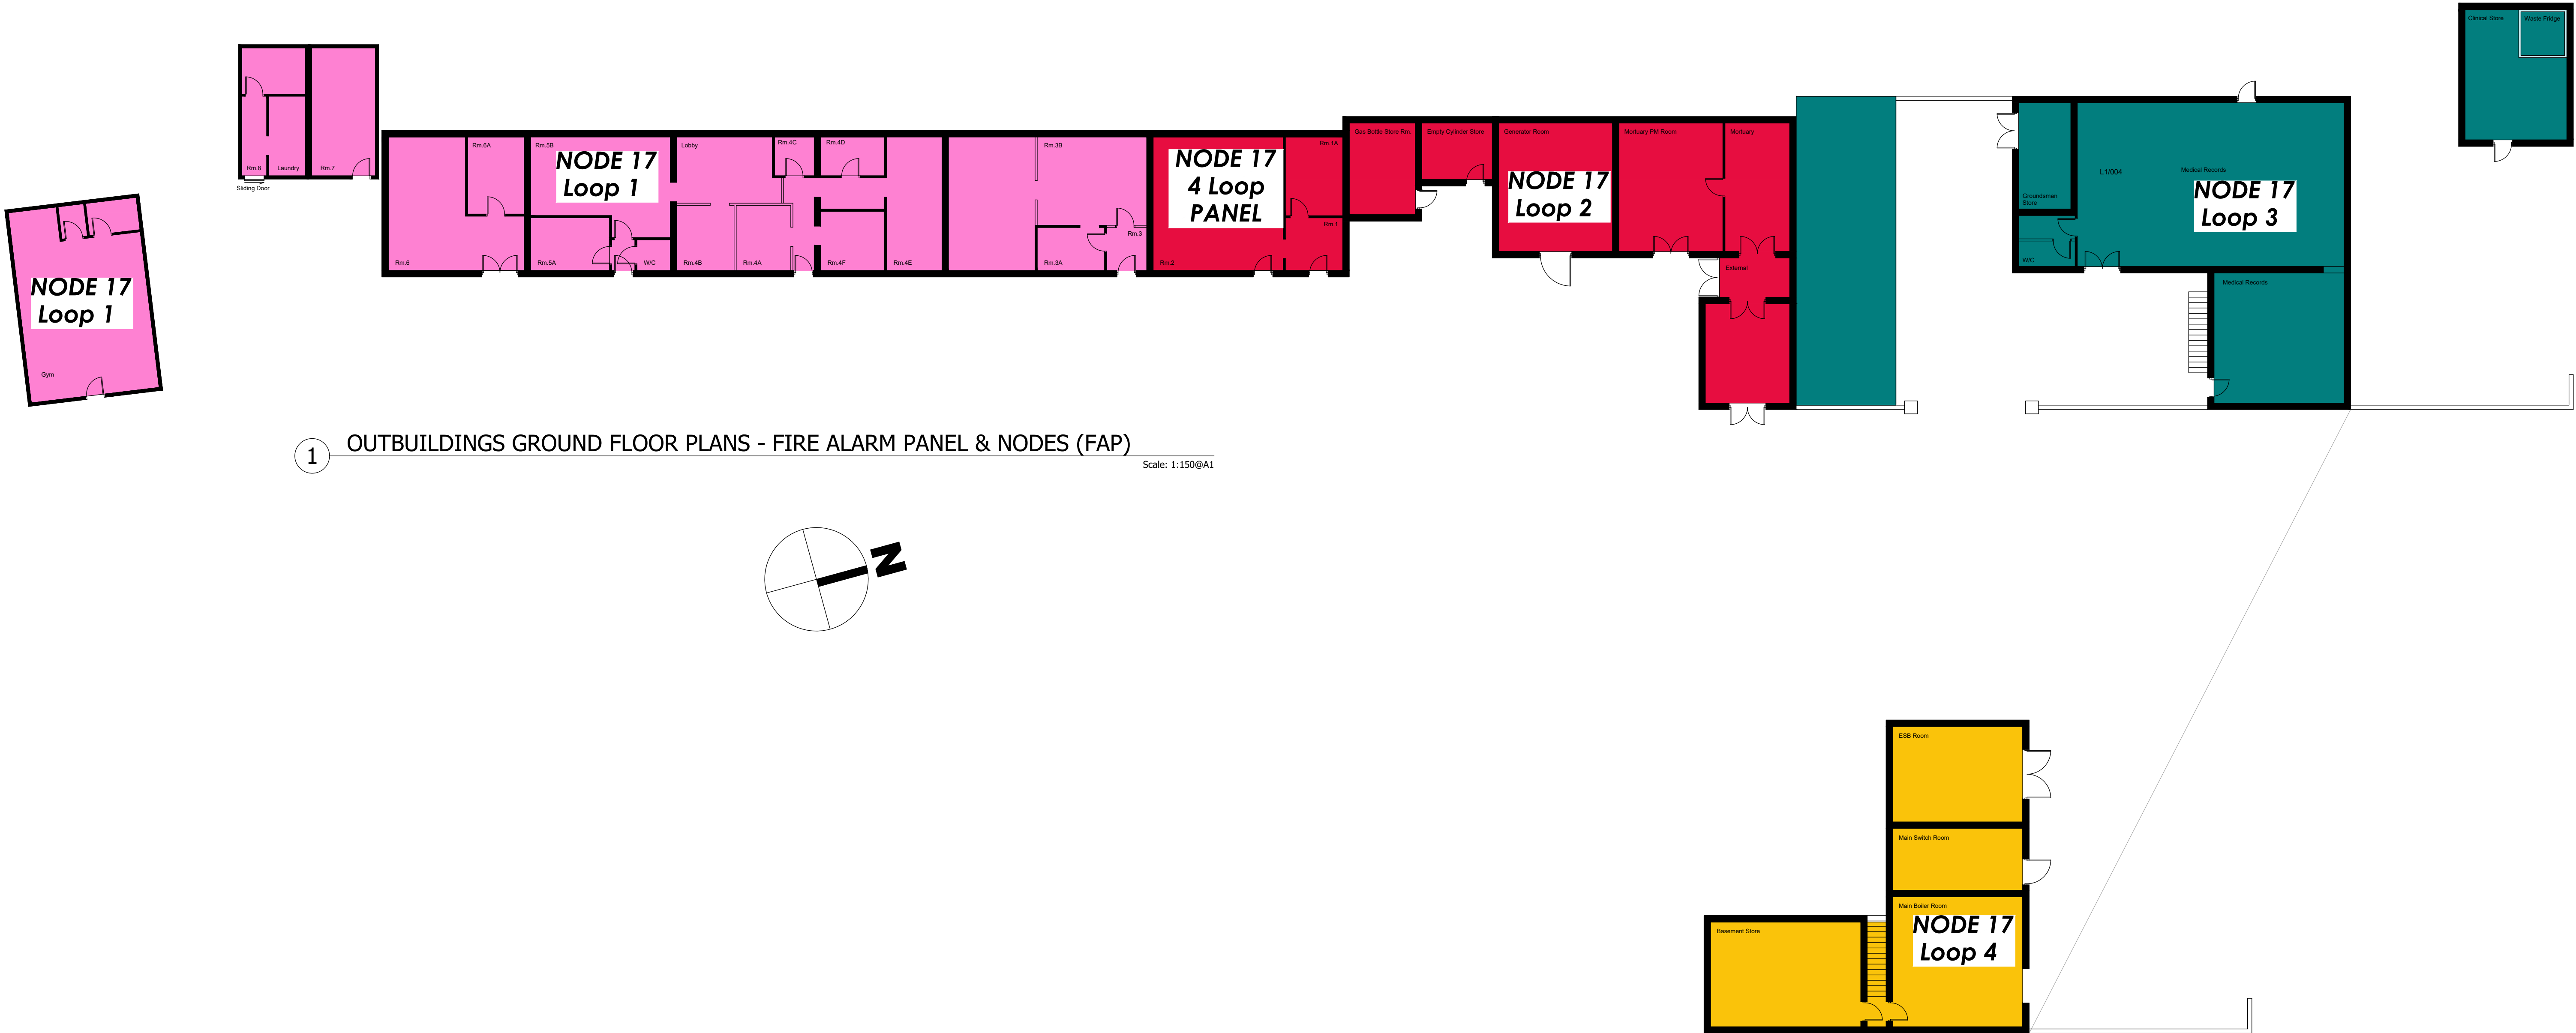

1 OUTBUILDINGS GROUND FLOOR PLANS - FIRE ALARM PANEL & NODES (FAP) Scale: 1:150@A1

2 OUTBUILDINGS BASEMENT FLOOR PLAN - FIRE ALARM PANEL & NODES (FAP) Scale: 1:150@A1

REV	DATE	ITEM
 FCC THE FIRE SAFETY ENGINEERS Unit A4, Nutgrove Office Park, Rathfarnham, Dublin 14, D14 H1X4 ph: +353 (0)1 663 0013 fc: +353 (0)1 663 0014 info@fire-cert.com www.fire-cert.com		
Client: HEALTH SERVICE EXECUTIVE		 Heilbrunnstraße 20, 50818 Köln, Germany Health Service Executive
Project: MONAGHAN GENERAL HOSPITAL MULLAGHMONAGHAN, MONAGHAN, H18 NV91		
Drawing: OUTBUILDINGS FLOOR PLANS FIRE ALARM PANELS & NODES (FAP) TENDER DRAWING		
Scale(s): 1:150	Date: Sept '26	Drawn: ApT
		Checked: SM
		Project No. 26045
		Status Code: S13
Dwg: 26045-XX-ZZZ-DR-FCC-FS-6004		Rev:
		Sheet: A1
Status: For Tender		Stage: 3