


INDICATIVE LAYOUT - DESIGN INTENT

NOTES
ALL DIMENSIONS TO BE CHECKED ON SITE
NO DIMENSIONS TO BE SCALED FROM THIS DRAWING
THIS DRAWING TO BE READ IN CONJUNCTION WITH FIRE CERT CONSULTANTS' WRITTEN SUBMISSION

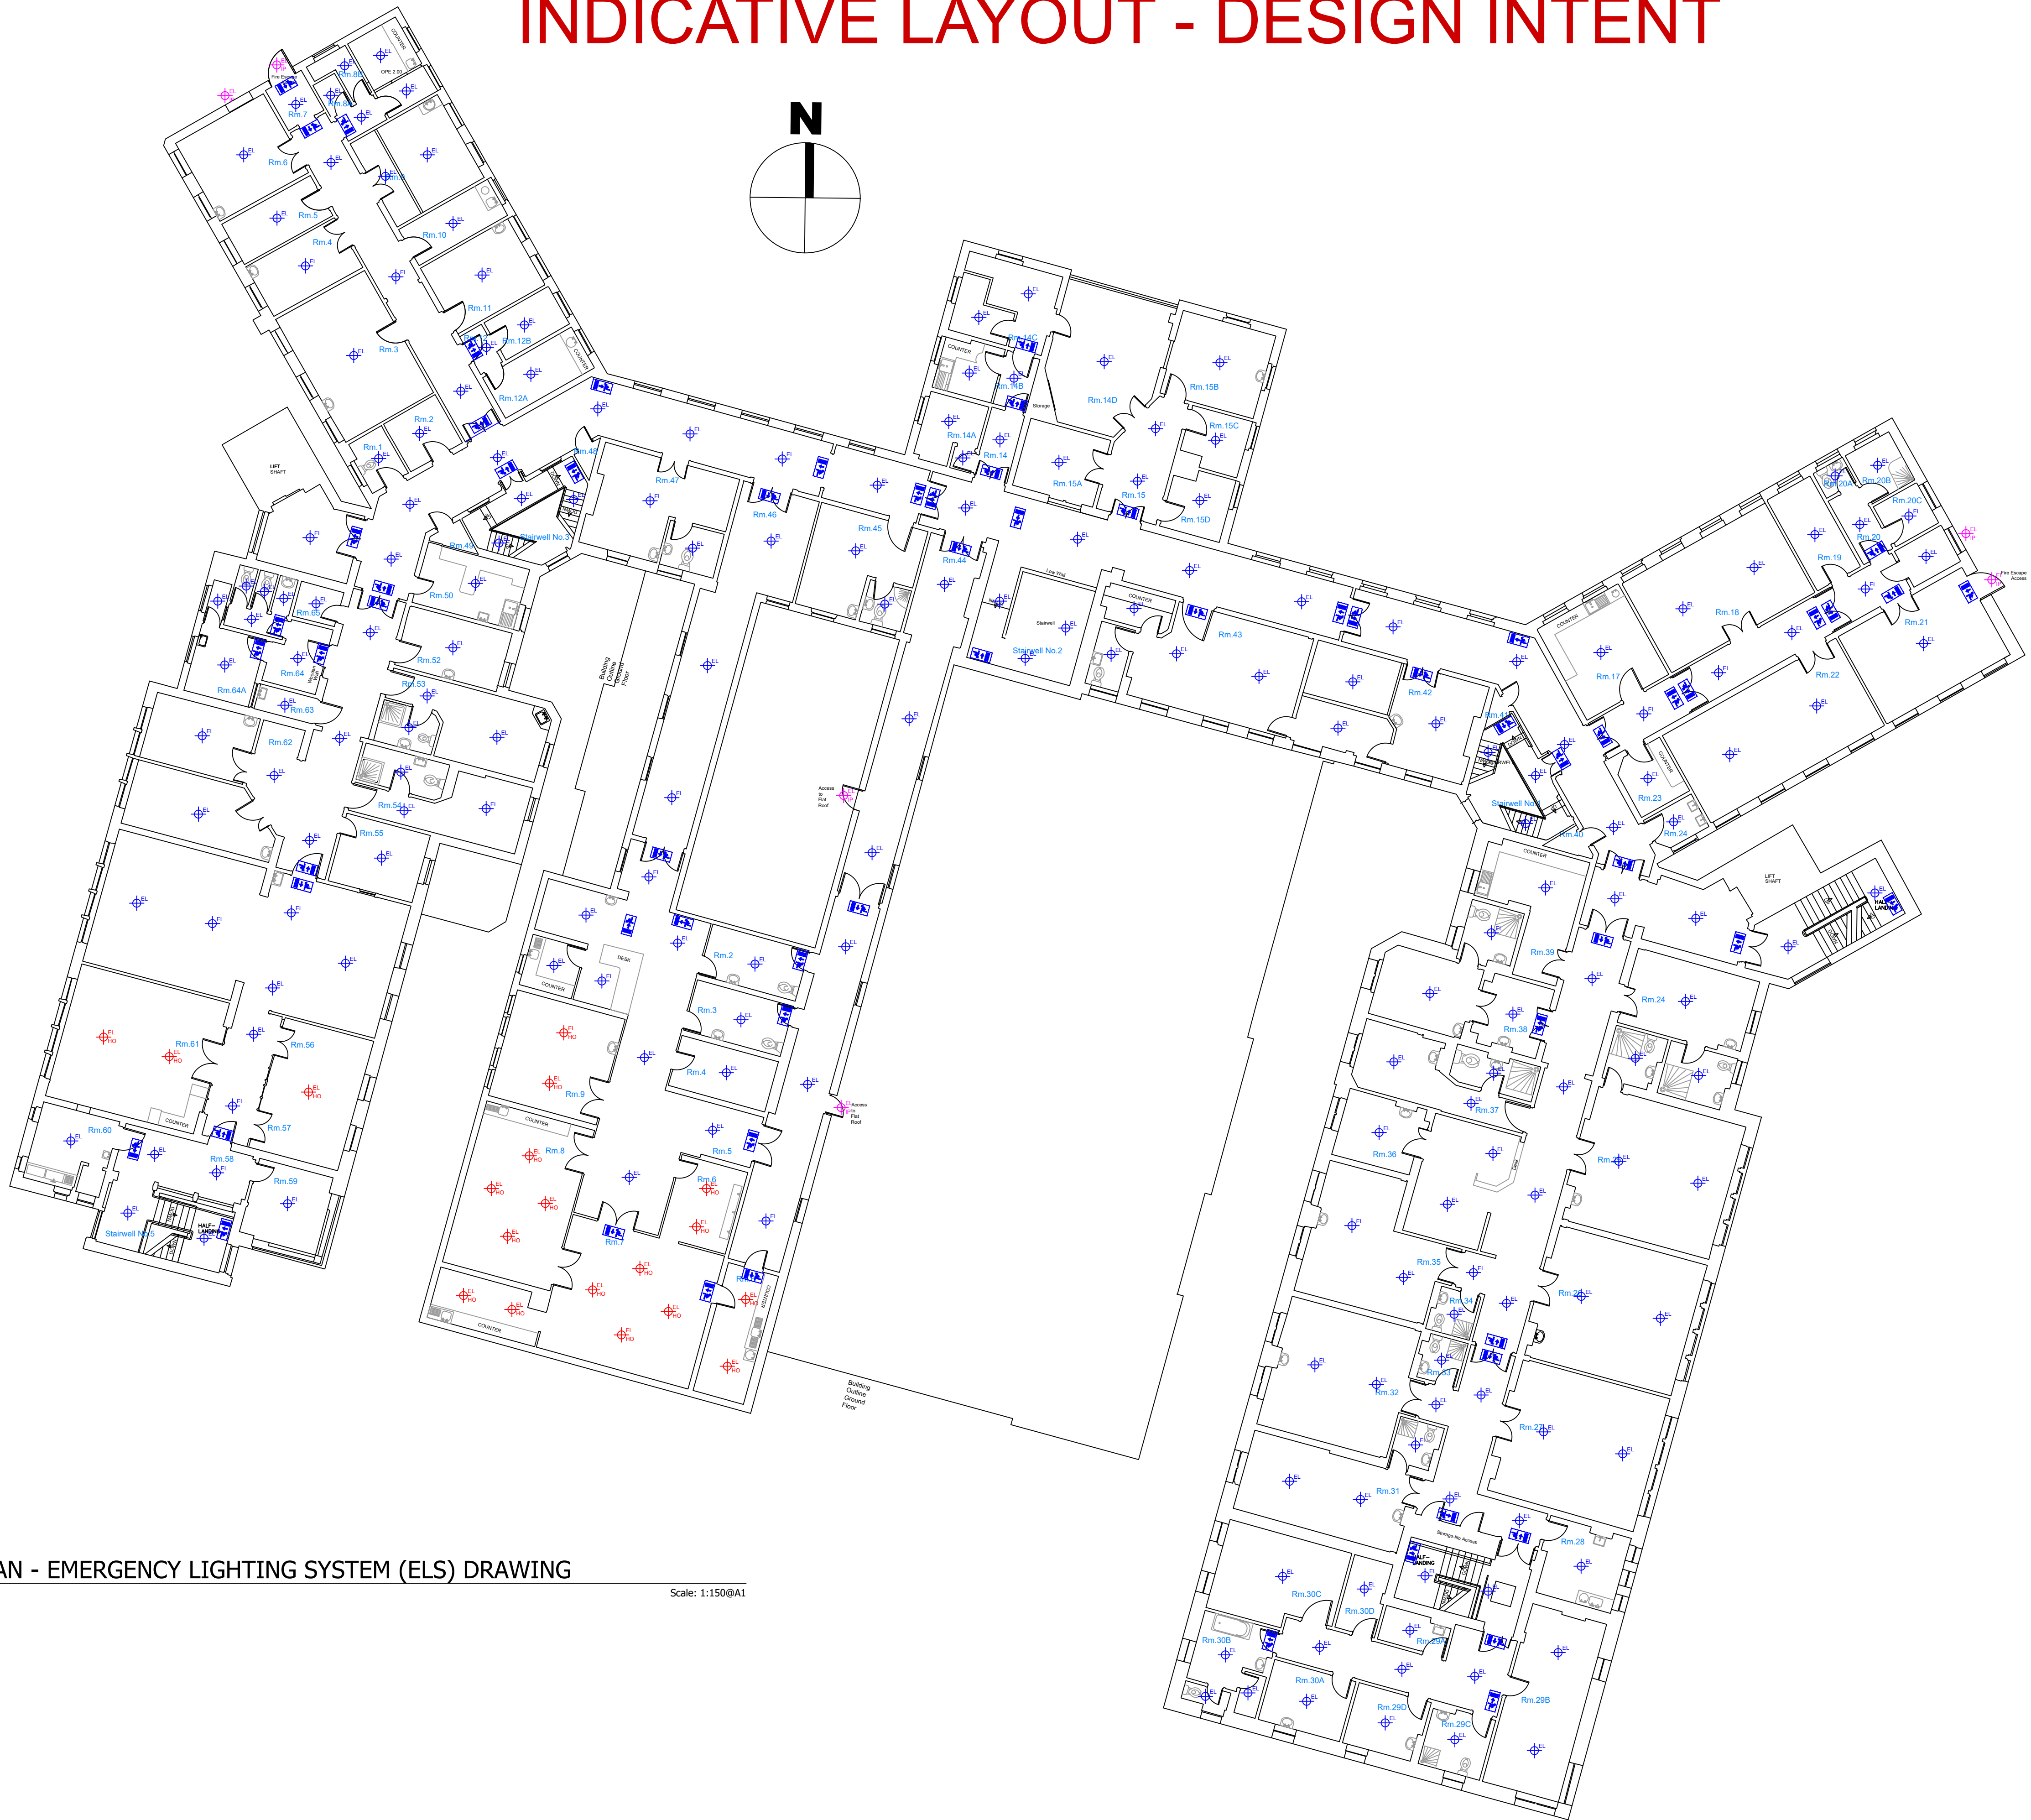

1 FIRST FLOOR PLAN - EMERGENCY LIGHTING SYSTEM (ELS) DRAWING

Scale: 1:150@A1

Legend

-  DIRECTIONAL EXIT SIGN
-  BULK HEAD
-  IP RATED FITTING
-  IP RATED FITTING

REV	DATE	ITEM
-----	------	------

	Unit A4, Nutgrove Office Park, Rathfarnham, Dublin 14, D14 H1X4 ph: +353 (0)1 443 0013 fc: +353 (0)1 663 0014 info@fire-cert.com www.fire-cert.com
---	---

Client: HEALTH SERVICE EXECUTIVE	
-------------------------------------	---

Project: MONAGHAN GENERAL HOSPITAL MULLAGHMONAGHAN, MONAGHAN, H18 NV91
--

Drawing: FIRST FLOOR PLAN EMERGENCY LIGHTING SYSTEM (ELS) TENDER DRAWING
--

Scale(s): 1:150	Date: Sept '26	Drawn: SB	Checked: SM	Project No. 26045	Status Code: S13
--------------------	-------------------	--------------	----------------	----------------------	---------------------

Dwg: 26045-XX-L01-DR-FCC-FS-4002	Rev:	Sheet: A1
----------------------------------	------	-----------

Status: For Tender	Stage: 3
--------------------	----------