


INDICATIVE LAYOUT - DESIGN INTENT

NOTES
ALL DIMENSIONS TO BE CHECKED ON SITE
NO DIMENSIONS TO BE SCALED FROM THIS DRAWING
THIS DRAWING TO BE READ IN CONJUNCTION WITH FIRE CERT CONSULTANTS' WRITTEN SUBMISSION

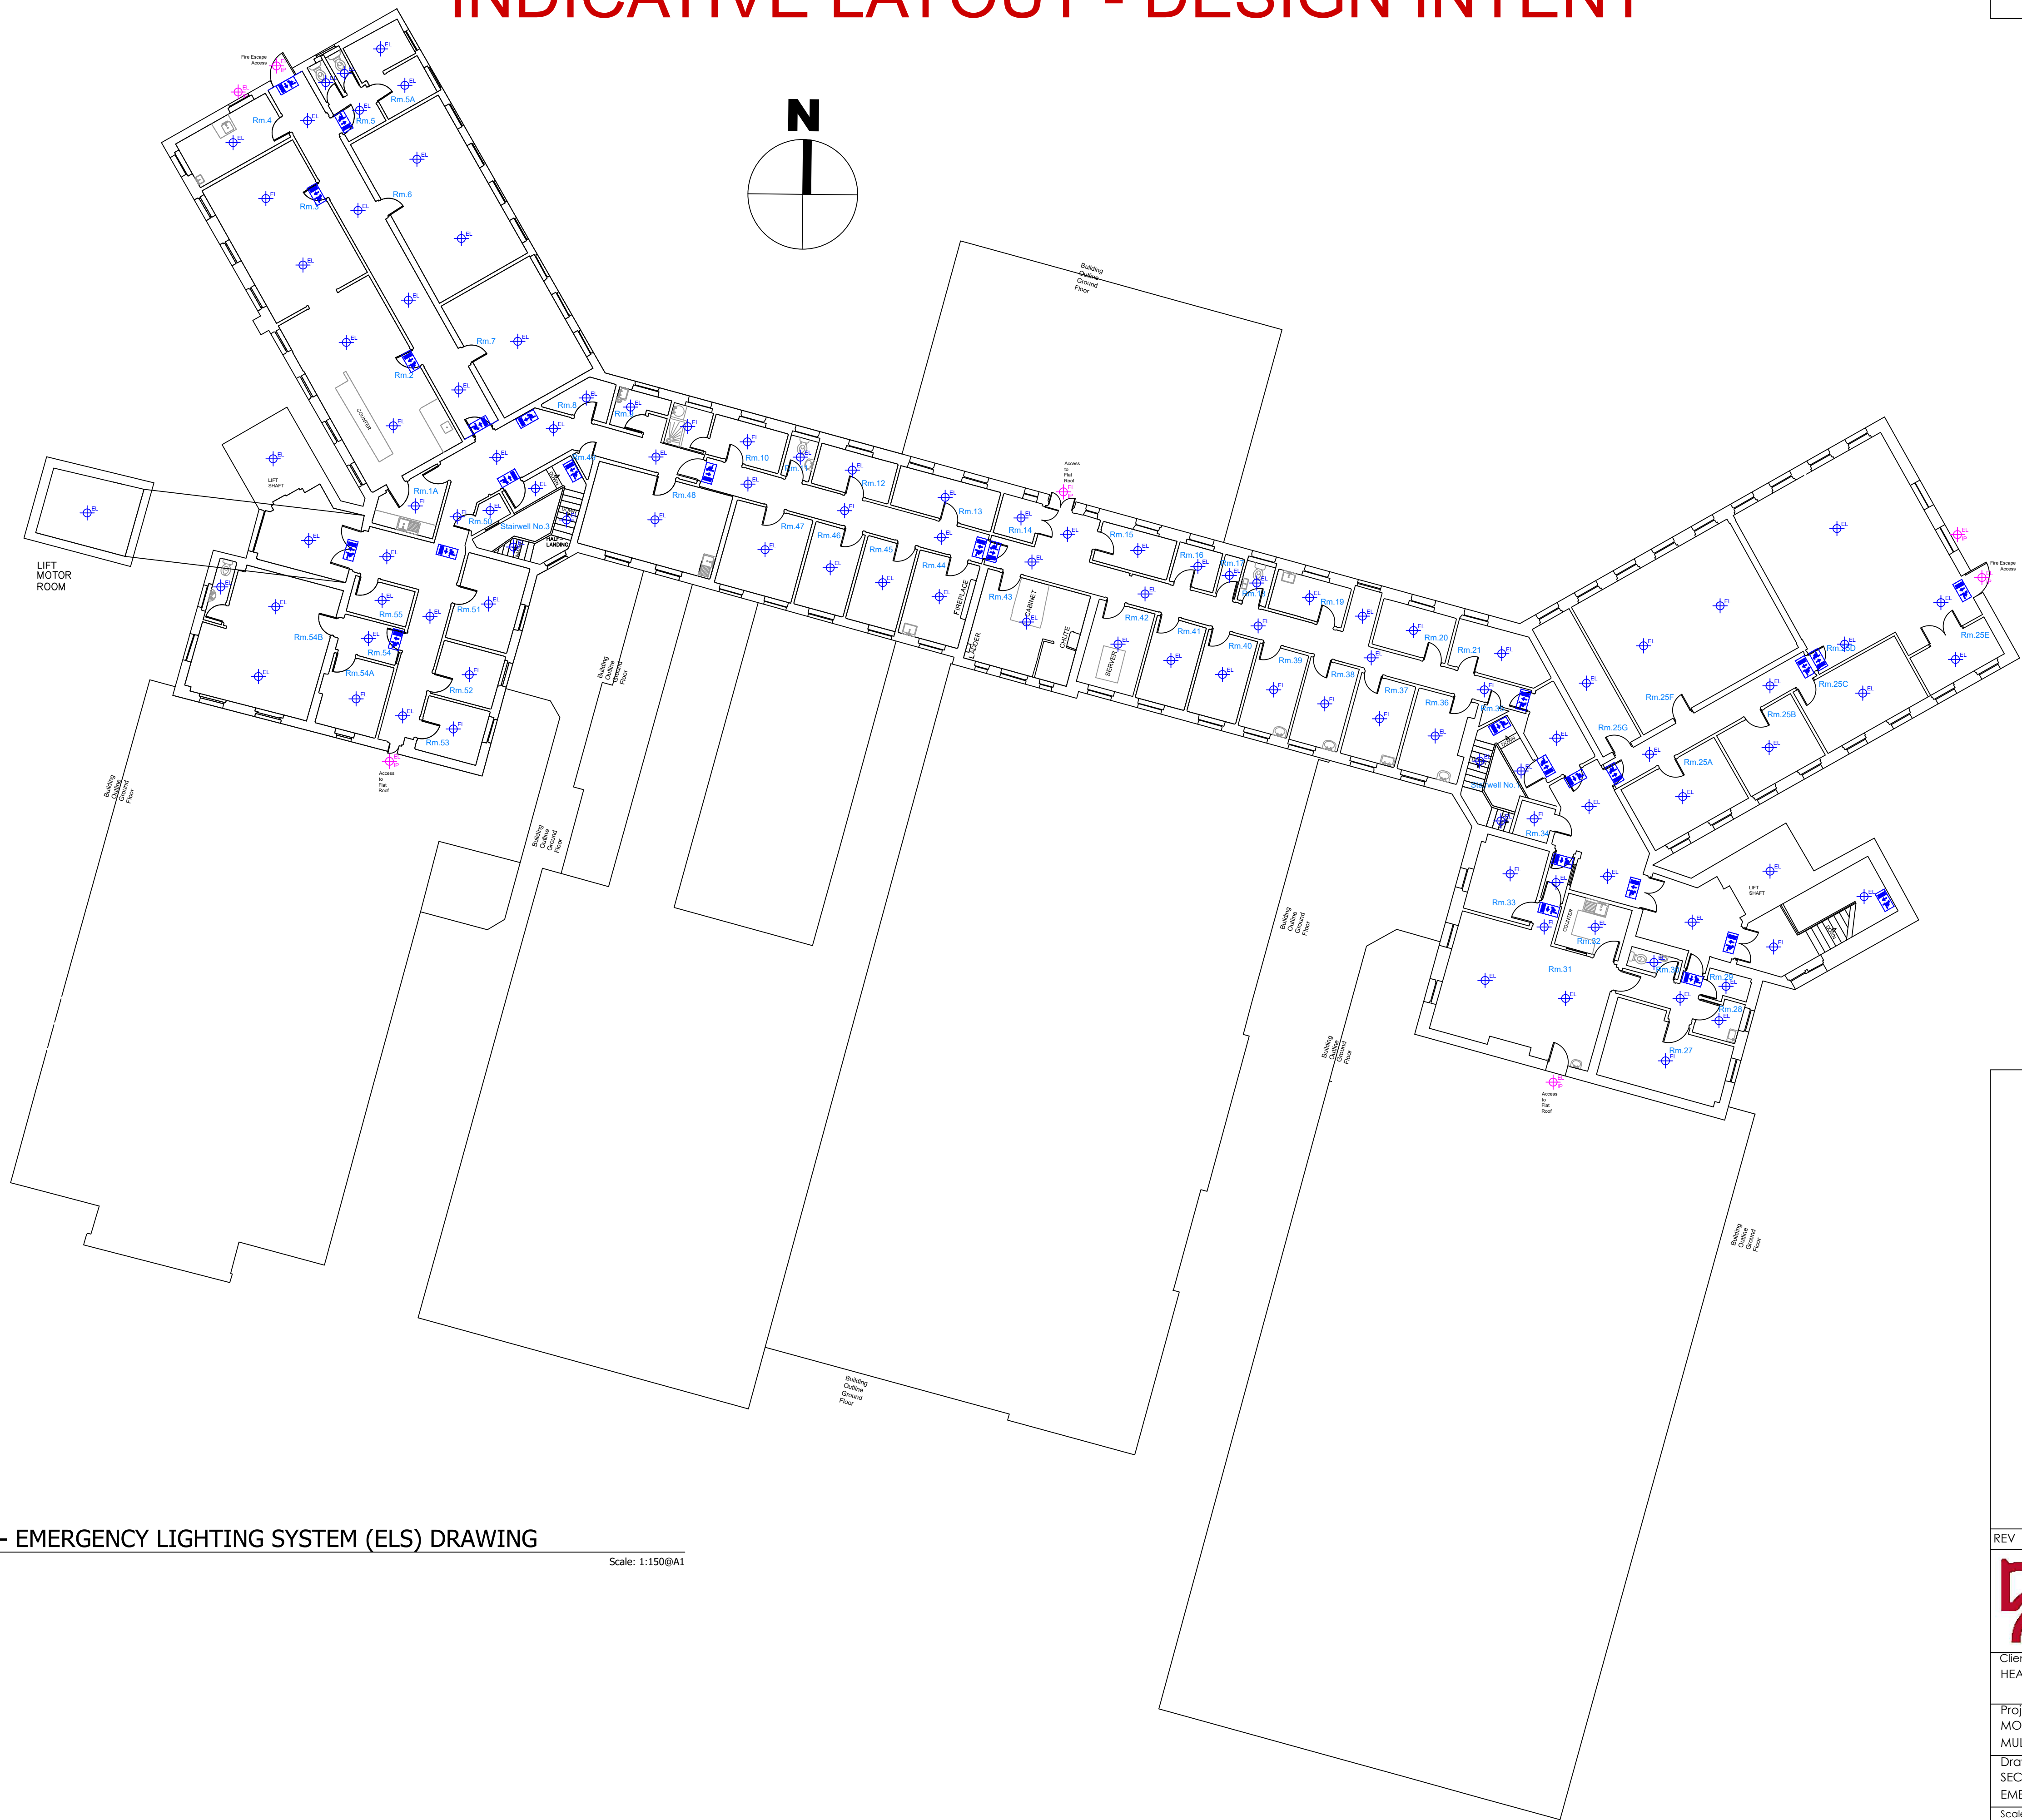

1 SECOND FLOOR PLAN - EMERGENCY LIGHTING SYSTEM (ELS) DRAWING

Scale: 1:150@A1

Legend

- DIRECTIONAL EXIT SIGN
- BULK HEAD
- IP RATED FITTING
- IP RATED FITTING

REV	DATE	ITEM
-----	------	------



Unit A4, Nutgrove Office Park,
Rathfarnham, Dublin 14, D14 H1X4
ph +353 (0)1 663 0013 | fc +353 (0)1 663 0014
info@fire-cert.com | www.fire-cert.com

Client:
HEALTH SERVICE EXECUTIVE



Project:
MONAGHAN GENERAL HOSPITAL
MULLAGHMONAGHAN, MONAGHAN, H18 NV91

Drawing:
SECOND FLOOR PLAN
EMERGENCY LIGHTING SYSTEM (ELS) TENDER DRAWING

Scale(s):	Date:	Drawn:	Checked:	Project No.	Status Code:
1:150	Sept '26	SB	SM	26045	S13

Dwg: 26045-XX-L02-DR-FCC-FS-4003

Status: For Tender

Stage: 3