

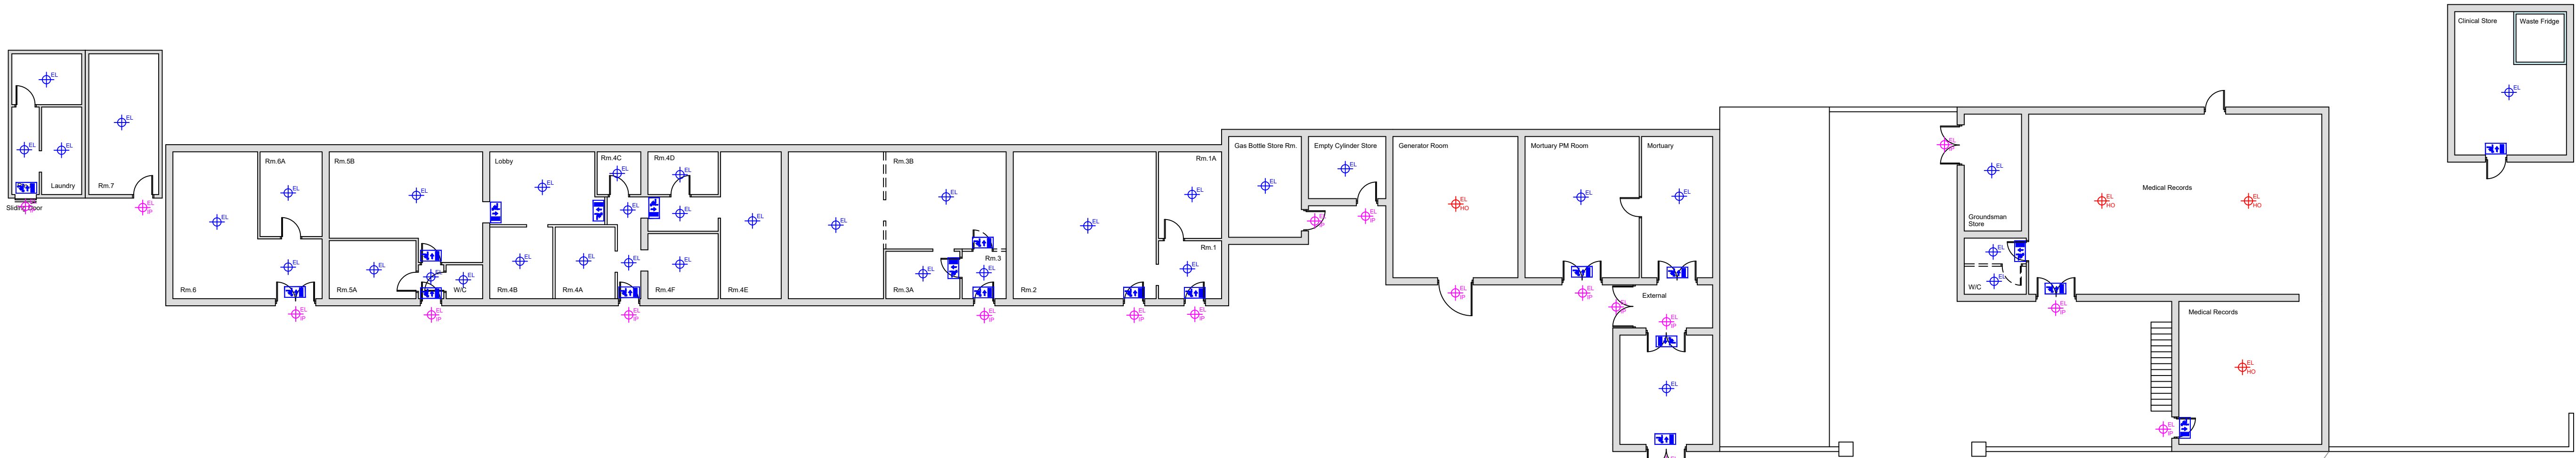


INDICATIVE LAYOUT - DESIGN INTENT

NOTES
ALL DIMENSIONS TO BE CHECKED ON SITE
NO DIMENSIONS TO BE SCALED FROM THIS DRAWING
THIS DRAWING TO BE READ IN CONJUNCTION WITH FIRE CERT CONSULTANTS' WRITTEN SUBMISSION

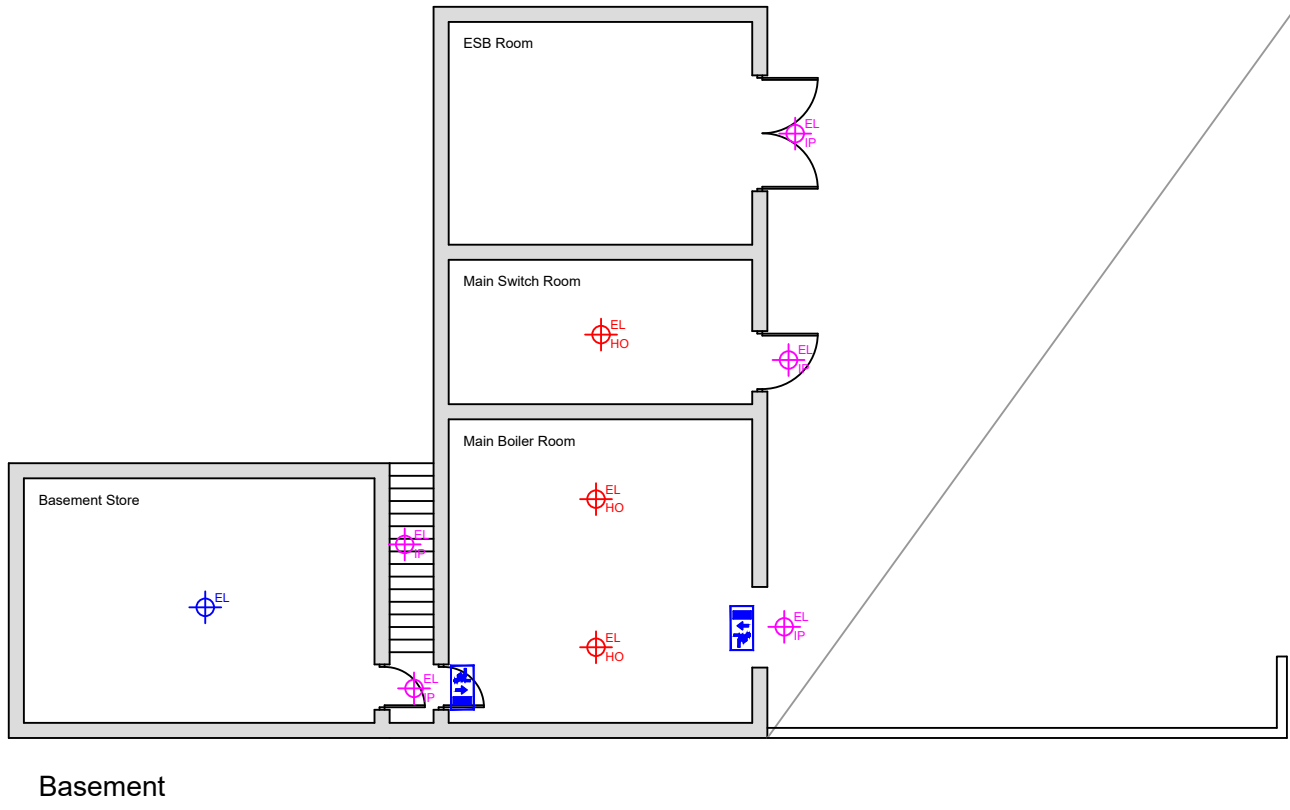

1 GROUND FLOOR PLANS - EMERGENCY LIGHTING SYSTEM (ELS) DRAWING
Scale: 1:150@A1

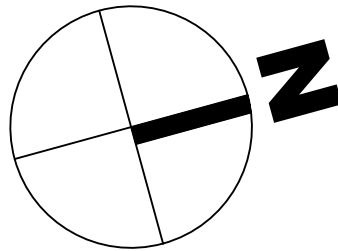

2 OUTBUILDINGS BASEMENT FLOOR PLAN - EMERGENCY LIGHTING SYSTEM (ELS)
Scale: 1:150@A1

- Legend
- DIRECTIONAL EXIT SIGN
 - BULK HEAD
 - IP RATED FITTING
 - IP RATED FITTING

REV	DATE	ITEM
 Unit A4, Nutgrove Office Park, Rathfarnham, Dublin 14, D14 H1X4 ph +353 (0)1 663 0013 fc +353 (0)1 663 0014 info@fire-cert.com www.fire-cert.com		
Client: HEALTH SERVICE EXECUTIVE		
Project: MONAGHAN GENERAL HOSPITAL MULLAGHMONAGHAN, MONAGHAN, H18 NV91		
Drawing: OUTBUILDINGS FLOOR PLANS EMERGENCY LIGHTING SYSTEM (ELS) TENDER DRAWING		
Scale(s): 1:150	Date: Sept '26	Drawn: SB
Checked: SM	Project No. 26045	Status Code: S13
Dwg: 26045-XX-ZZZ-DR-FCC-FS-4004		Rev: Sheet: A1
Status: For Tender		Stage: 3