



INDICATIVE LAYOUT - DESIGN INTENT

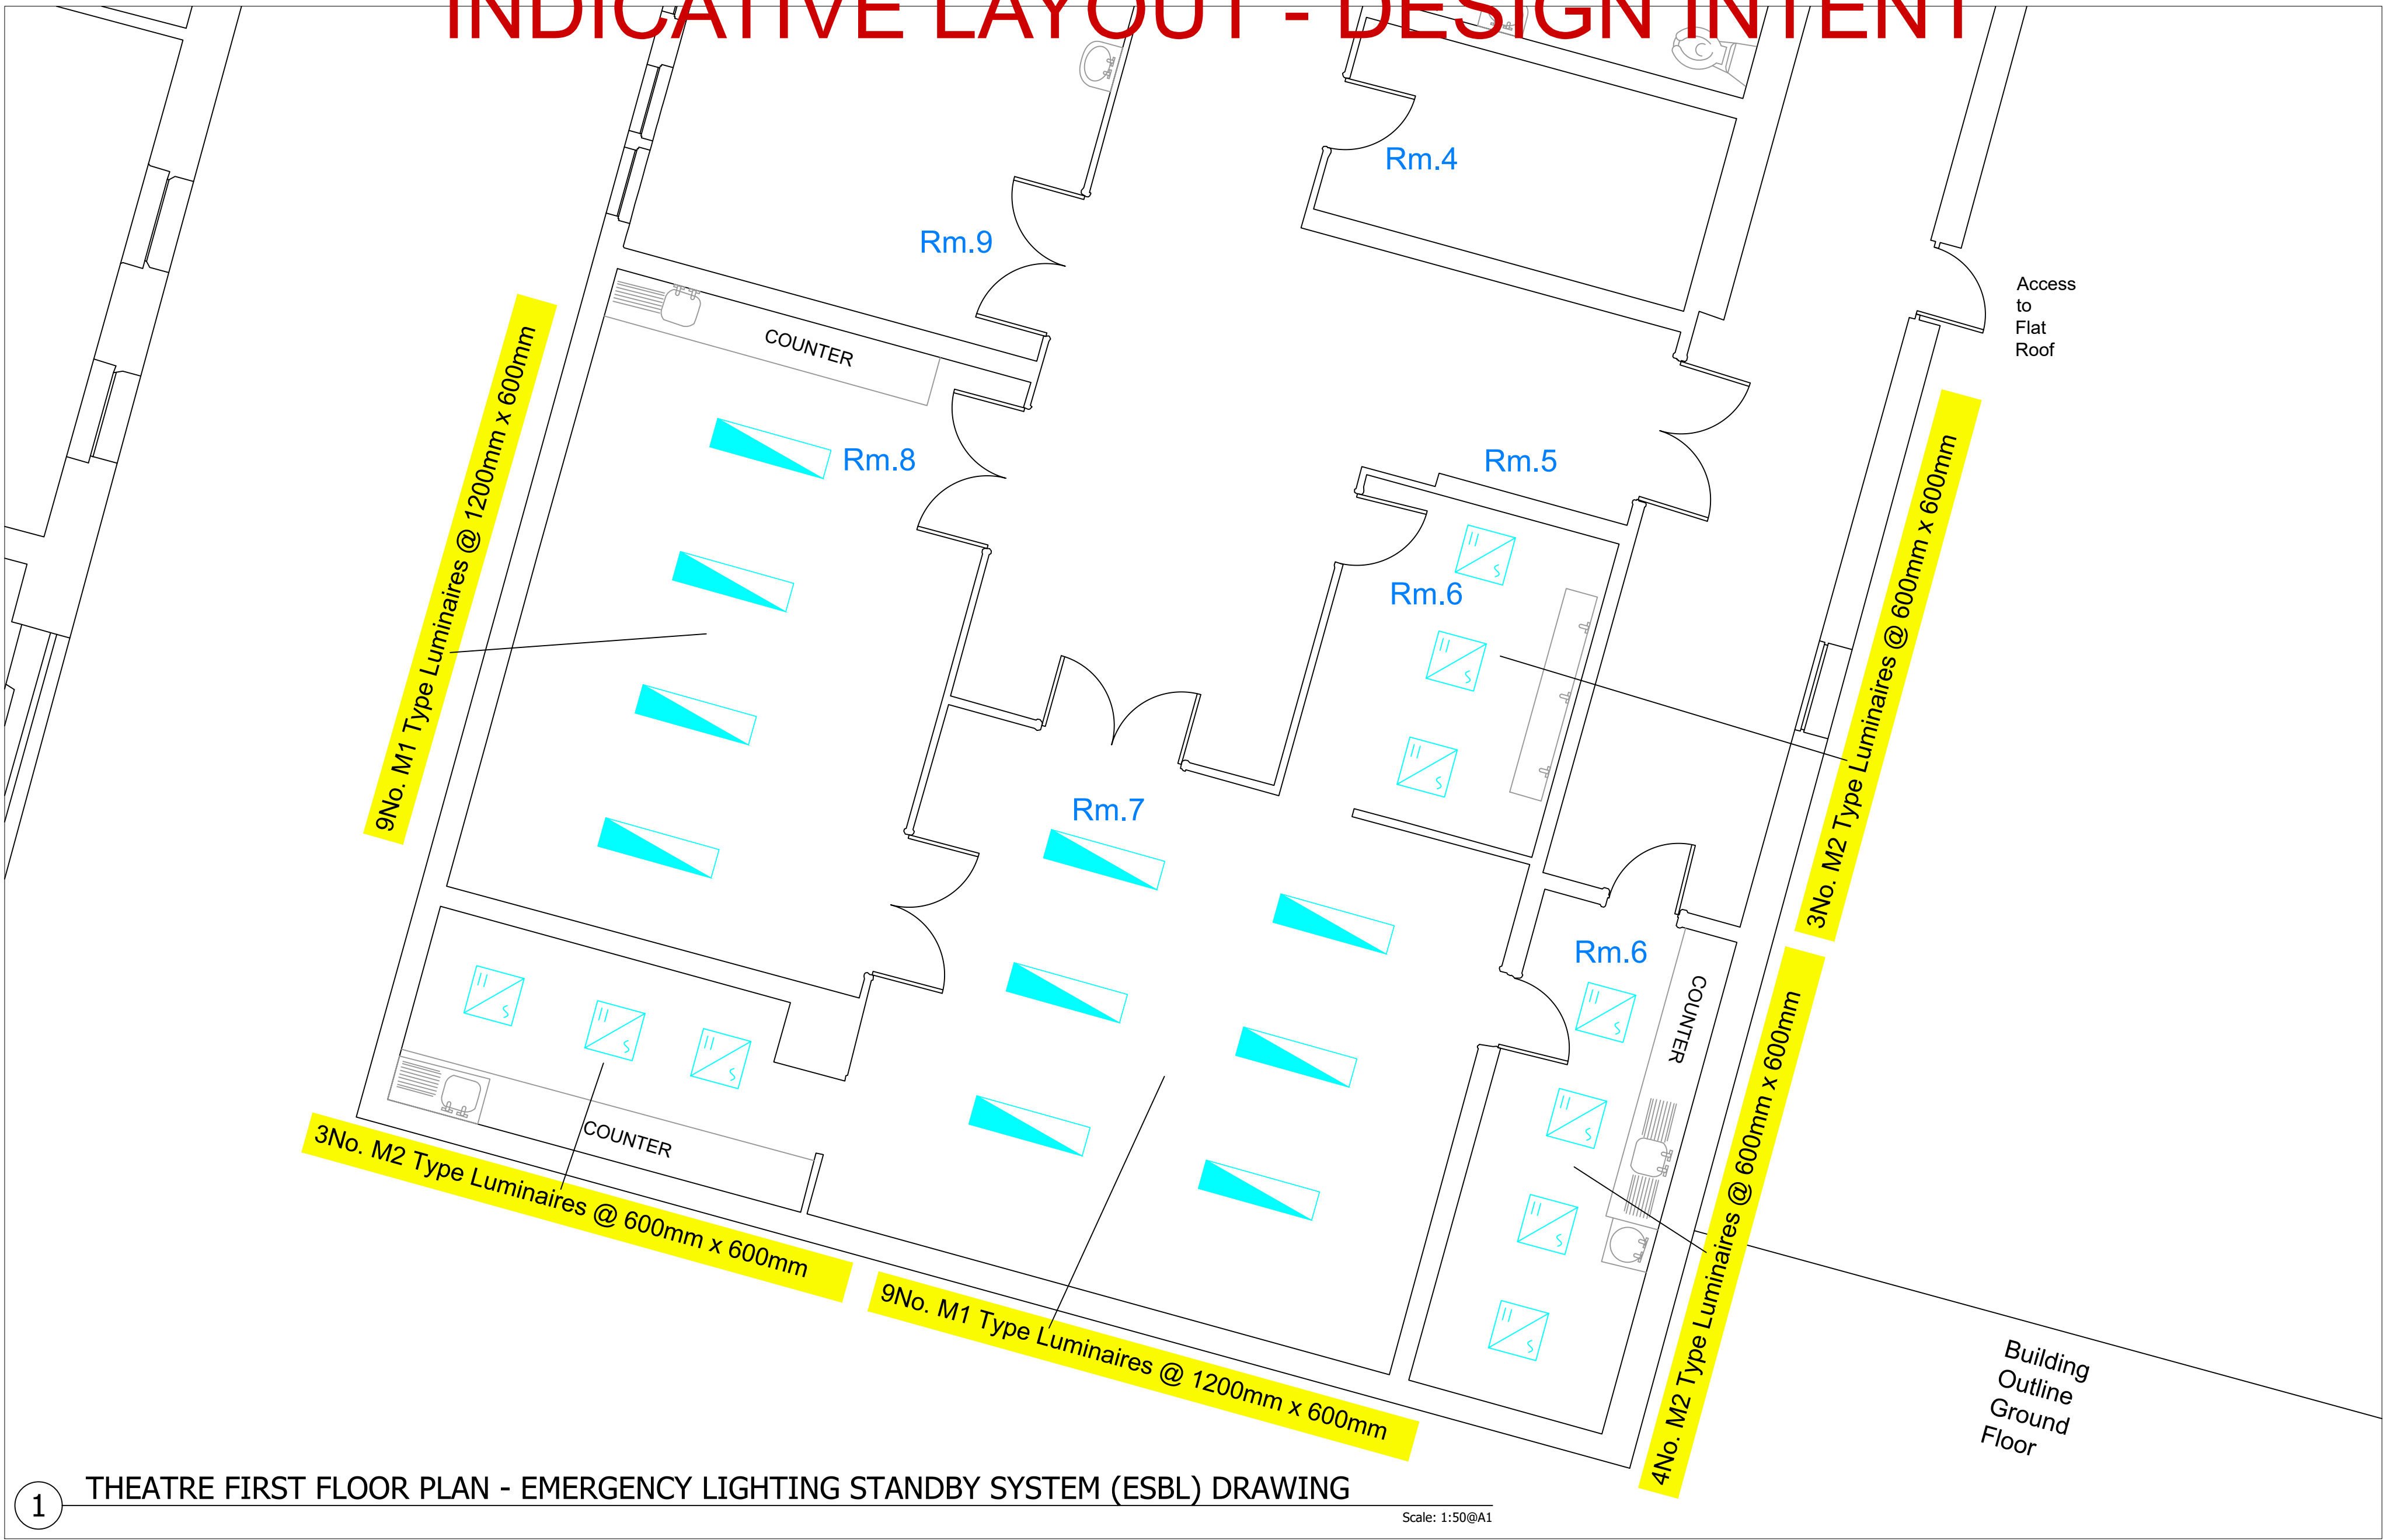


- NOTES**
- ALL DIMENSIONS TO BE CHECKED ON SITE
NO DIMENSIONS TO BE SCALED FROM THIS DRAWING
THIS DRAWING TO BE READ IN CONJUNCTION WITH FIRE CERT CONSULTANTS' WRITTEN SUBMISSION
1. ALL LUMINAIRES IN THE THEATRE SUITE TO BE SUPPLIED FROM THE CENTRAL BATTERY EMERGENCY LIGHTING SYSTEM
 2. DO NOT SCALE FROM THIS DRAWING
 3. THIS DRAWING TO BE READ IN CONJUNCTION WITH RELEVANT ARCHITECTURAL AND STRUCTURAL DRAWINGS, OTHER SERVICES DRAWINGS AND SPECIFICATIONS.
 4. THE INSTALLATION SHALL COMPLY WITH THE IRISH WIRING REGULATIONS, I.S. 10101 2020 & I.S. 3217-2023 FOR EMERGENCY LIGHTING
 5. ALL LUMINAIRES WILL INCORPORATE CONTROL GEAR NECESSARY TO BE DALI AND CONNECTED TO THE EMERGENCY LIGHTING CONTROL SYSTEM.
 6. PRIOR TO COMMENCEMENT OF THE EMERGENCY LIGHTING INSTALLATION, THE ELECTRICAL CONTRACTOR SHALL LIAISE WITH THE HOSPITAL FACILITIES TEAM TO COORDINATE THE SERVICES INSTALLATIONS.
 7. THE CENTRAL BATTERY SYSTEM SHALL BE WITHIN A 120MINS FIRE RATED ENCLOSURE.
 8. THE ELECTRICAL CONTRACTOR EMPLOY A SPECIALIST CENTRAL BATTERY EMERGENCY LIGHTING SPECIALIST TO CORRECTLY SIZE THE CENTRAL BATTERY SYSTEMS REQUIRED WITH 3 HOURS BATTERY CAPACITY TO FULLY SUPPORT EACH HIGH RISK AREA IN COMPLIANCE WITH I.S3217
 9. THE LIGHTING FOR THEATRE SUITE MUST COMPLY WITH CIBSE LG2

Typical Detail for A&B Emergency Static Inverter
- Where 2no, Theatre Department. DB's Exist.

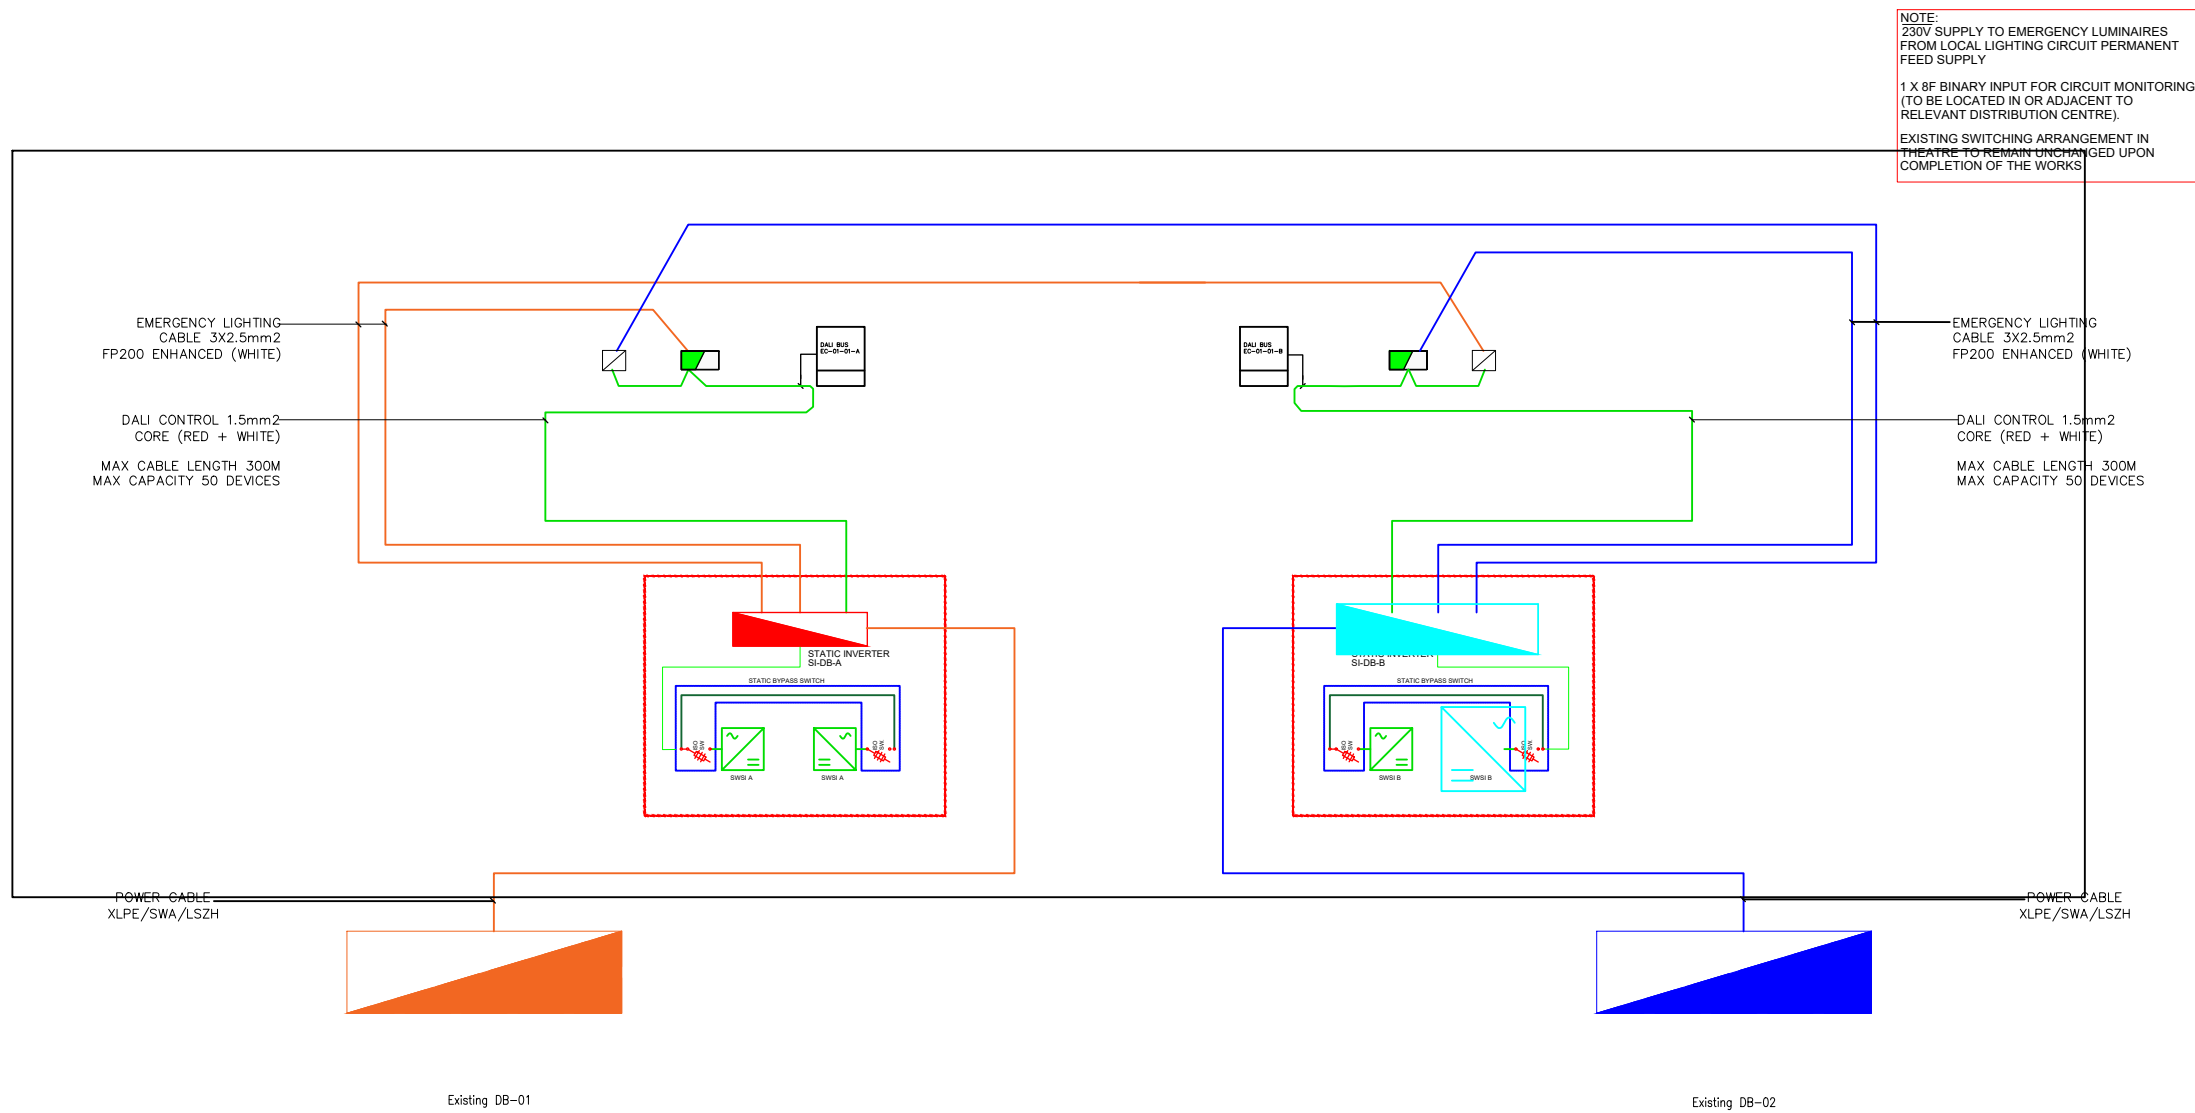

Typical Detail for Single
Emergency Static Inverter

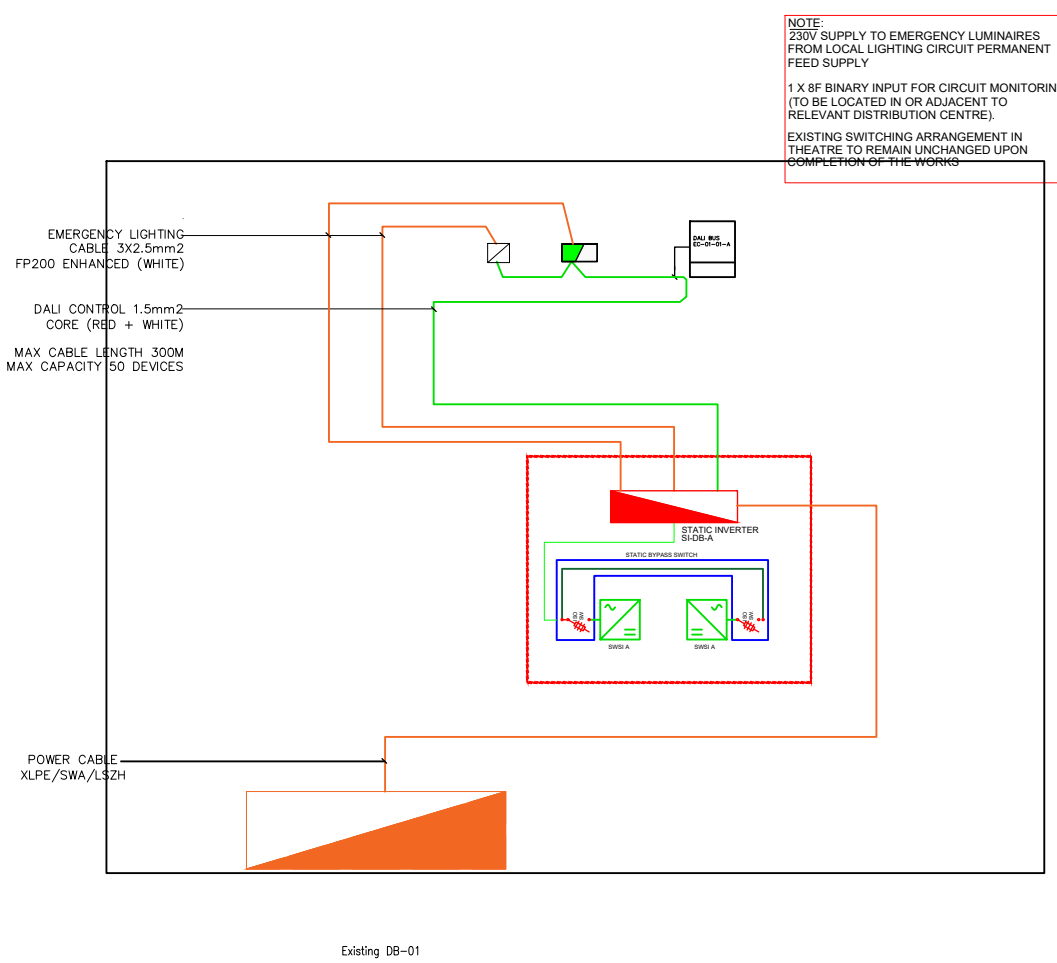

REV	DATE	ITEM
FCC THE FIRE SAFETY ENGINEERS Unit A4, Nutgrove Office Park, Rathfarnham, Dublin 14, D14 H1X4 ph +353 (0)1 443 0013 fc +353 (0)1 663 0014 info@fire-cert.com www.fire-cert.com Client: HEALTH SERVICE EXECUTIVE HeALTH SERVICE EXECUTIVE		
Project: MONAGHAN GENERAL HOSPITAL MULLAGHMONAGHAN, MONAGHAN, H18 NV91		
Drawing: THEATRE FIRST FLOOR PLAN - EMERGENCY STANDBY LIGHTING EMERGENCY LIGHTING SYSTEM (ESBL) TENDER DRAWING		
Scale(s): 1:50	Date: Sept '26	Drawn: ApT
Checked: SM	Project No. 26045	Status Code: S13
Dwg: 26045-XX-L01-DR-FCC-FS-7002		Rev: Sheet: A1
Status: For Tender		Stage: 3