


INDICATIVE LAYOUT - DESIGN INTENT

NOTES

- A. DO NOT SCALE FROM THIS DRAWING - WORK ONLY FROM FIGURED DIMENSIONS
- B. ALL ERRORS & OMISSIONS TO BE REPORTED TO THE CONSULTING ENGINEER
- C. THIS DRAWING TO BE READ IN CONJUNCTION WITH ARCHITECTS & STRUCTURAL ENGINEERS DRAWINGS

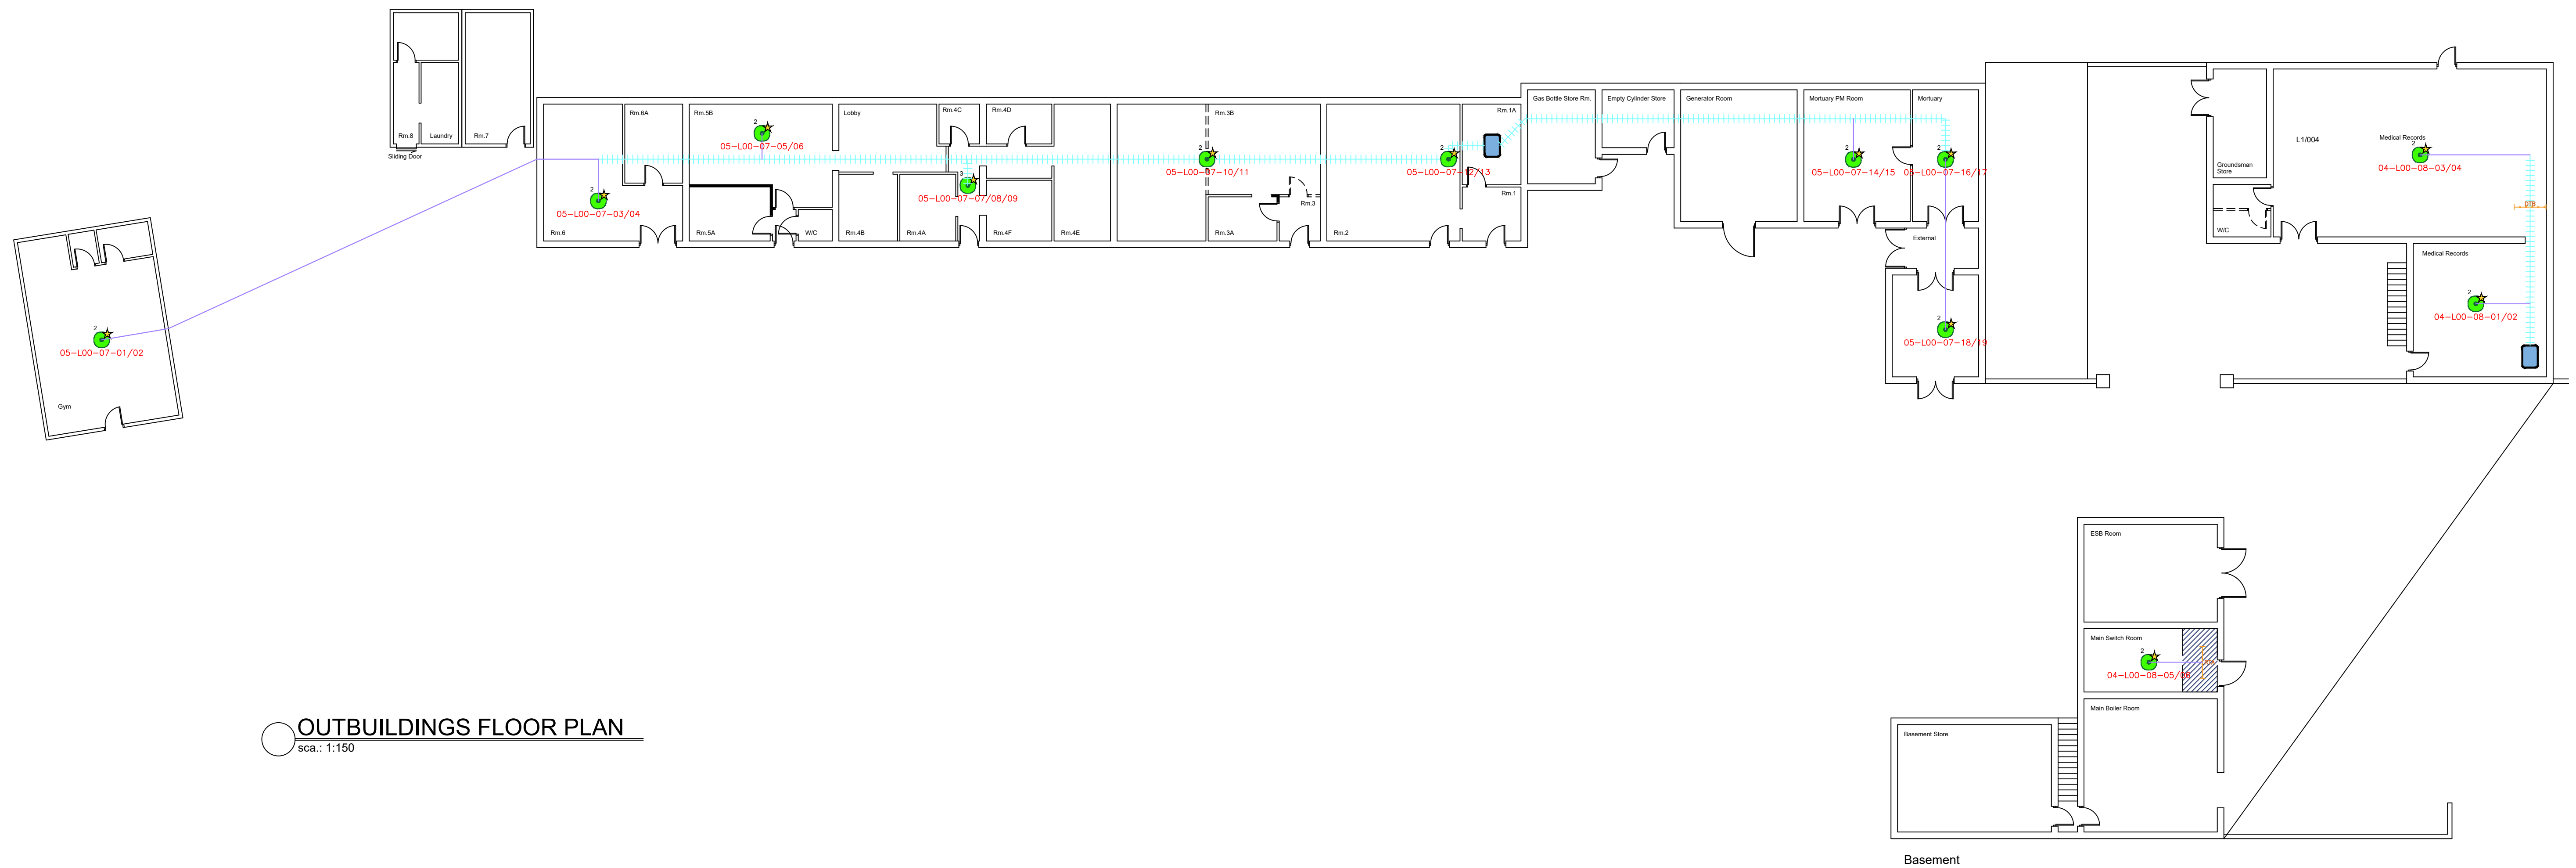

OUTBUILDINGS FLOOR PLAN
sca.: 1:150

LEGEND

- | | | | | |
|---|---|--|---|----------------|
| 2 |  | ACCESS POINT - GENERAL CELLING
2 CABLES | | BASKET |
| 3 |  | ACCESS POINT - GENERAL CELLING
3 CABLES | | RTA/DTB |
| 3 |  | ACCESS POINT - STAIRS
3 CABLES | | CAT6A CABLES |
| 2 |  | ACCESS POINT - LIFTS
2 CABLES |  | COMMS LOCATION |

A	FOR TENDER	DT	DD	MK	22/09/2026
ISSUE	DESCRIPTION	DRN	ORIG	APP	DATE



CLIENT

HEALTH SERVICE EXECUTIVE

PROJECT No.	PROJECT
26045	MONAGHAN GENERAL HOSPITAL, MULLAGHMONAGHAN, MONAGHAN, H18 NV91

DRAWING No.

26045-XX-L00-DR-FCC-FS-8004_WIFI-DAS

SHEET	SCALE	TITLE
A1	1:150	OUTBUILDINGS PLAN