


INDICATIVE LAYOUT - DESIGN INTENT

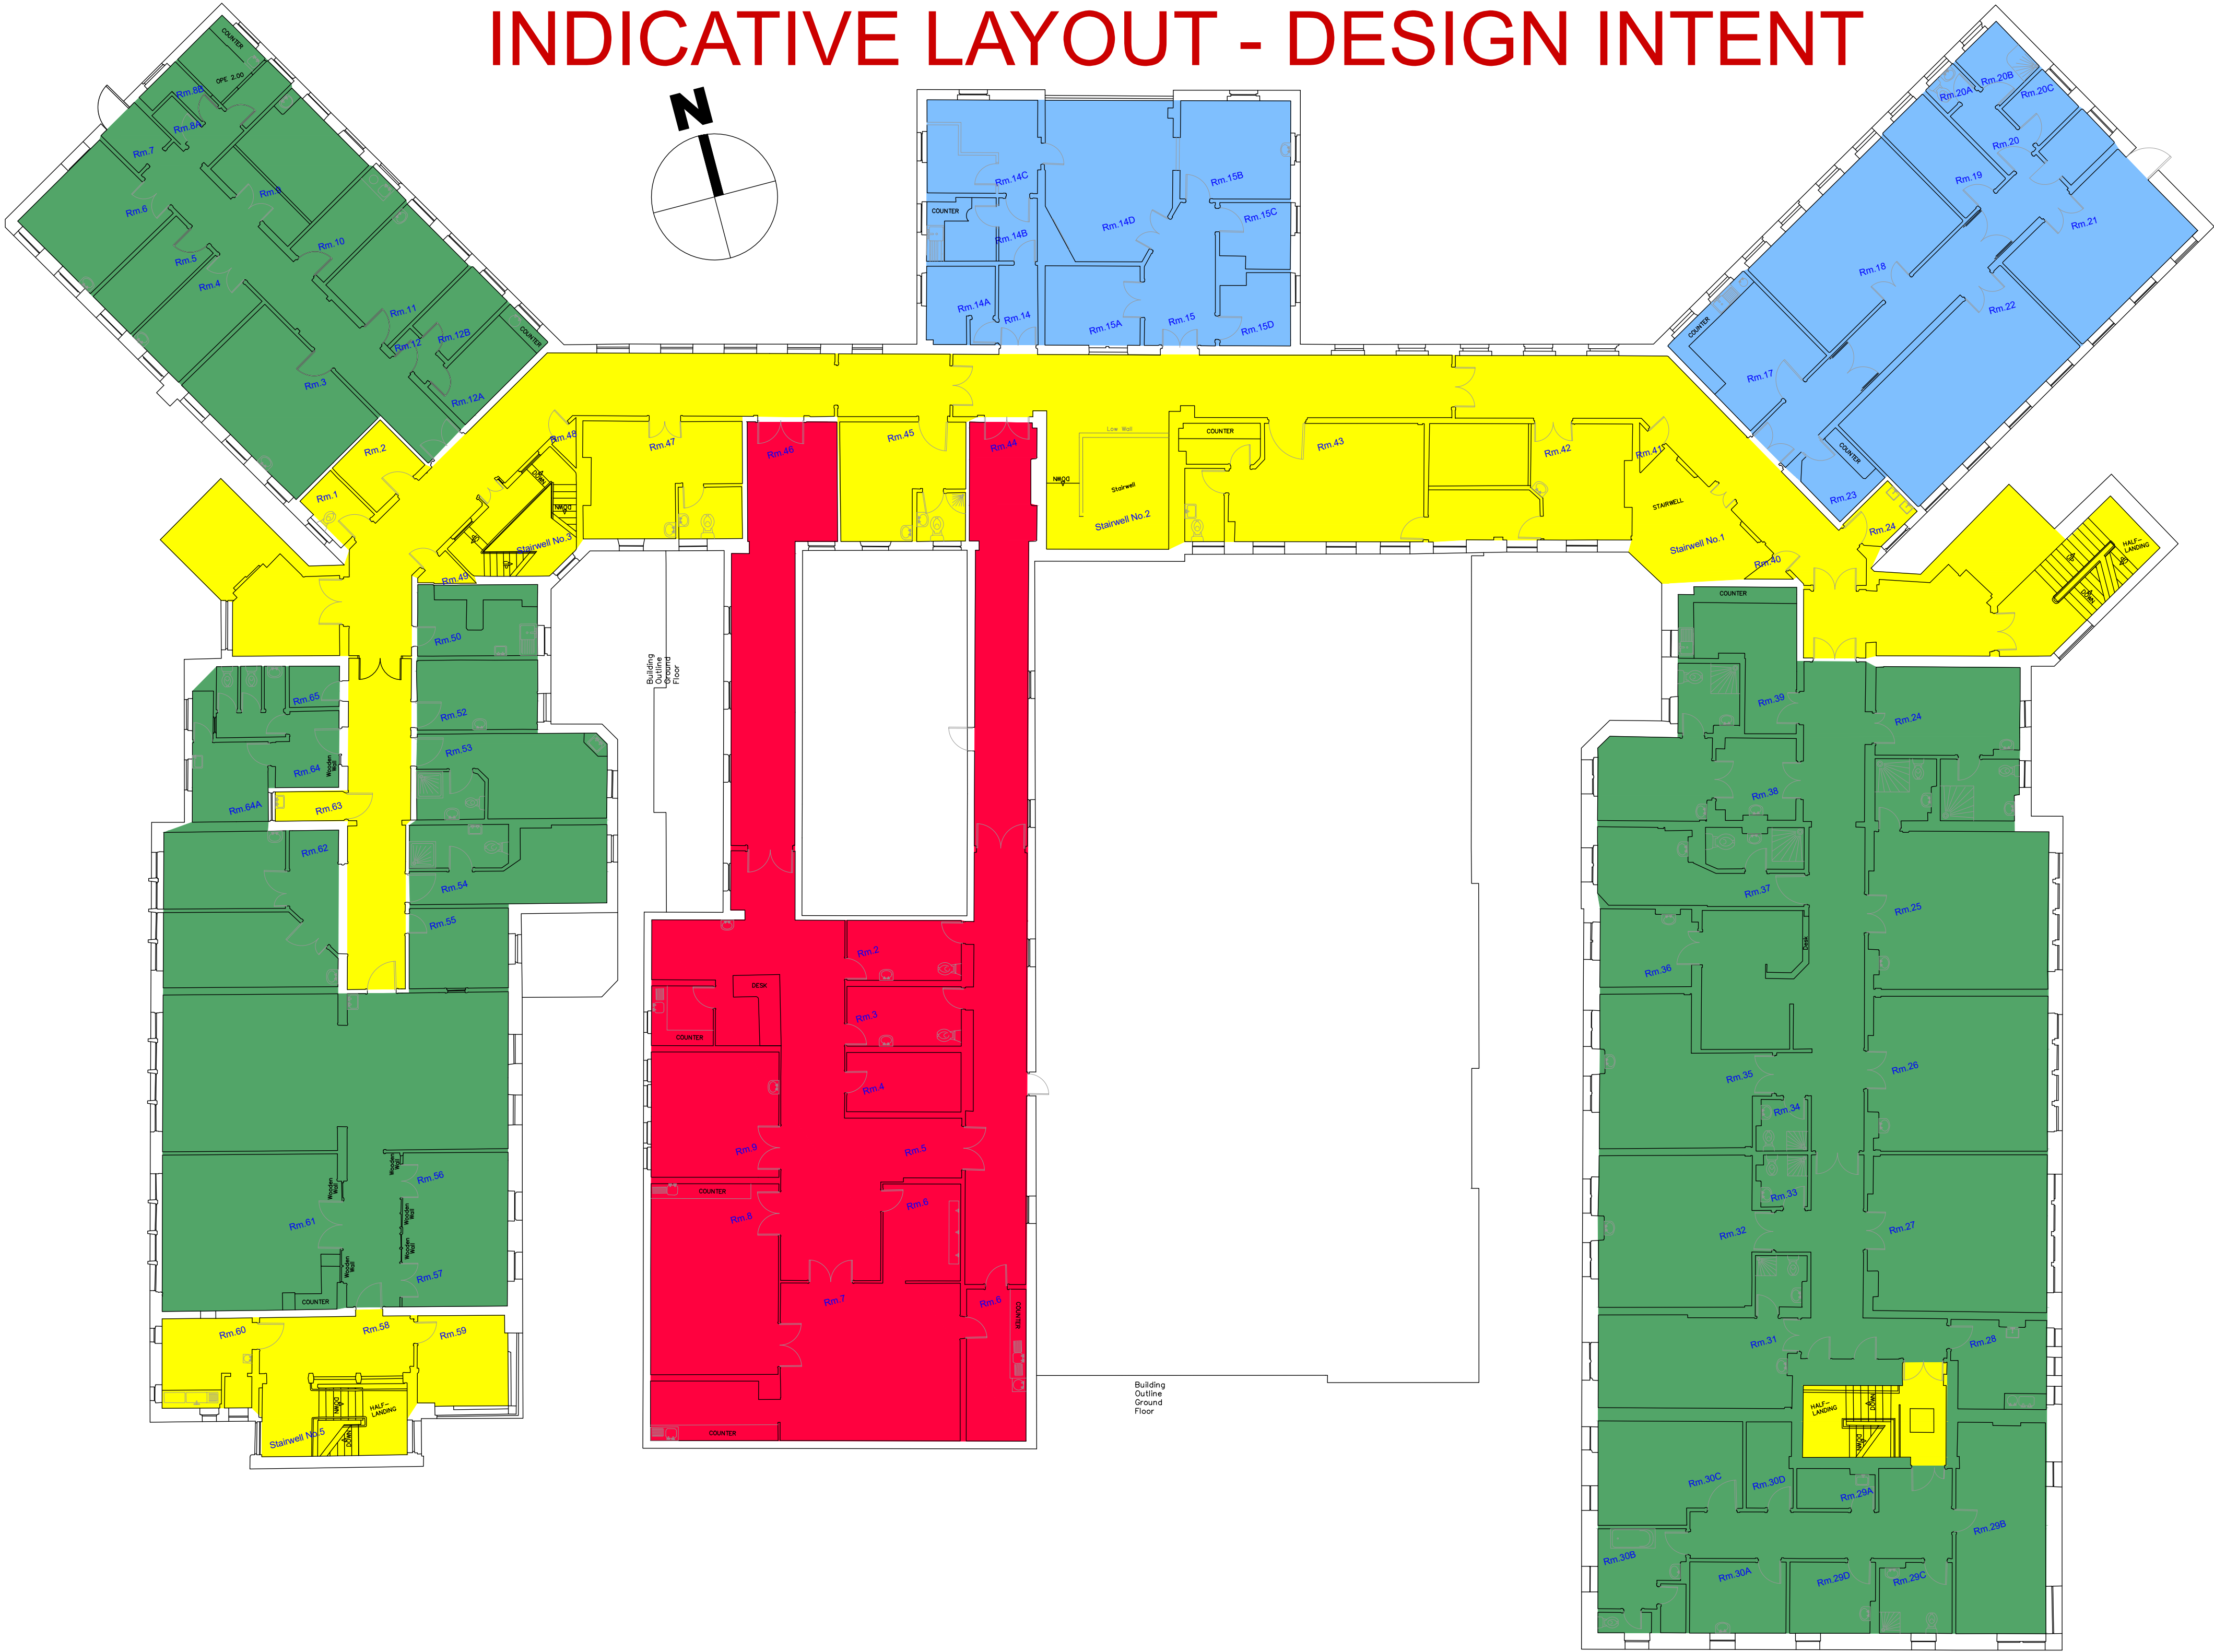

NOTES

ALL DIMENSIONS TO BE CHECKED ON SITE
NO DIMENSIONS TO BE SCALED FROM THIS DRAWING
THIS DRAWING TO BE READ IN CONJUNCTION WITH FIRE CERT CONSULTANTS' WRITTEN SUBMISSION

LEGEND:

INFECTION CONTROL PROVISIONS, NORMAL WORKING HOURS / OUT OF WORKING HOURS. (REFER TO ASPERGILLOSIS SPECIFICATION AND GUIDANCE).

- DAY TIME WORK
- NO PATIENTS
- AT RISK STAFF TO BE MOVED BY HOSPITAL MANAGEMENT

- NIGHT-TIME WORK
- NO PATIENTS
- NO STAFF

- DAY TIME WORK
- GENERALLY GROUP 1 - IF ANY GROUP 2 PATIENTS, HOSPITAL TO MOVE PATIENTS

- DAY TIME WORK
- GROUP 2 TO 4 PATIENTS

- HOSPITAL TO ORGANISE PHASE SHUT DOWN OF AREA
- GROUP 2 TO 4 PATIENTS
- ALLOW FOR WEEKEND WORK

1 FIRST FLOOR PLAN - WORKING TIMES (WT) DRAWING

Scale: 1:150@A1

REV	DATE	ITEM
FCC THE FIRE SAFETY ENGINEERS Unit A4, Nutgrove Office Park, Rathfarnham, Dublin 14, D14 H1X4 ph +353 (0)1 663 0013 fc +353 (0)1 663 0014 info@fire-cert.com www.fire-cert.com Client: HEALTH SERVICE EXECUTIVE Project: MONAGHAN GENERAL HOSPITAL MULLAGHMONAGHAN, MONAGHAN, H18 NV91 Drawing: FIRST FLOOR PLAN WORKING TIMES (WT) TENDER DRAWING Scale(s): 1:150 Date: Sept '26 Drawn: ApT Checked: SM Project No. 26045 Status Code: S13 Dwg: 26045-XX-L01-DR-FCC-FS-1002 Rev: Sheet: A1 Status: For Tender Stage: 3		