

INDICATIVE LAYOUT - DESIGN INTENT


NOTES

ALL DIMENSIONS TO BE CHECKED ON SITE
NO DIMENSIONS TO BE SCALED FROM THIS DRAWING
THIS DRAWING TO BE READ IN CONJUNCTION WITH FIRE CERT CONSULTANTS' WRITTEN SUBMISSION

LEGEND:

INFECTION CONTROL PROVISIONS, NORMAL WORKING HOURS / OUT OF WORKING HOURS. (REFER TO ASPERGILLOSIS SPECIFICATION AND GUIDANCE).

- DAY TIME WORK
• NO PATIENTS
• AT RISK STAFF TO BE MOVED BY HOSPITAL MANAGEMENT
- NIGHT-TIME WORK
• NO PATIENTS
• NO STAFF
- DAY TIME WORK
• GENERALLY GROUP 1 - IF ANY GROUP 2 PATIENTS, HOSPITAL TO MOVE PATIENTS
- DAY TIME WORK
• GROUP 2 TO 4 PATIENTS
- HOSPITAL TO ORGANISE PHASE SHUT DOWN OF AREA
• GROUP 2 TO 4 PATIENTS
• ALLOW FOR WEEKEND WORK

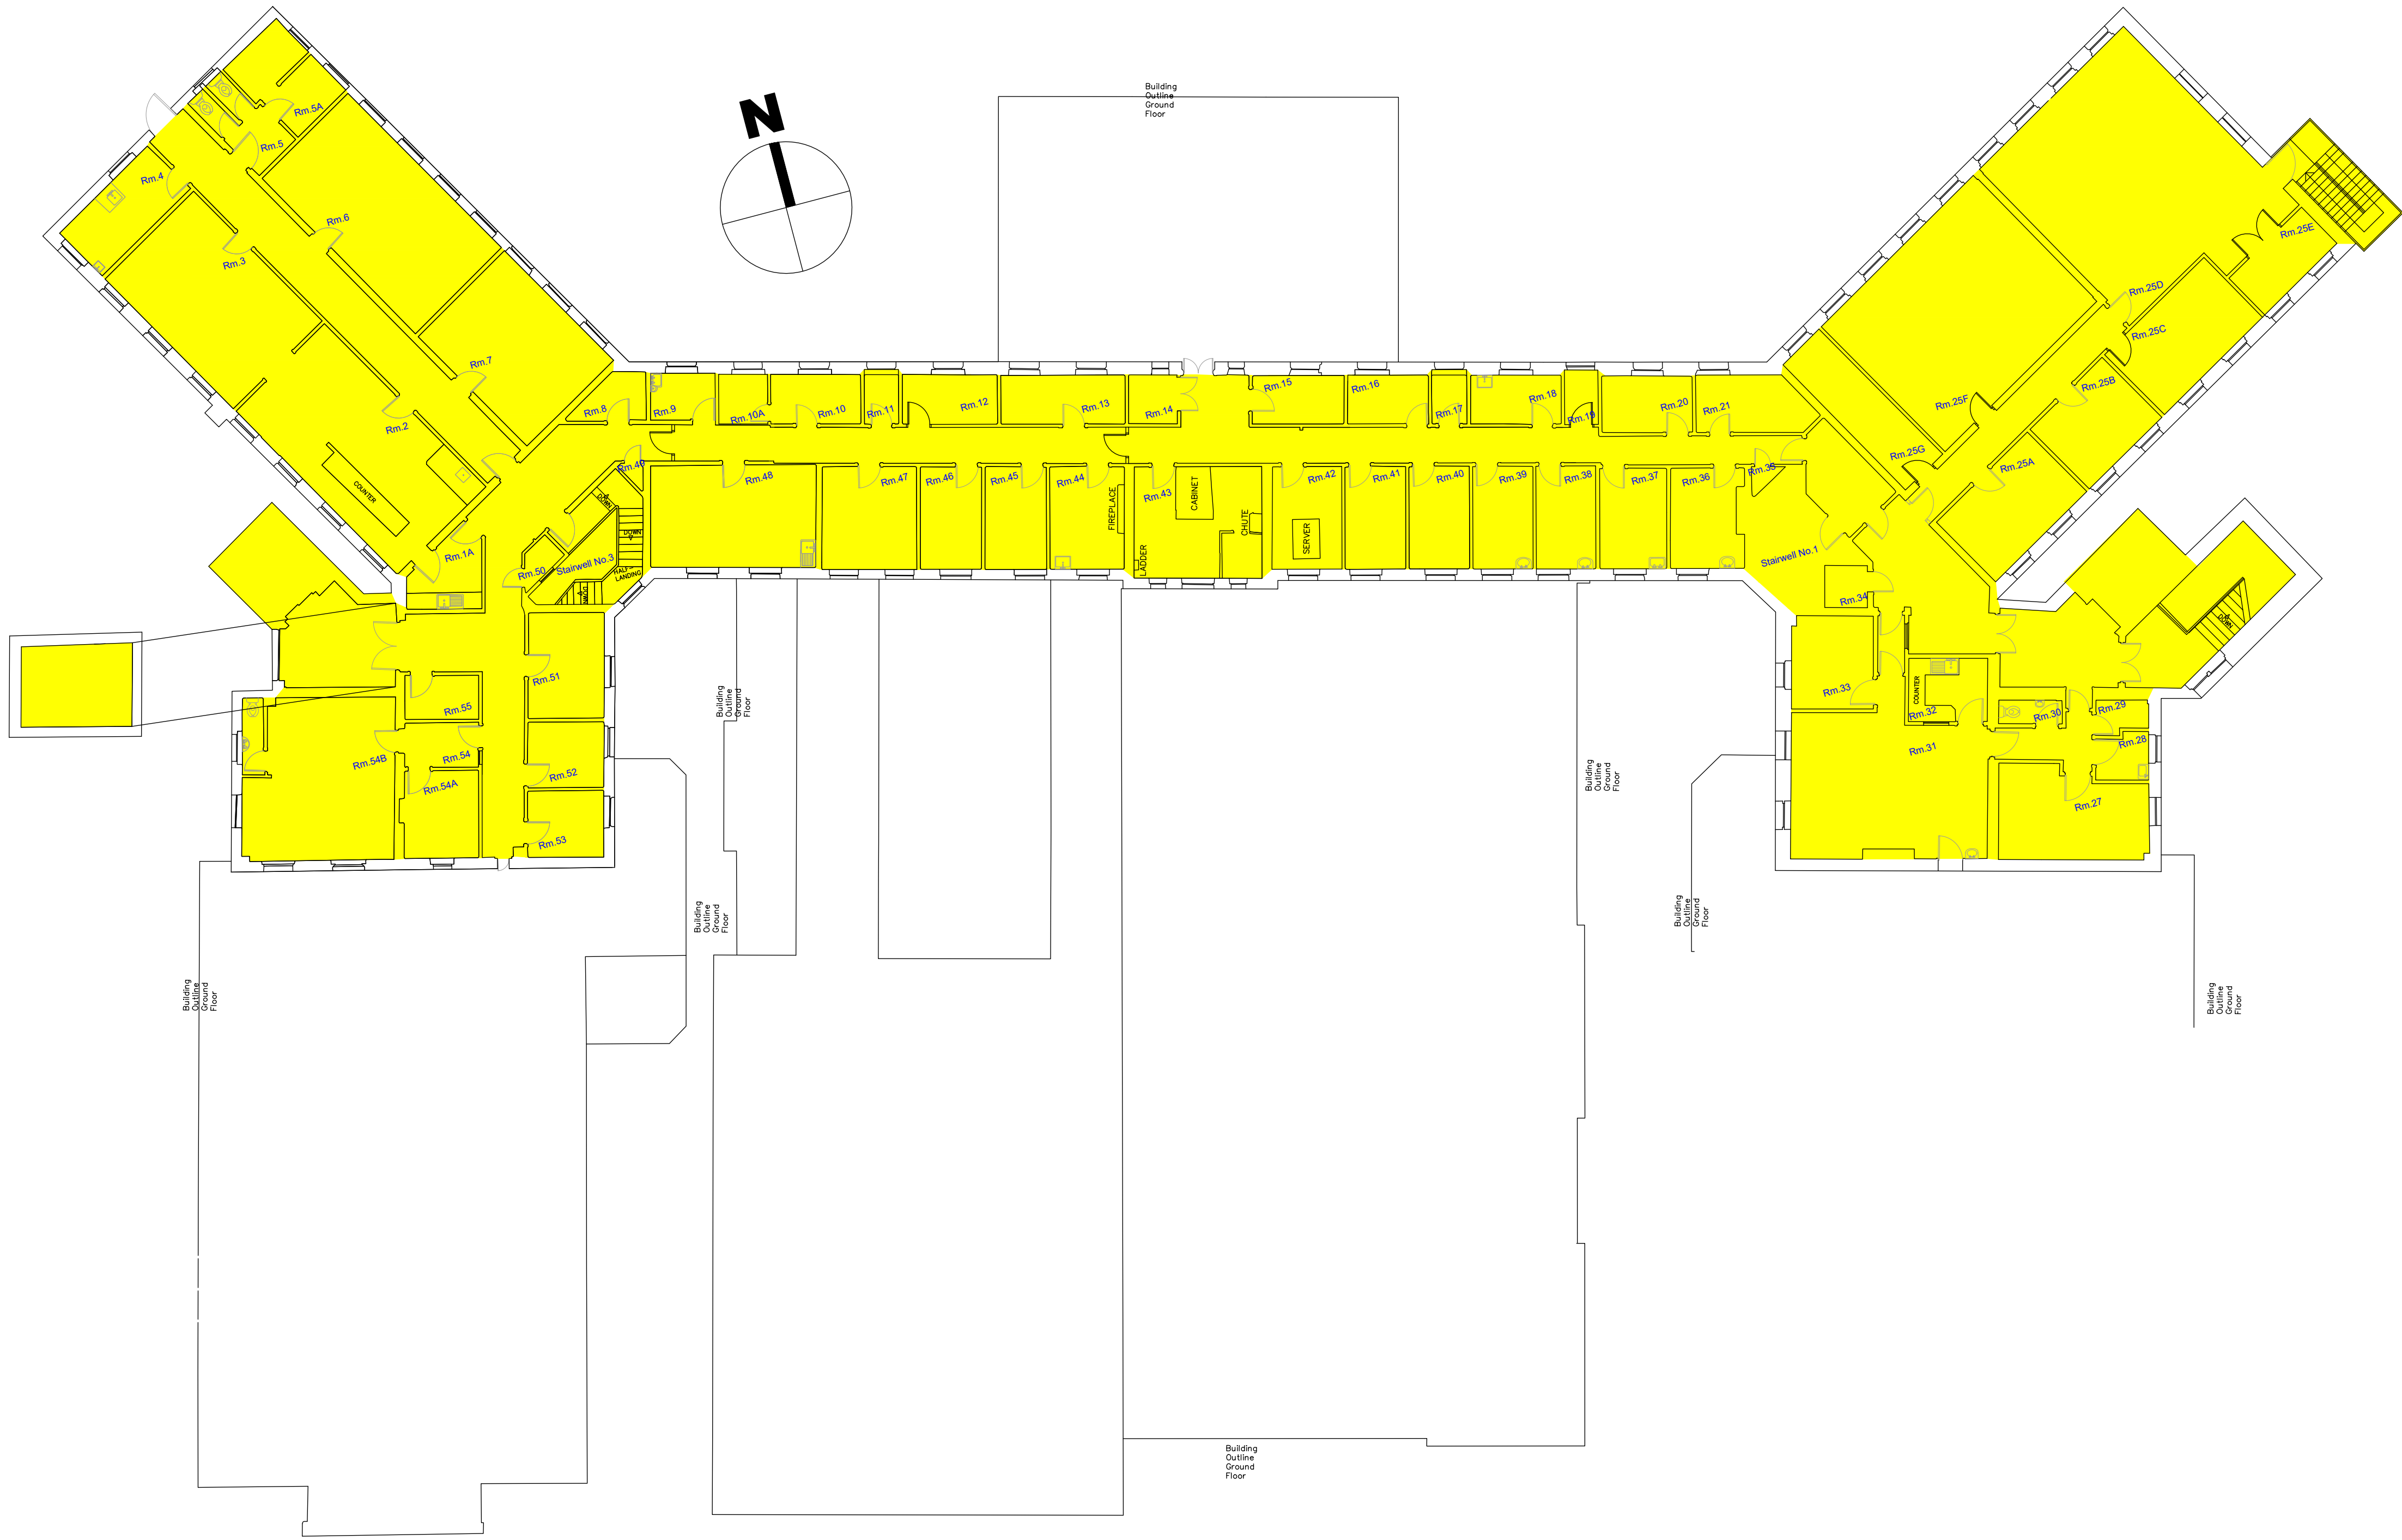

1 SECOND FLOOR PLAN - WORKING TIMES (WT) DRAWING

Scale: 1:150@A1

REV	DATE	ITEM
-----	------	------



Unit A4, Nutgrove Office Park,
Rathfarnham, Dublin 14, D14 H1X4

ph +353 (0)1 665 0013 | fc +353 (0)1 665 0014
info@fire-cert.com | www.fire-cert.com

Client:
HEALTH SERVICE EXECUTIVE



Project:
MONAGHAN GENERAL HOSPITAL
MULLAGHMONAGHAN, MONAGHAN, H18 NV91

Drawing:
SECOND FLOOR PLAN
WORKING TIMES (WT) TENDER DRAWING

Scale(s):	Date:	Drawn:	Checked:	Project No.	Status Code:
1:150	Sept '26	ApT	SM	26045	S13

Dwg: 26045-XX-L02-DR-FCC-FS-1003	Rev:	Sheet: A1
----------------------------------	------	-----------

Status: For Tender	Stage: 3
--------------------	----------