


INDICATIVE LAYOUT - DESIGN INTENT

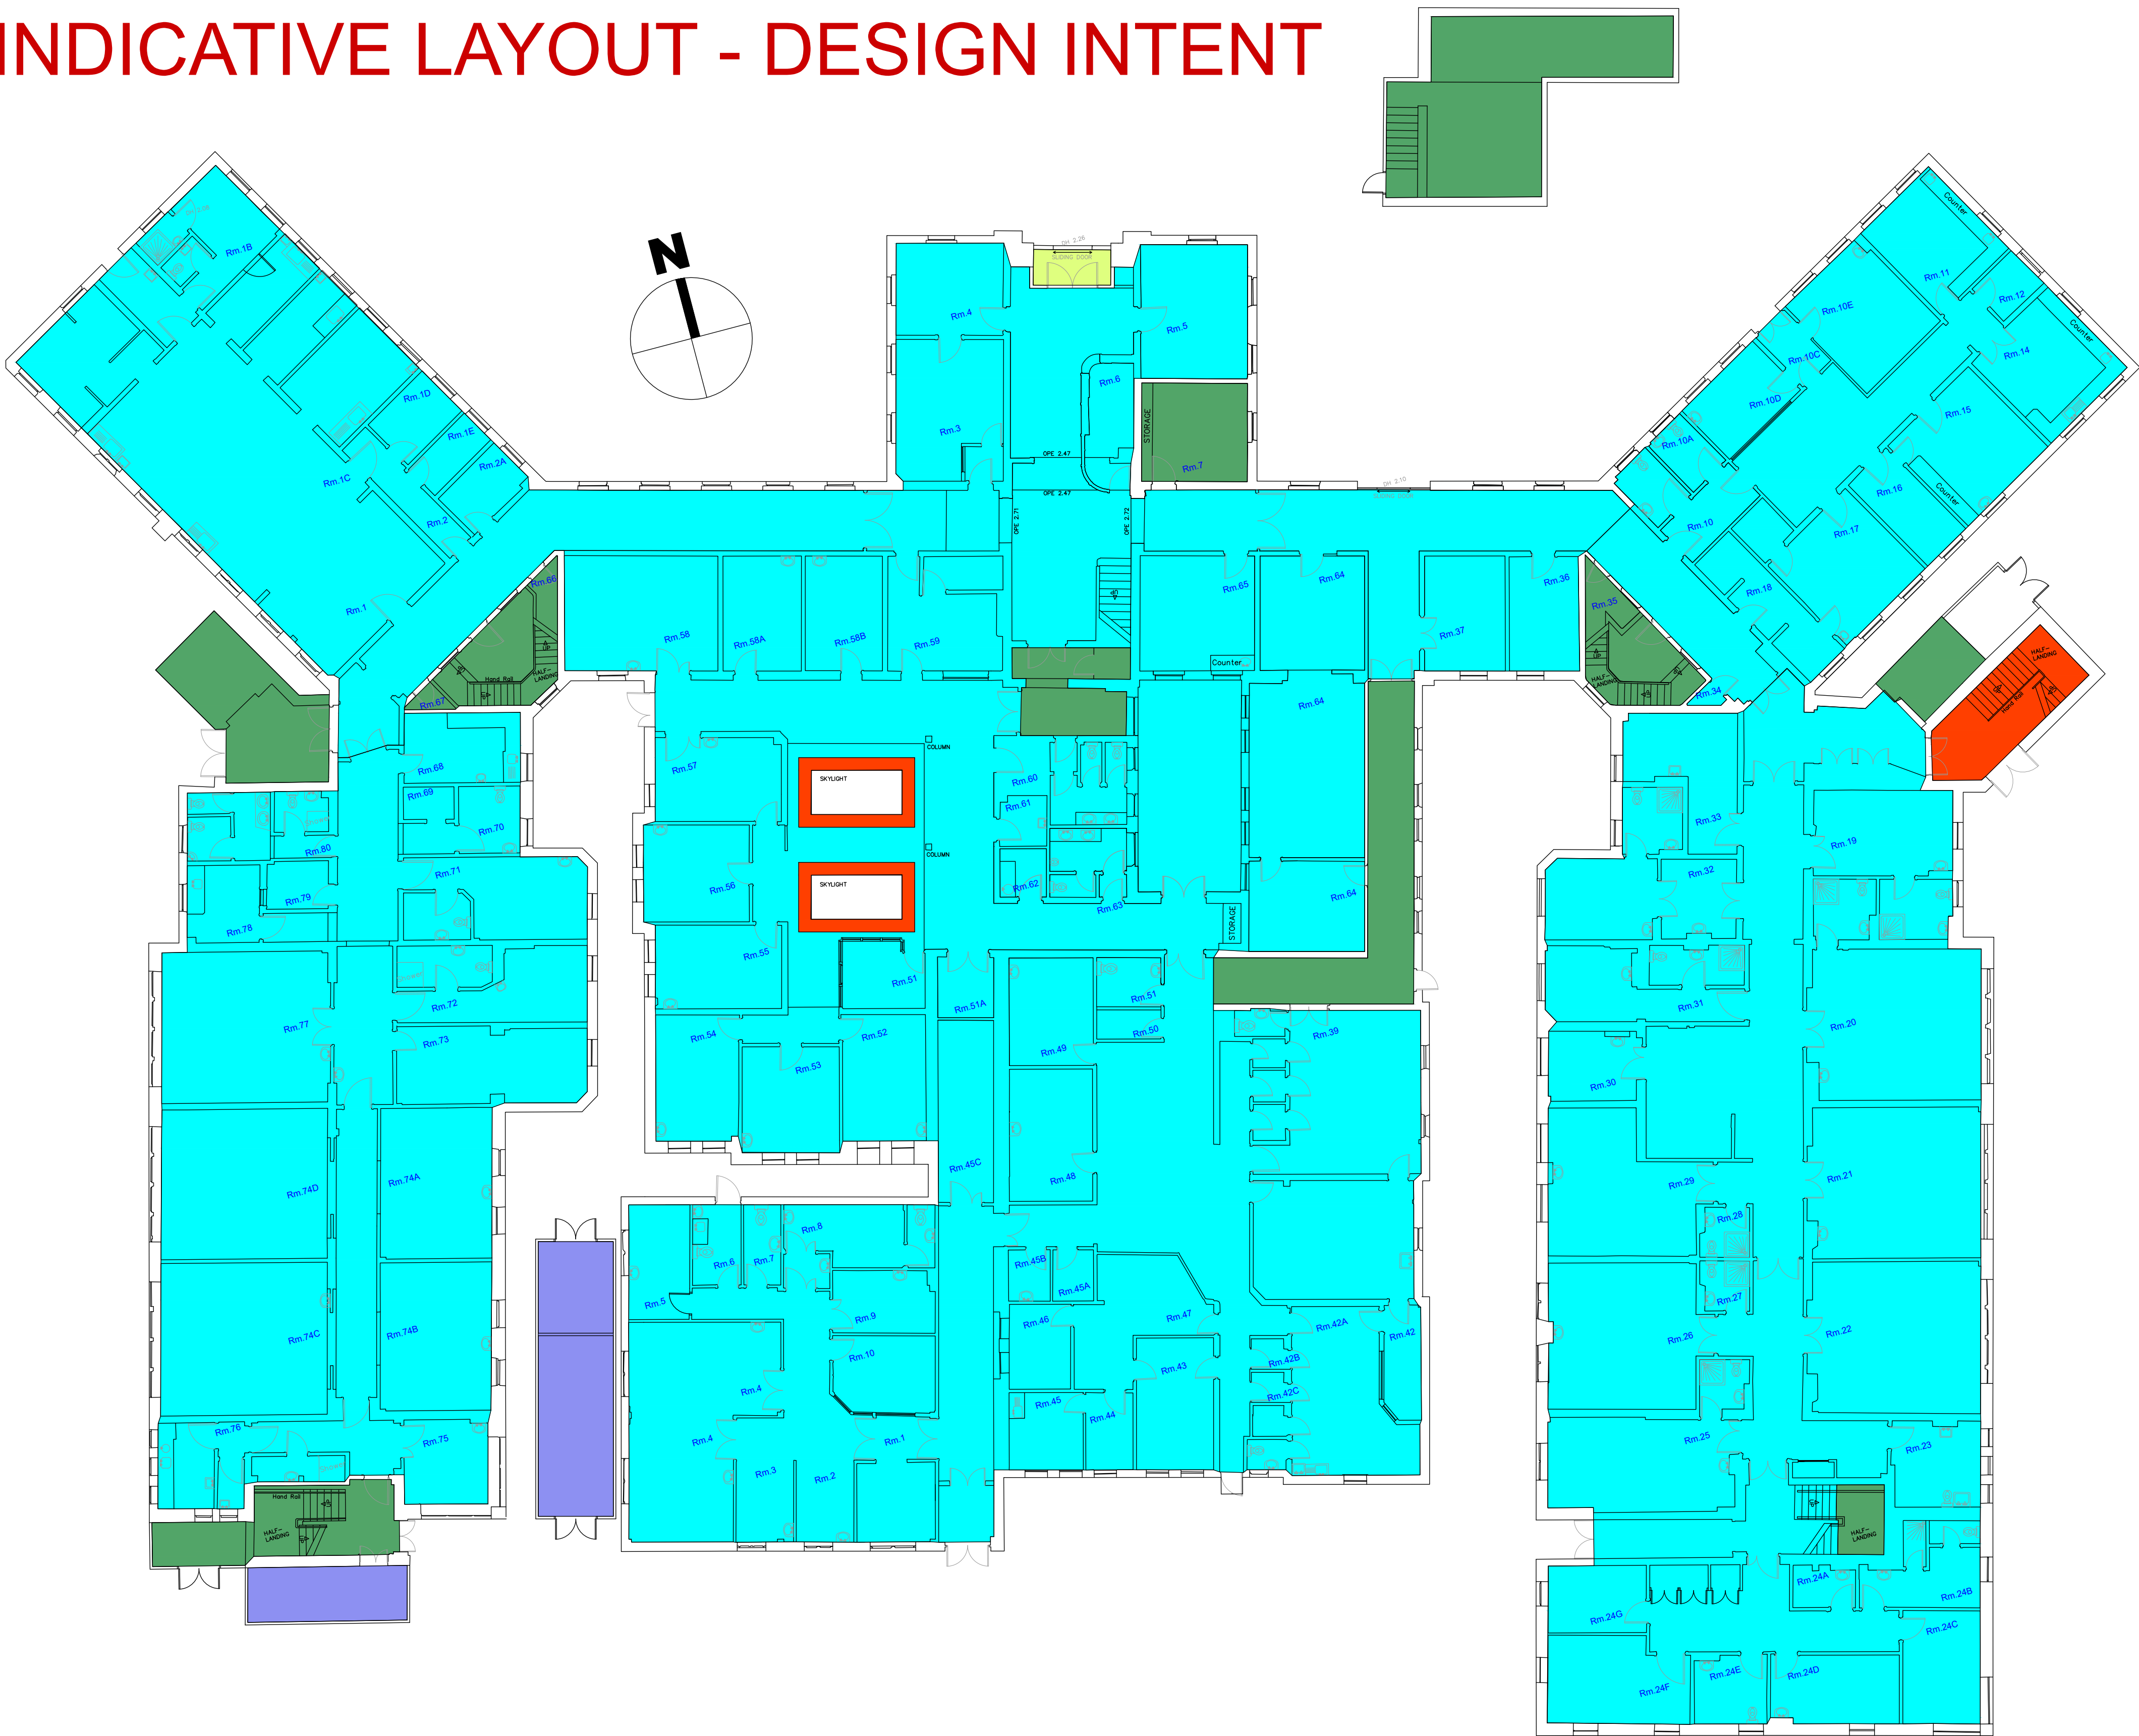

1 GROUND FLOOR PLAN - REFLECTED CEILINGS (RC) DRAWING

Scale: 1:150@A1

NOTES

ALL DIMENSIONS TO BE CHECKED ON SITE
NO DIMENSIONS TO BE SCALED FROM THIS DRAWING
THIS DRAWING TO BE READ IN CONJUNCTION WITH FIRE CERT CONSULTANTS' WRITTEN SUBMISSION

LEGEND: REFLECTED CEILINGS

-  • SUSPENDED CEILINGS
-  • METAL CEILINGS
-  • CONCRETE CEILINGS
-  • PLASTERBOARD CEILINGS
-  • TIMBER CEILINGS

REV	DATE	ITEM
-----	------	------



FCC
THE FIRE SAFETY ENGINEERS

Unit A4, Nutgrove Office Park,
Rathfarnham, Dublin 14, D14 H1X4

ph +353 (0)1 665 0013 | fc +353 (0)1 665 0014
info@fire-cert.com | www.fire-cert.com

Client:
HEALTH SERVICE EXECUTIVE

Project:
MONAGHAN GENERAL HOSPITAL
MULLAGHMONAGHAN, MONAGHAN, H18 NV91

Drawing:
GROUND FLOOR PLAN
REFLECTED CEILINGS (RC) TENDER DRAWING

Scale(s): 1:150	Date: Sept '26	Drawn: ApT	Checked: SM	Project No. 26045	Status Code: S13
--------------------	-------------------	---------------	----------------	----------------------	---------------------

Dwg: 26045-XX-L00-DR-FCC-FS-2001	Rev:	Sheet: A1
----------------------------------	------	-----------

Status: For Tender

Stage: 3