


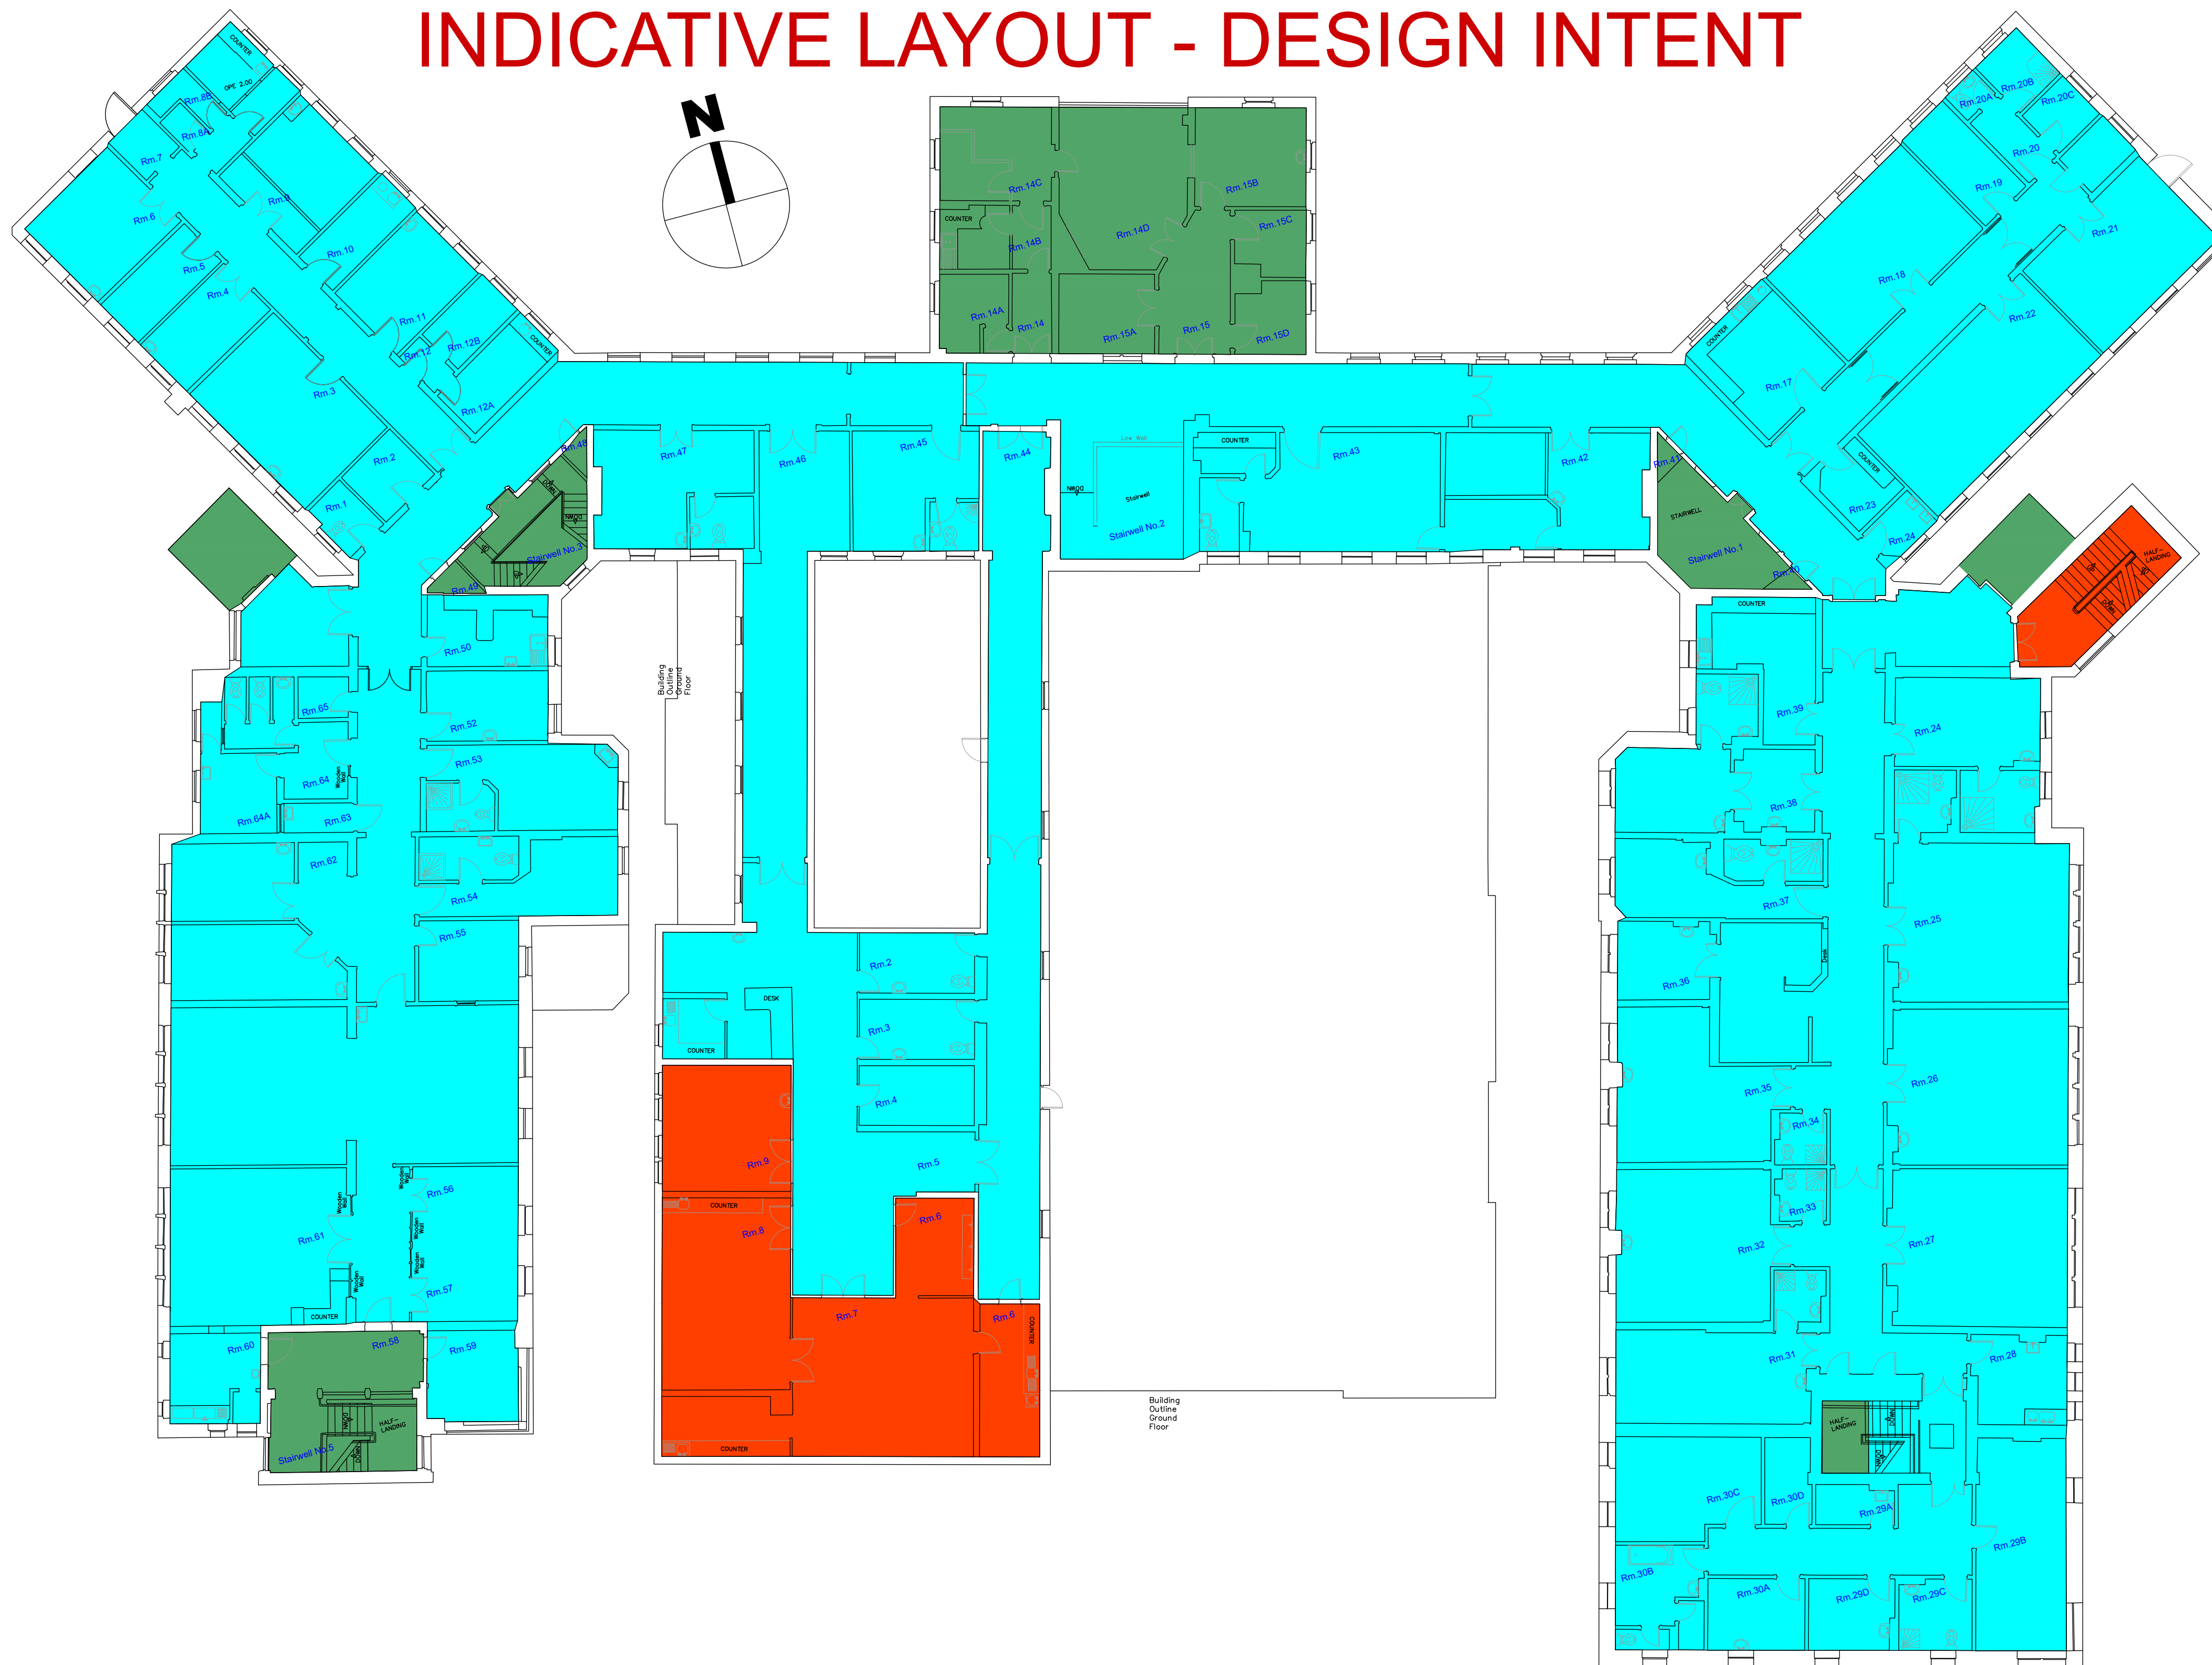

Scale: 1:150@A1

- SUSPENDED CEILINGS
- METAL CEILINGS
- CONCRETE CEILINGS
- PLASTERBOARD CEILINGS
- TIMBER CEILINGS

REV	DATE	ITEM	 Unit A4, Nutgrove Office Park, Rathfarnham, Dublin 14, D14 HX4 ph +353 (0)1 663 0013 fc +353 (0)1 663 0014 info@fire-cerl.com www.fire-cerl.com		
Client: HEALTH SERVICE EXECUTIVE			 HeALTH SERVICE EXECUTIVE		
Project: MONAGHAN GENERAL HOSPITAL MULLAGHMONAGHAN, MONAGHAN, H18 NV91					
Drawing: FIRST FLOOR PLAN REFLECTED CEILING (RC) TENDER DRAWING					
Scale(s): 1:150	Date: Sept '26	Drawn: ApT	Checked: SM	Project No. 26045	Status Code: S13
Dwg: 26045-XX-LO1-DR-FCC-FS-2002				Rev:	Sheet: A1
Status: For Tender			Stage: 3		