


INDICATIVE LAYOUT - DESIGN INTENT

 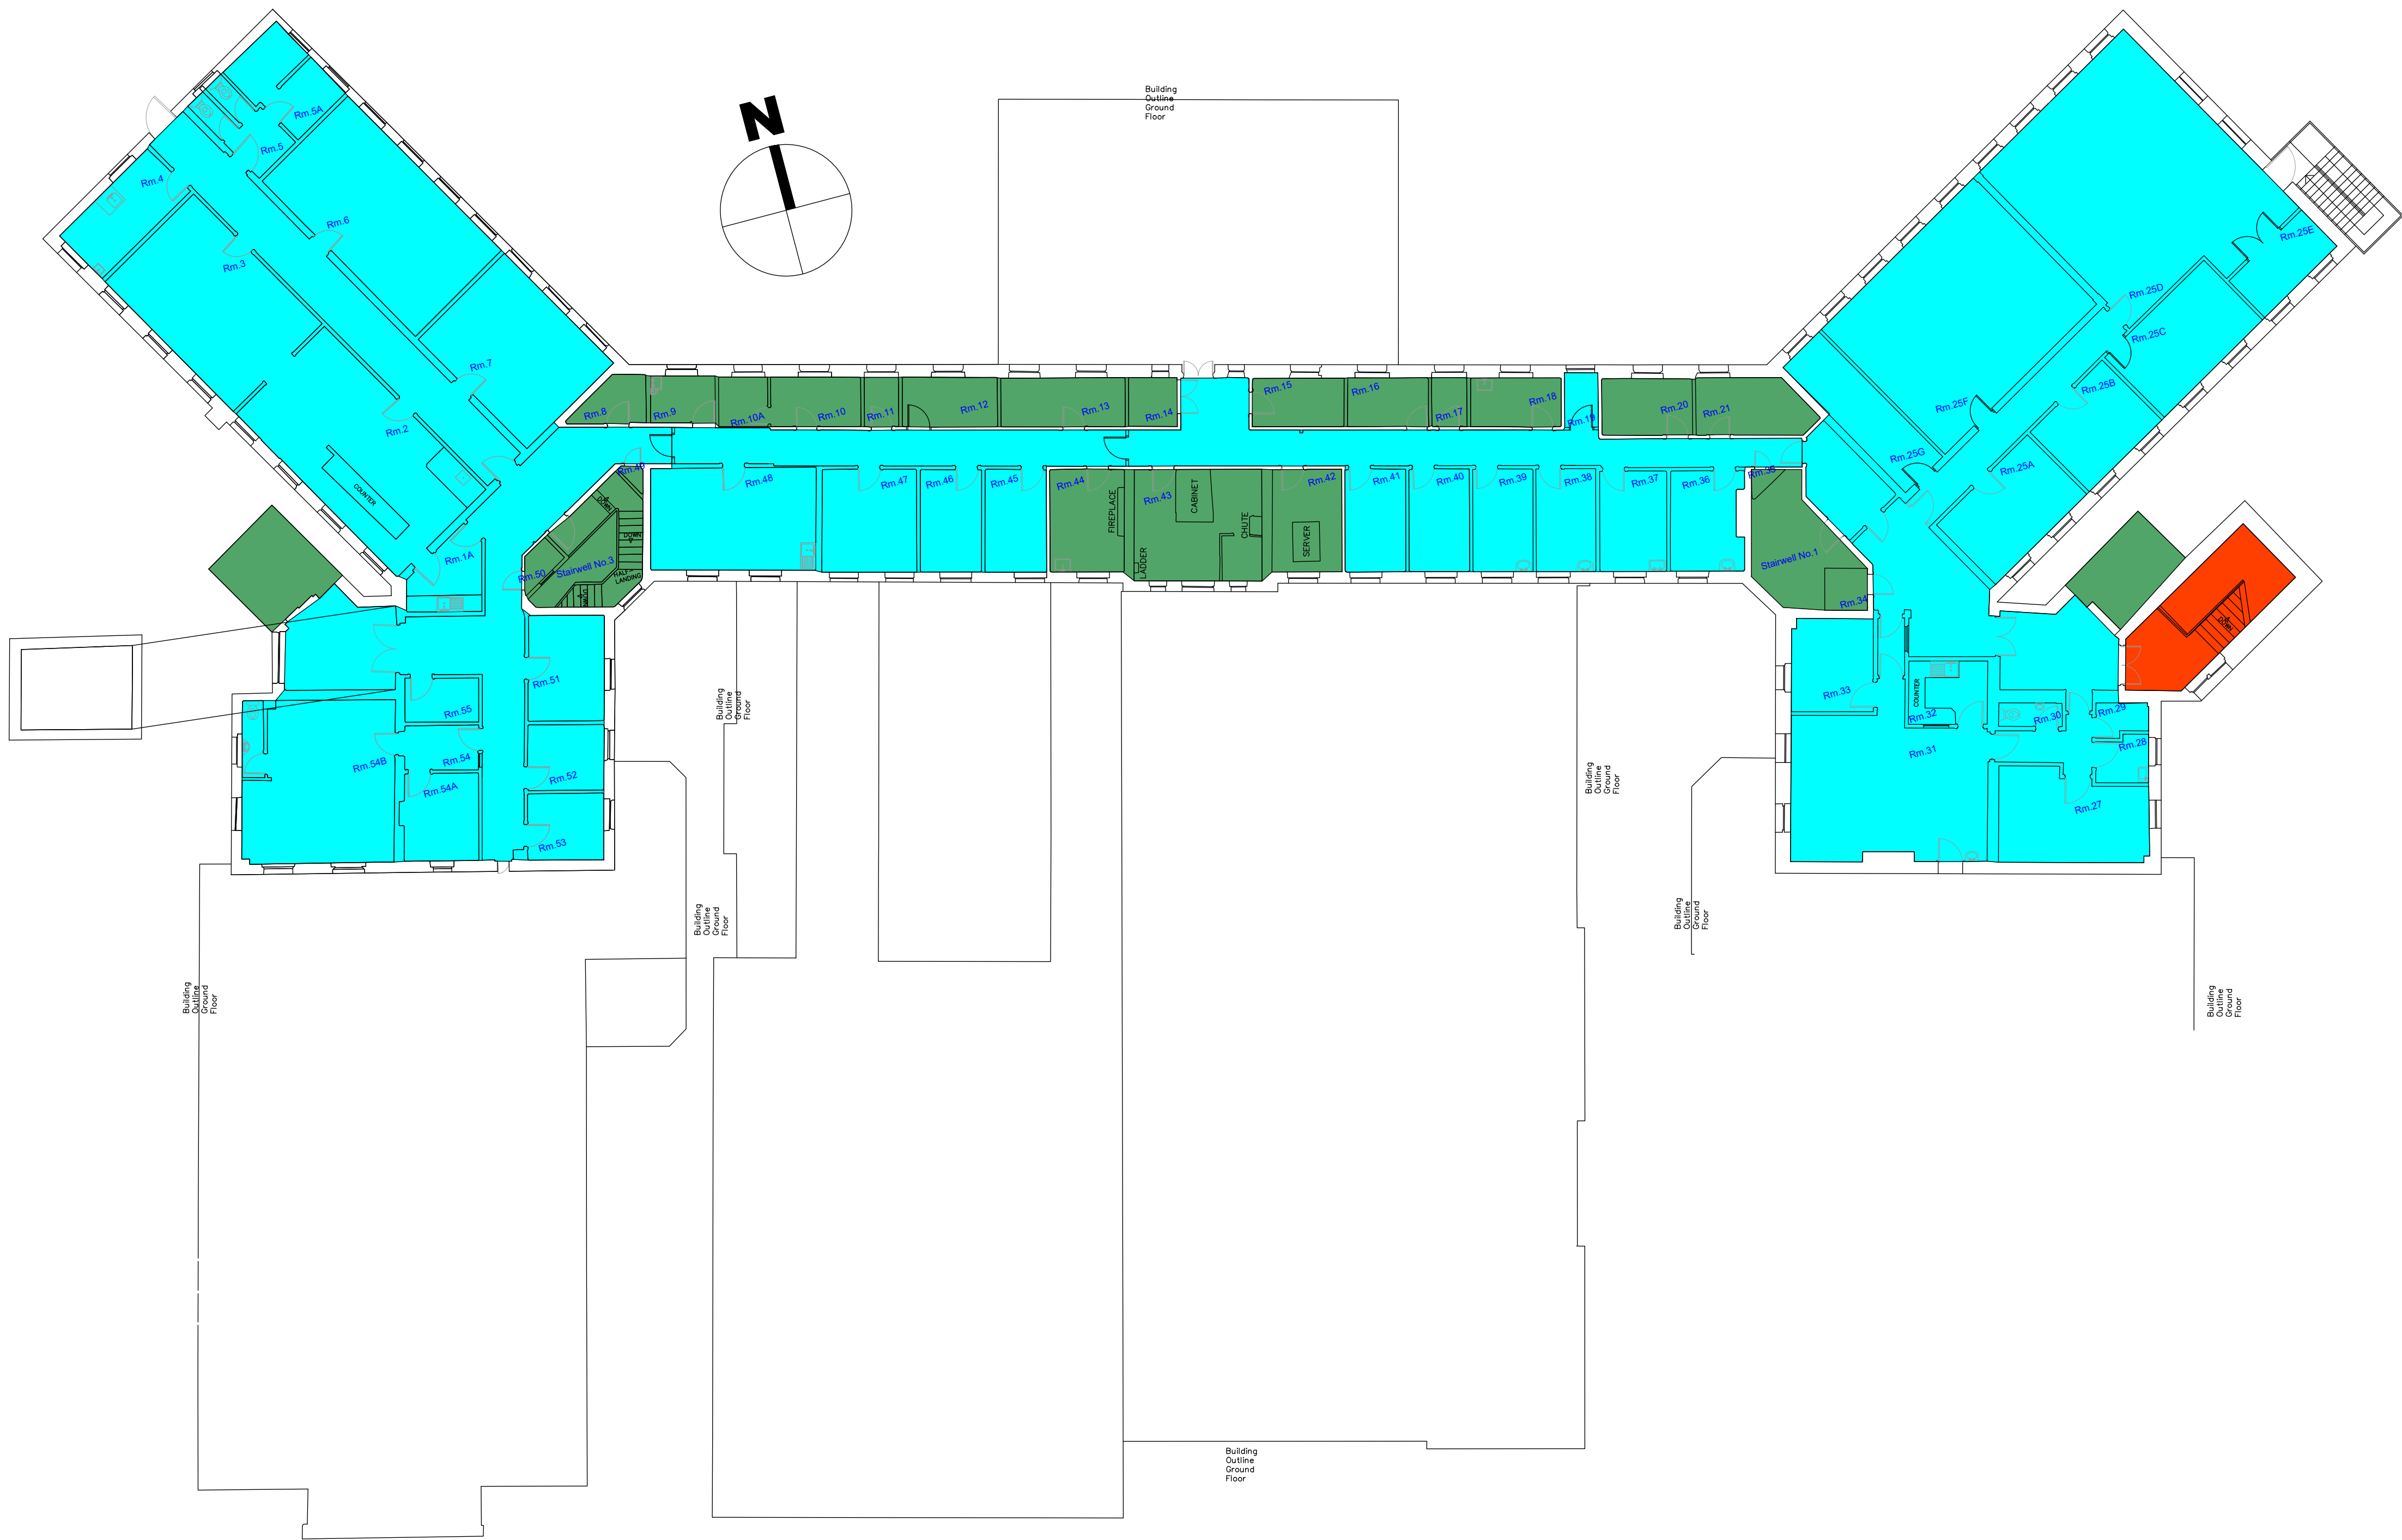


1 SECOND FLOOR PLAN - REFLECTED CEILINGS (RC) DRAWING
Scale: 1:150@A1

NOTES

ALL DIMENSIONS TO BE CHECKED ON SITE
NO DIMENSIONS TO BE SCALED FROM THIS DRAWING
THIS DRAWING TO BE READ IN CONJUNCTION WITH FIRE CERT CONSULTANTS' WRITTEN SUBMISSION

LEGEND:
REFLECTED CEILINGS

-  • SUSPENDED CEILINGS
-  • METAL CEILINGS
-  • CONCRETE CEILINGS
-  • PLASTERBOARD CEILINGS
-  • TIMBER CEILINGS

REV	DATE	ITEM
 FCC THE FIRE SAFETY ENGINEERS Unit A4, Nutgrove Office Park, Rathfarnham, Dublin 14, D14 H1X4 ph +353 (0)1 663 0013 fc +353 (0)1 663 0014 info@fire-cert.com www.fire-cert.com		
Client: HEALTH SERVICE EXECUTIVE		
 Heilwheirw		