


INDICATIVE LAYOUT - DESIGN INTENT

NOTES

- A. DO NOT SCALE FROM THIS DRAWING - WORK ONLY FROM FIGURED DIMENSIONS
- B. ALL ERRORS & OMISSIONS TO BE REPORTED TO THE CONSULTING ENGINEER
- C. THIS DRAWING TO BE READ IN CONJUNCTION WITH ARCHITECTS & STRUCTURAL ENGINEERS DRAWINGS

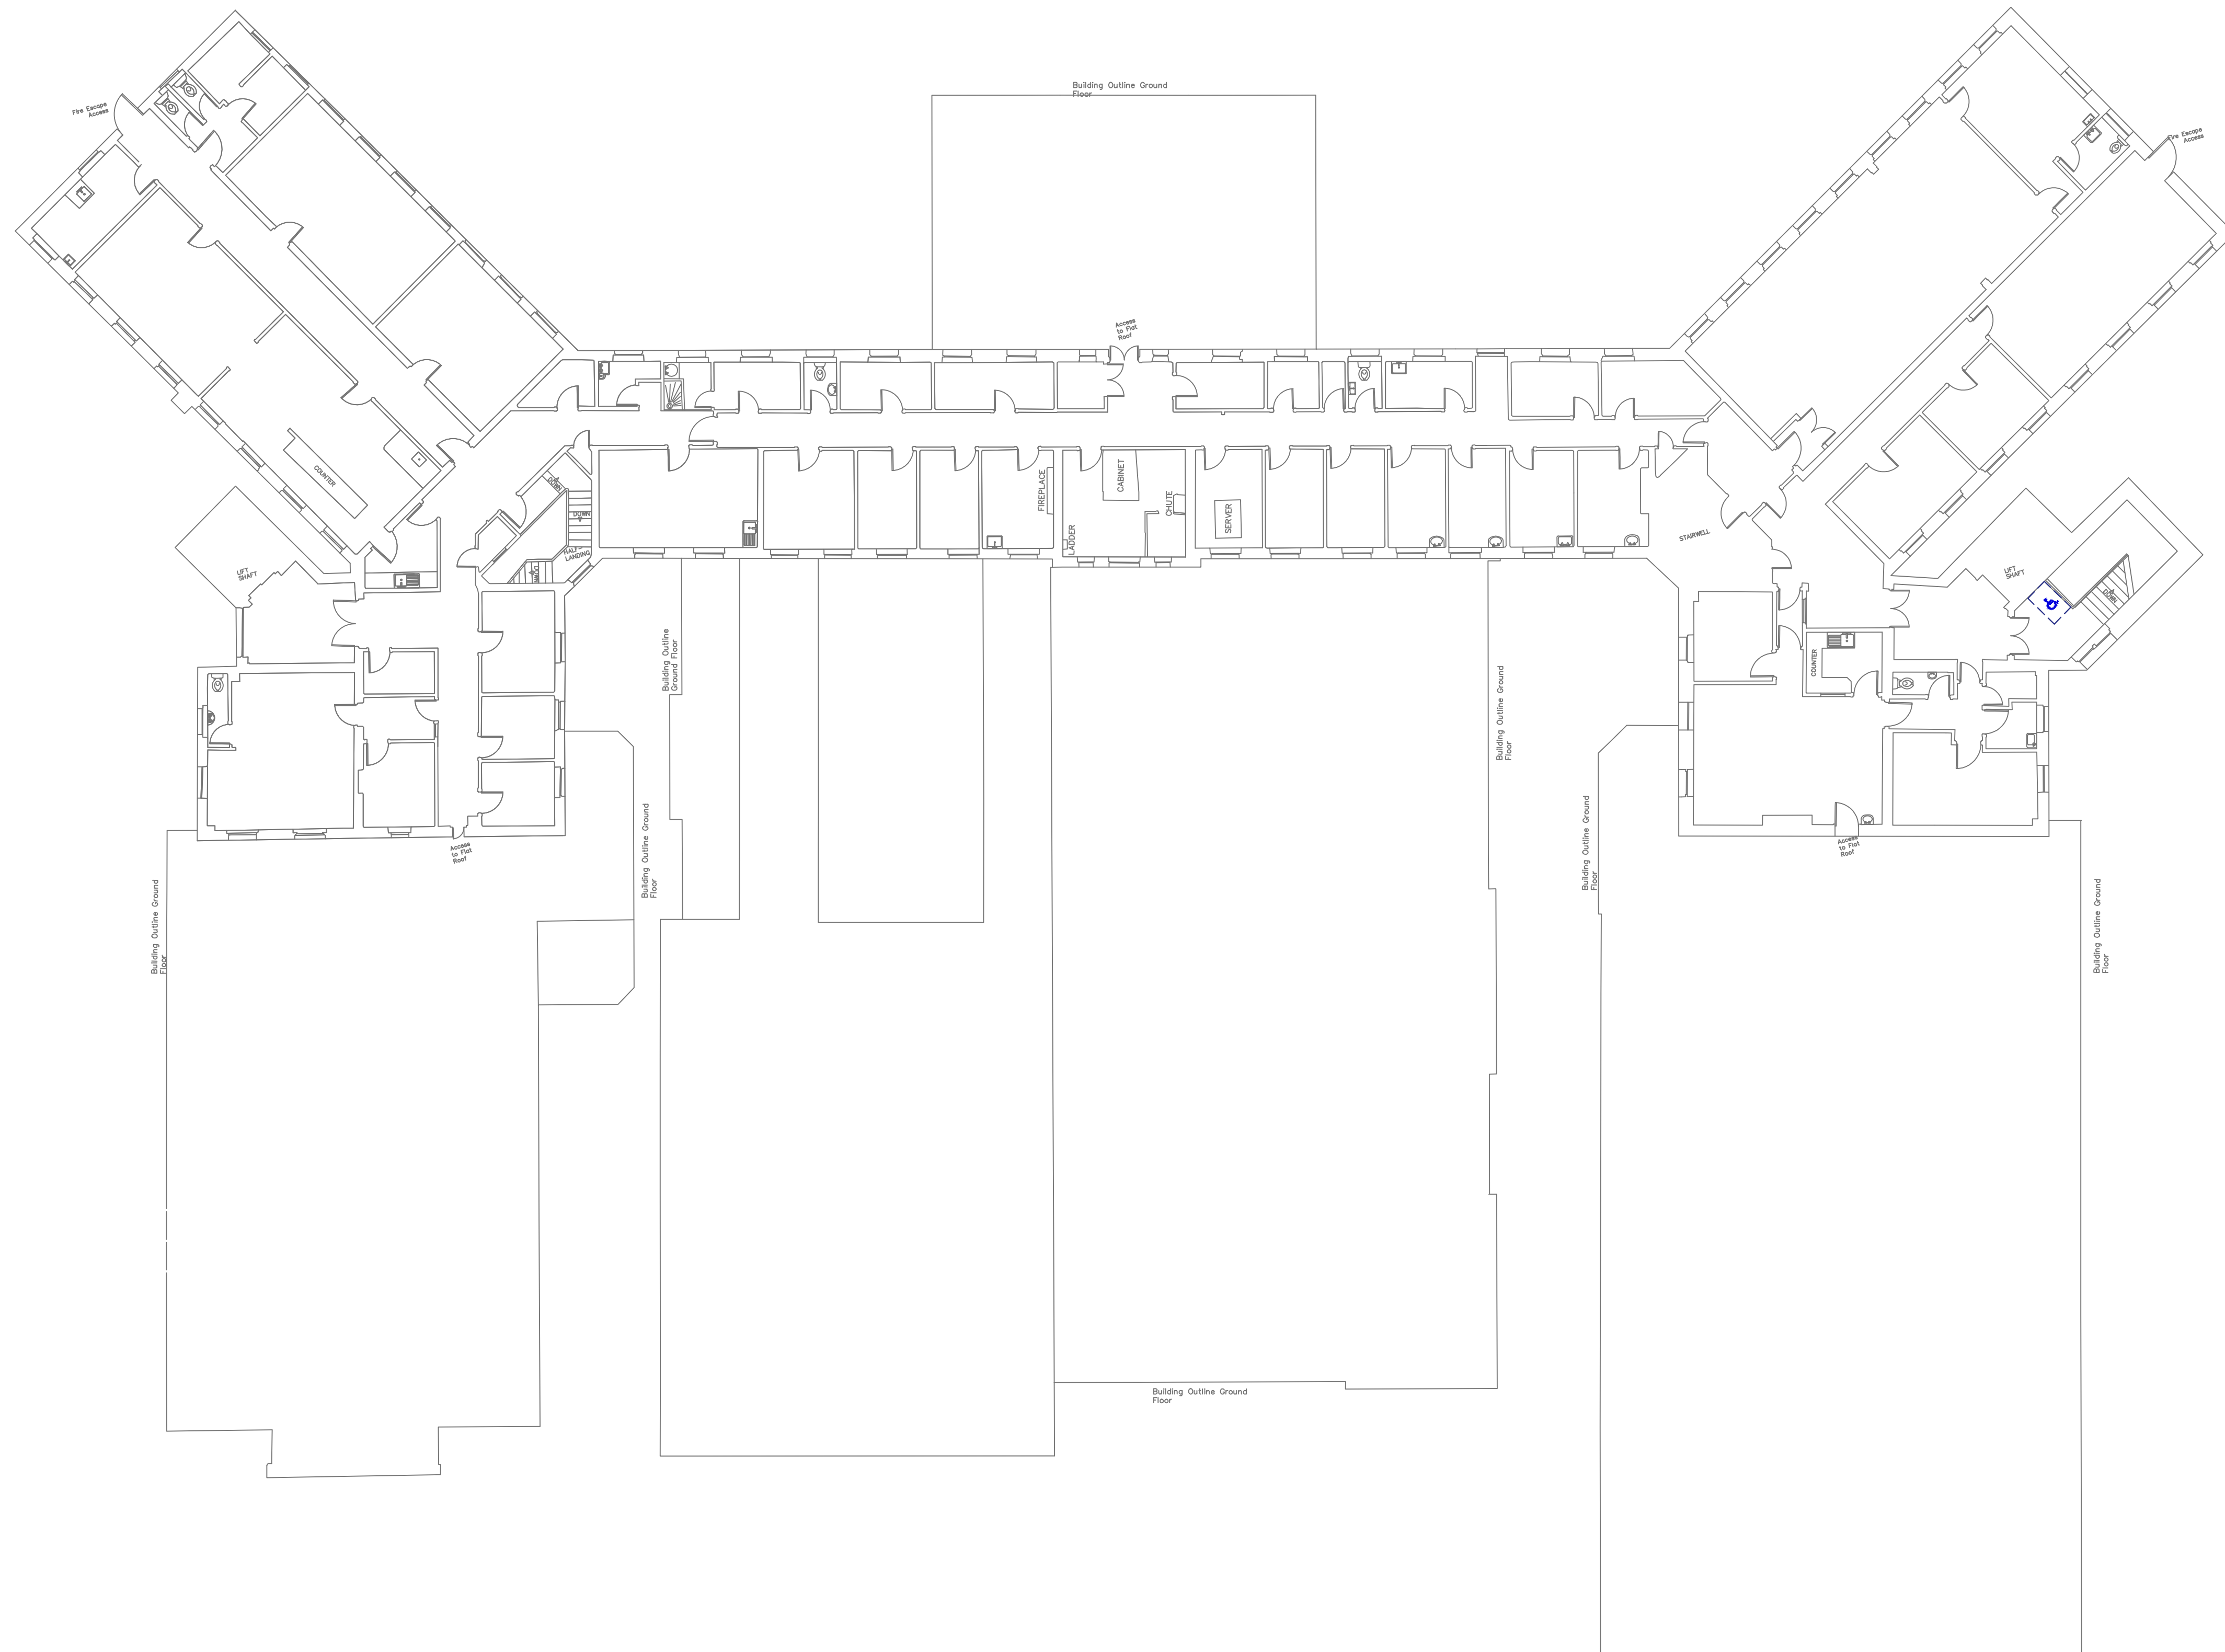

LEGEND



DISABLED REFUGE

A	FOR TENDER	DT	DD	MK	24/09/2026
ISSUE	DESCRIPTION	DRN	ORIG	APP	DATE



Unit A4, Nutgrove Office Park,
Rathfarnham, Dublin 14, D14 H1X4

ph +353 (0)1 663 0013 | fc +353 (0)1 663 0014
info@fire-cert.com | www.fire-cert.com

CLIENT

HEALTH SERVICE EXECUTIVE

PROJECT No.	PROJECT
26045	MONAGHAN GENERAL HOSPITAL, MULLAGHMONAGHAN, MONAGHAN, H18 NV91

DRAWING No.

26045-XX-L02-DR-FCC-FS-9003_DR

SHEET	SCALE	TITLE
A1	1:150	SECOND FLOOR PLAN