


IF IN DOUBT ASK

DO NOT SCALE OFF THIS DRAWING


NOTES

BUILDERSWORK OPES (BY OTHERS)			
REF.	PIPE Ø	SIZE	INVERT
1	150	350ø	1.325m
2	100ø	100ø	2.530m
3	150ø	150ø	2.253m


- NOTES:
- CENTRELINE OF OPE ON PLAN LAYOUT EQUALS CEN. LINE OF DUCT. ALL DUCTS SHALL BE 150ø UNLESS NOTED OTHERWISE.
 - ALL POWER DUCTS TO BE 150ø UNLESS NOTED OTHERWISE.
 - ALL TELECOM DUCTS TO BE 100ø UNLESS NOTED OTHERWISE.
 - ALL TELECOM DUCTS TO BE 100ø UNLESS NOTED OTHERWISE.
 - ALL PIPE INVERT LEVELS TAKEN FROM U/S OF OUTSIDE DIAMETER.
 - FOR ONE COMMON PORTABLE DAVIT TO BE SUPPLIED FOR EACH PUMP.
 - ELEC. KIOSK PLINTH ELEVATIONS TO BE CONFIRMED BY E.G.P.
 - ESB & TELECOM DUCT LOCATIONS TO BE CONFIRMED BY E.G.P.
 - ALL CIVIL WORKS BY OTHERS.
 - F.F.L. INTERCONNECTION LL & LOW LEVEL CUT-OUT CHANGED DUE TO PUMP VOLUME USING 62.7m CONCRETE RING. ALL PUMP LEVELS TO BE DETERMINED BY E.G.P. AT A LATER DATE.

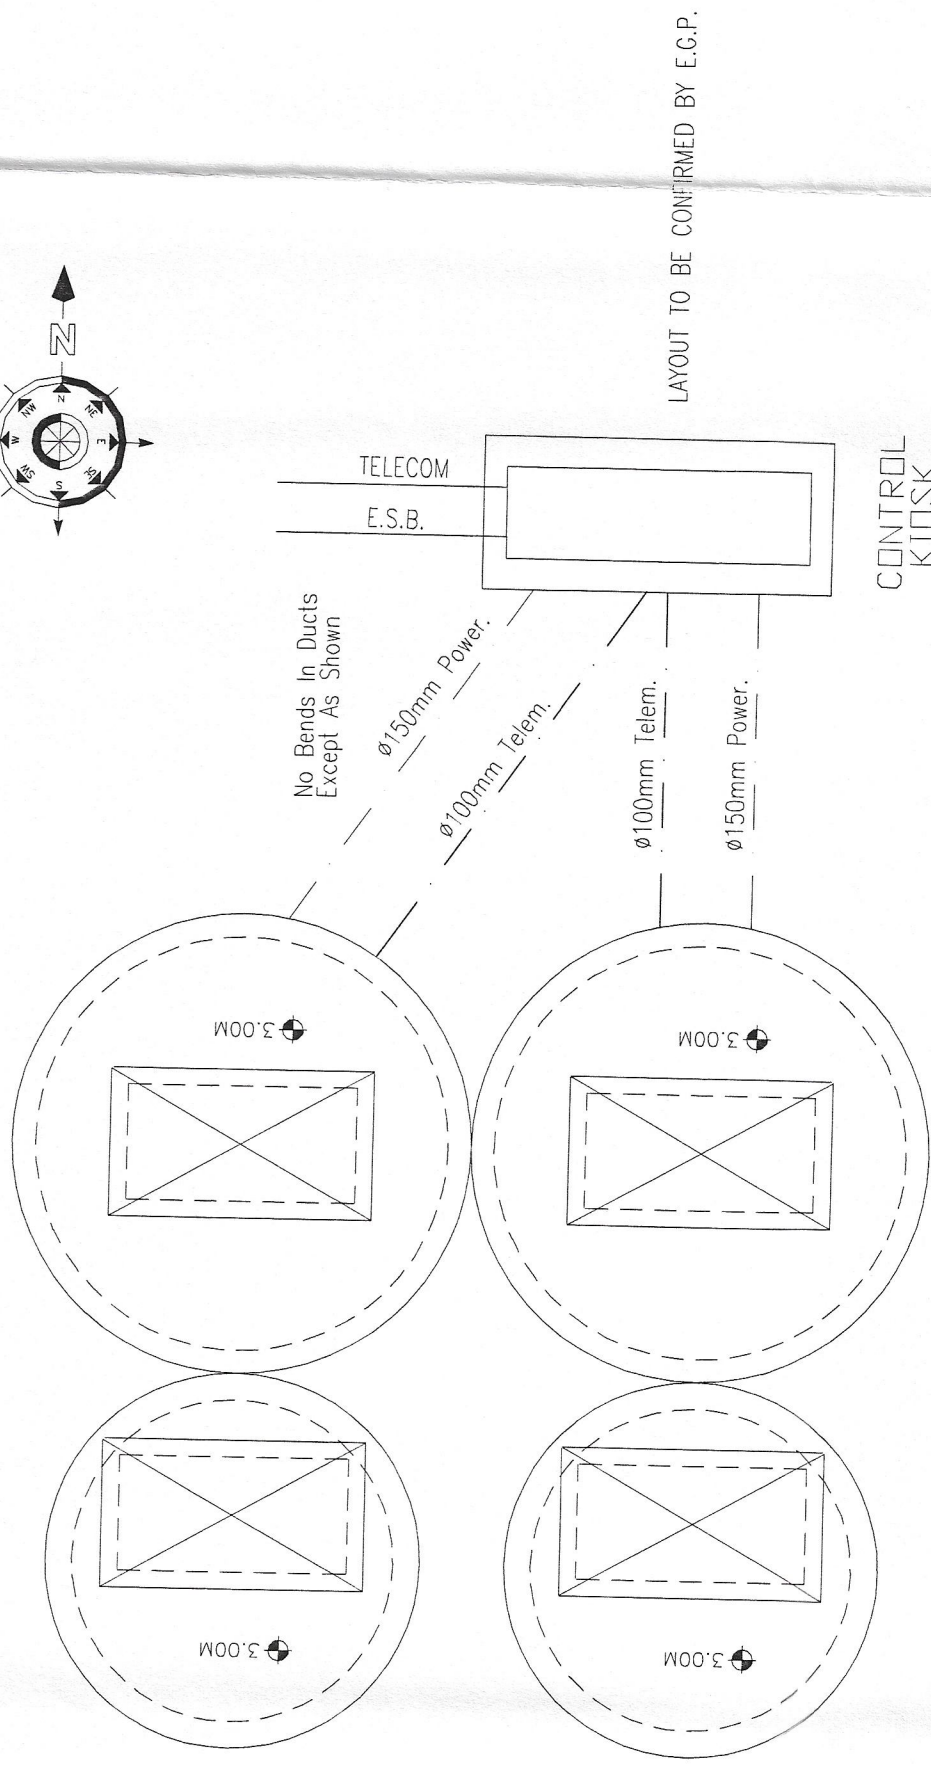


ROOF PLAN OF PUMP SUMP
SCALE 1:50

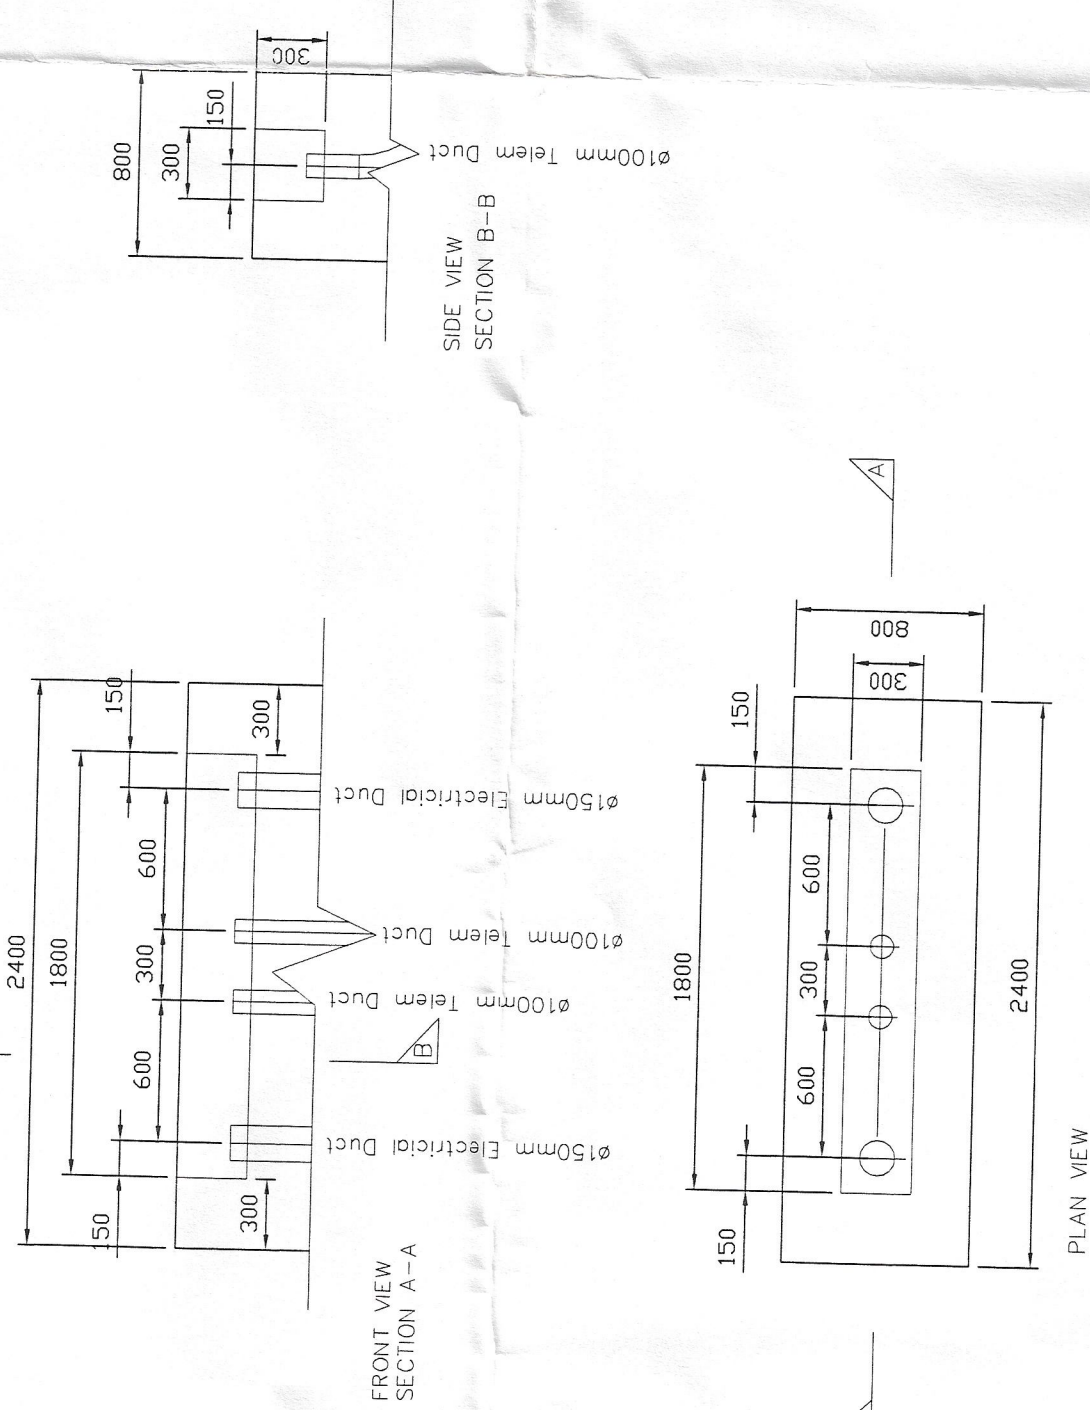


DETAILS OF CABLE CHAMBER
IN KIOSK PLINTH
N.T.S.

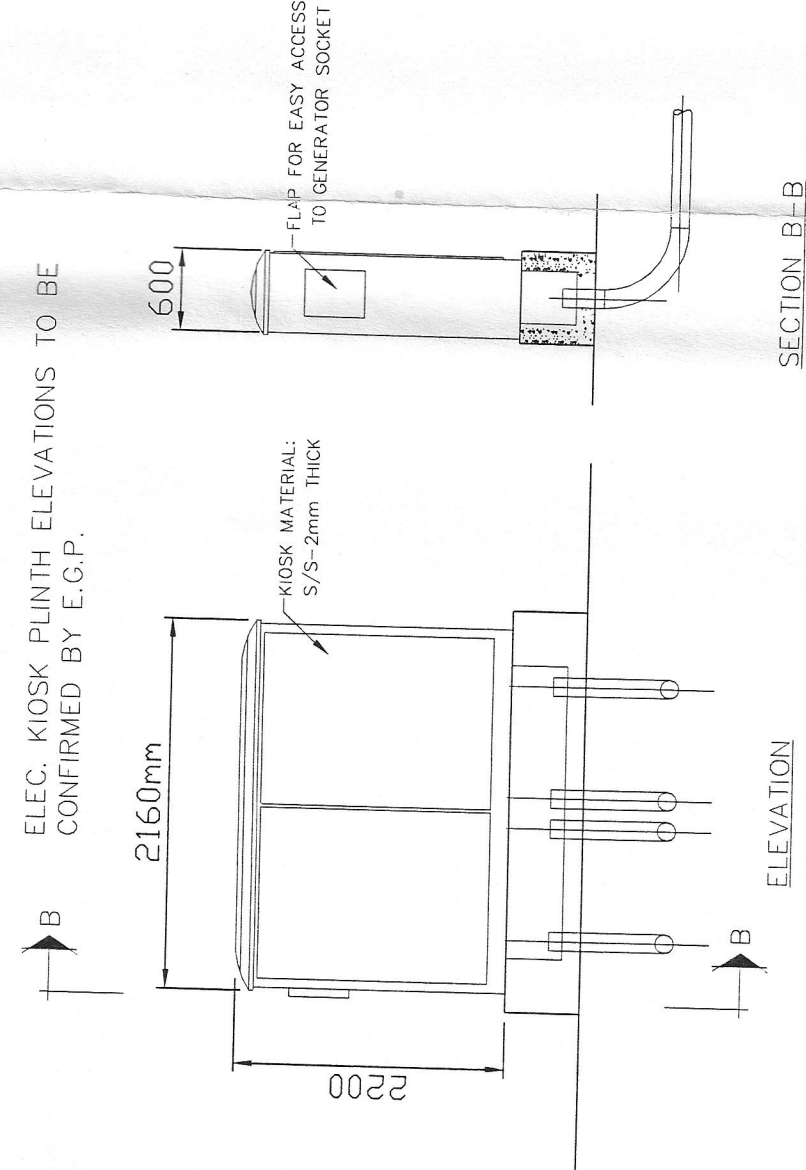

KIOSK DETAILS
N.T.S.

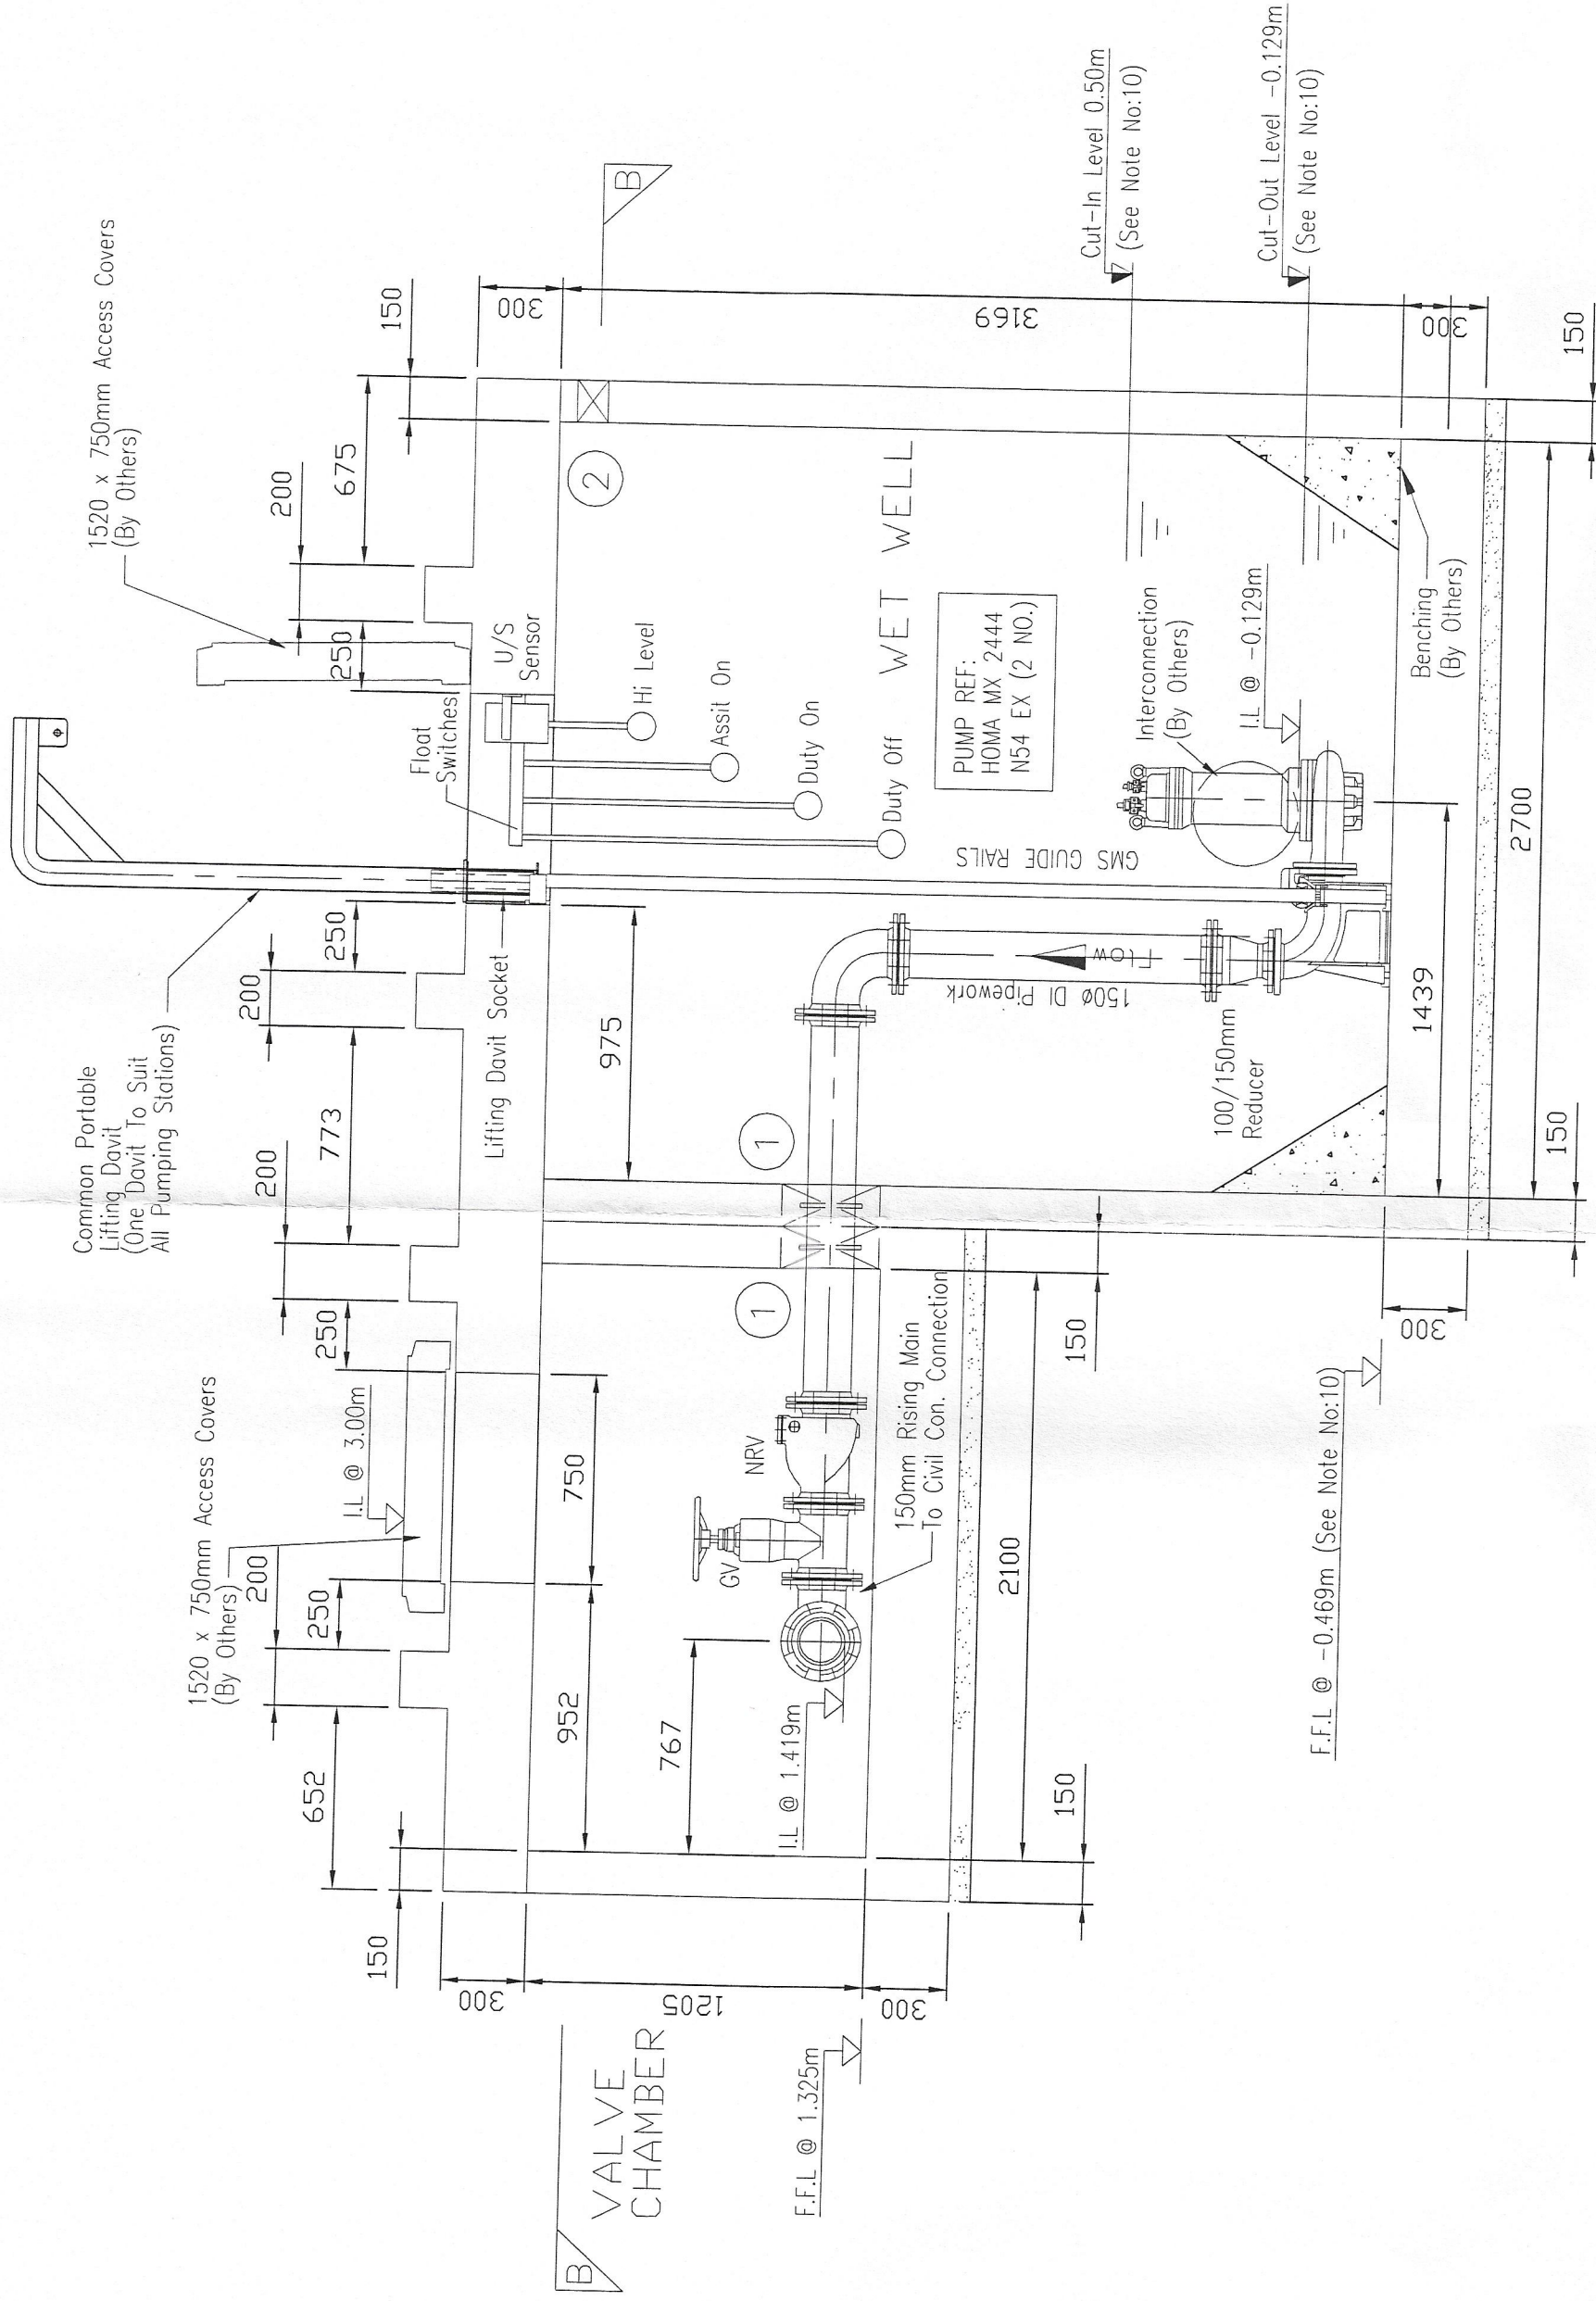

Section A-A
SCALE 1:25

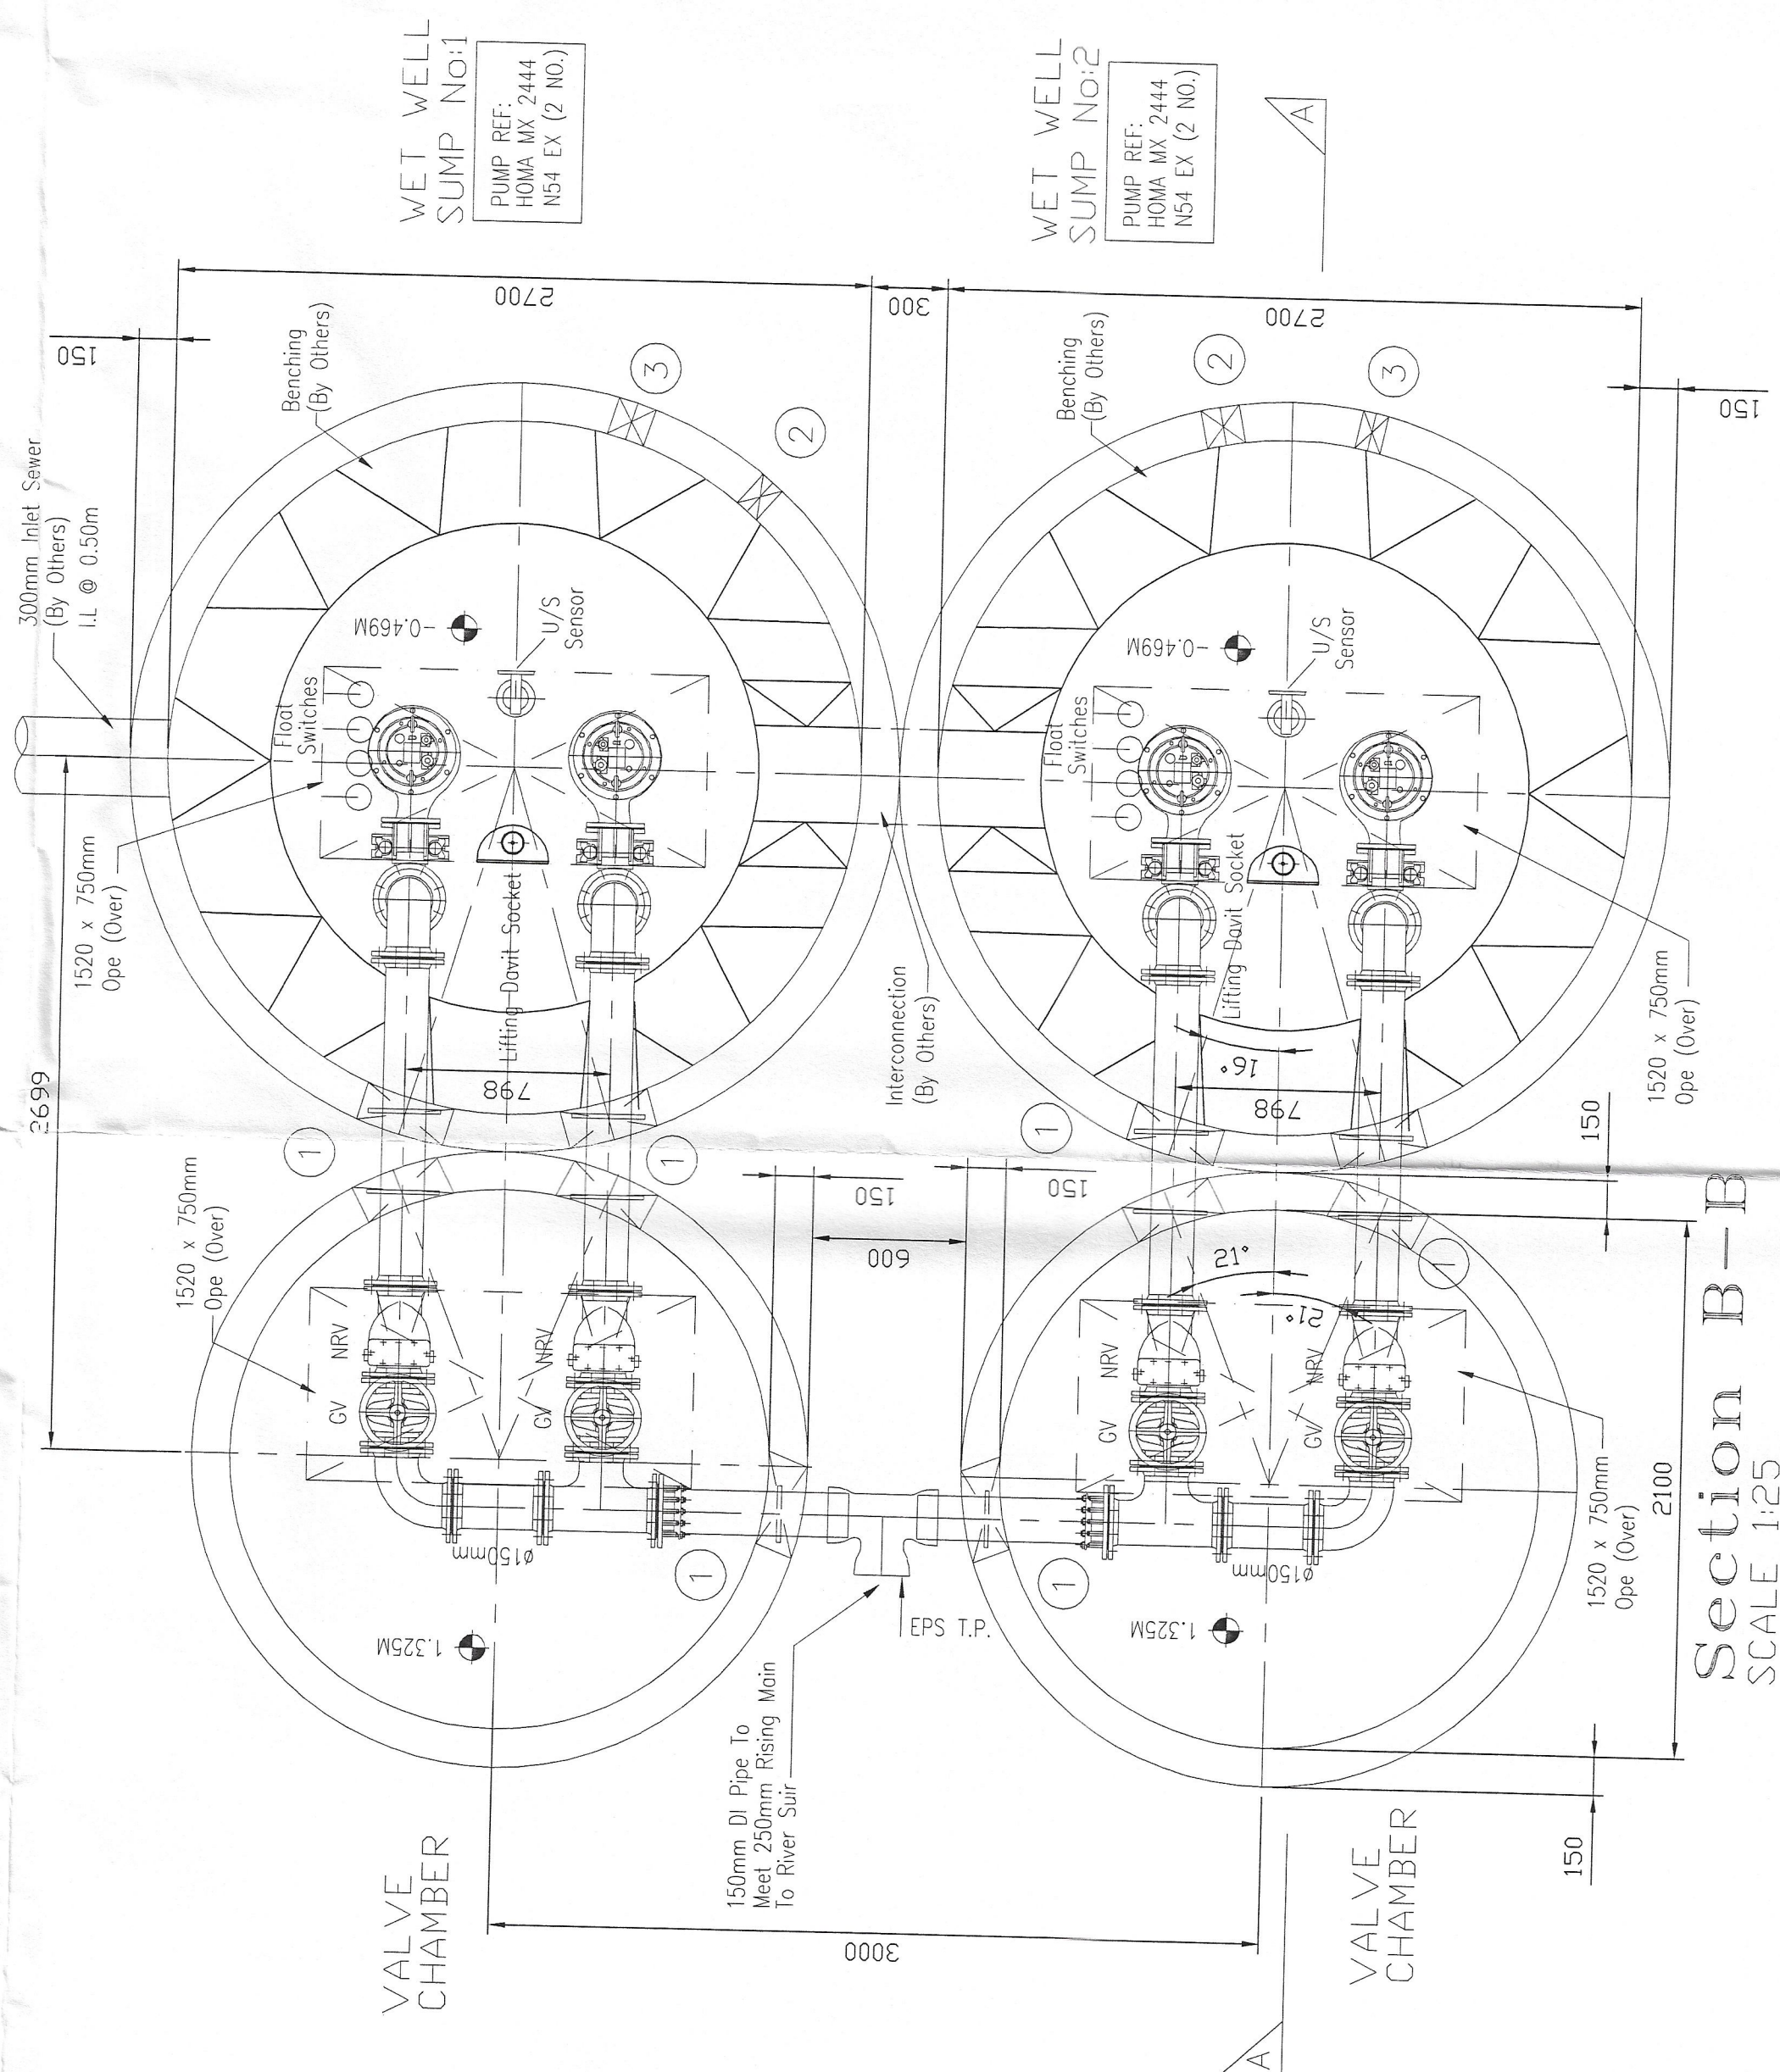

Section B-B
SCALE 1:25

Rev.	Name	Date	Description
2	DS	27/10/03	As Construction
1	DS	17/10/01	CHANGES TO PIPEWORK
0	DS	08/10/01	ISSUED FOR CONSTRUCTION
B	DS	02/10/01	CHANGES MADE AS PER EGP COMMENTS & RE-ISSUED FOR APPROVAL
A	DS	31/08/01	ISSUED FOR APPROVAL
Rev. Name Date			Description
No. Reqd.			Materials:
			Finish:

COPYRIGHT This drawing is protected by copyright and shall not be reproduced in any form without the prior written consent of E.G.P. Pumping & Treatment Systems.



Overtown Industrial
Bathkouna, Co. Mayo.
Phone: 0907-30226
Fax: 0907-30761
Mobile: 087-30761
Email: contracts@egp.ie
Website: www.egp.ie

Job Title:
CARRICK-ON-SUIR
SUIR RIVER
DRAINAGE SCHEME

Drawing Title:
DETAILS OF PUMPING
STATION No: 1

Scale:	AS SHOWN
Drawn By:	DS
Checked By:	A
Revision:	0
Suffix:	1
Job No.:	PC452
Drg No.:	PC452-01
Workshop No.:	