


AREA SUBJECT TO TENDER OUTLINED IN RED

Project Name: **ASTRO PITCH & ASSOCIATED WORKS AT HANOVER HARPS FC**
Status: **PLANNING**

Revisions	REV	DATE	DRAWN BY	APPROVED BY	NOTES

Project North

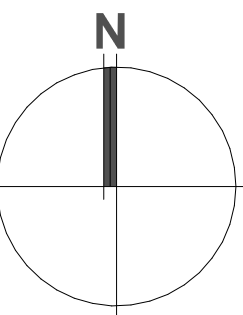

Notes

Key Plan

Not to Scale

Title:

DRAINAGE PLANS

Drawn By: **C. DEVLIN**
Checked By: **N/A**
Date: **16-01-2025**
Project No: **25005**
Scale: **As indicated**

Drawing No:


0003

ISO A1 594mm x 840mm


- XXX EFFECTIVE CLEAR WIDTH
XXX FINISHED FLOOR/CEILING LEVEL
X XXX SECTION TITLE/SHEET NO.
X GRID LINE
X.XX ROOM NO.
Room ROOM NAME
XX.XXm² ROOM AREA
W.X.XX WINDOW NO.
D.X.XX DOOR NO.
X XXX DETAIL NO./SHEET NO.



1 Proposed Drainage Plan
1 : 500

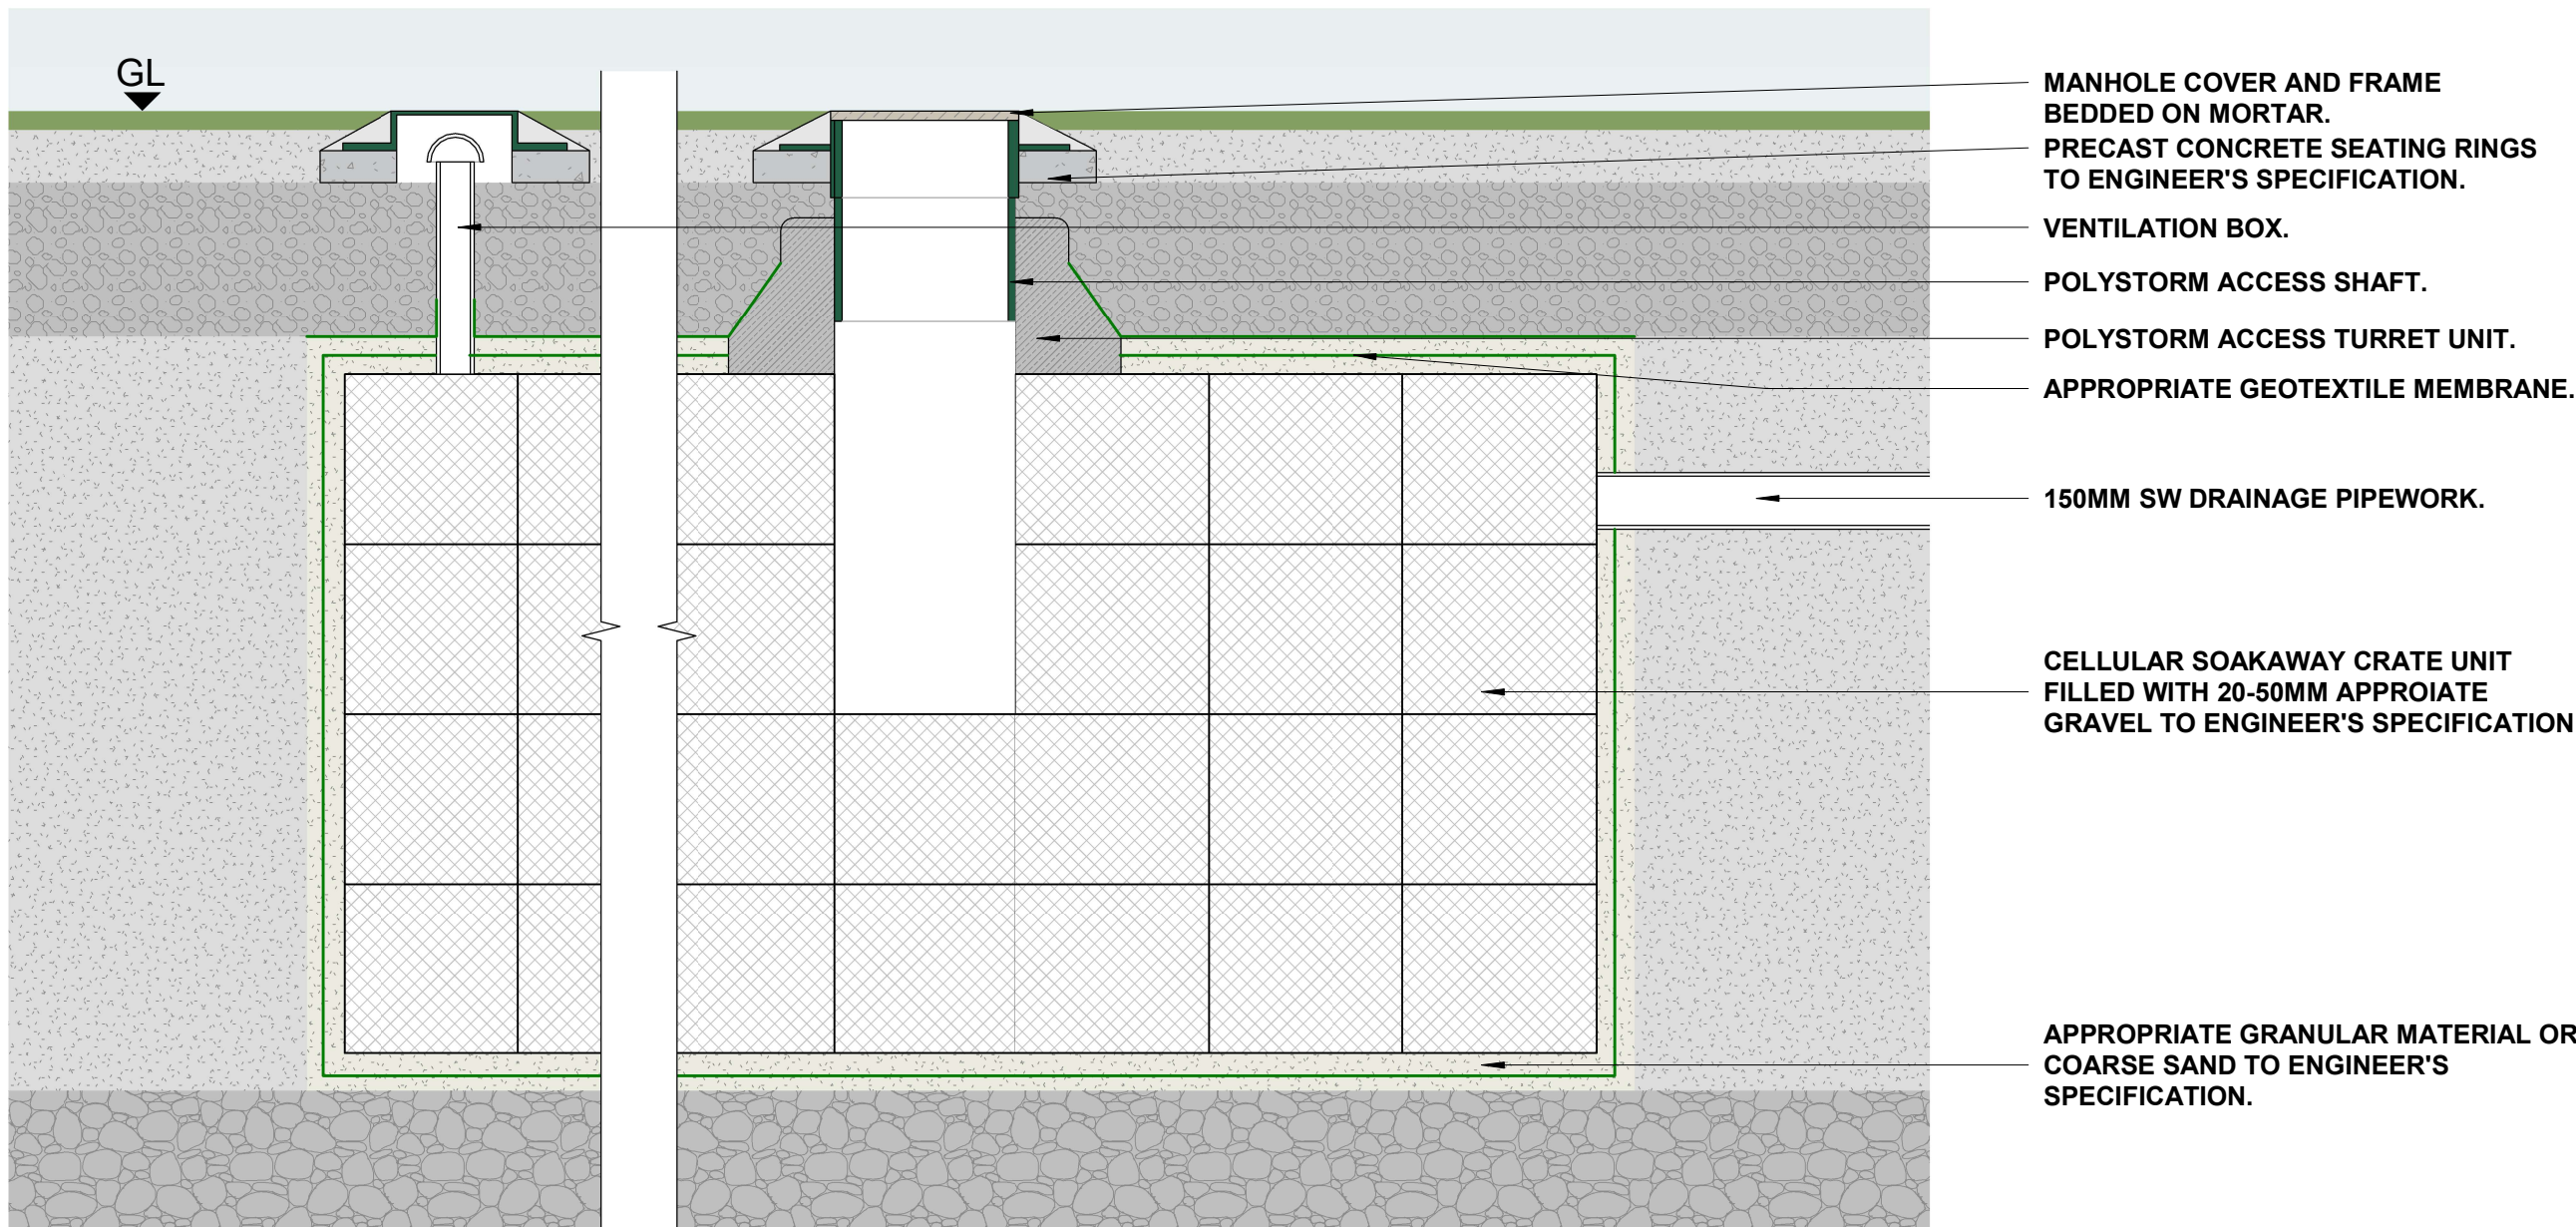

2 Proposed Soakhole Section
1 : 20

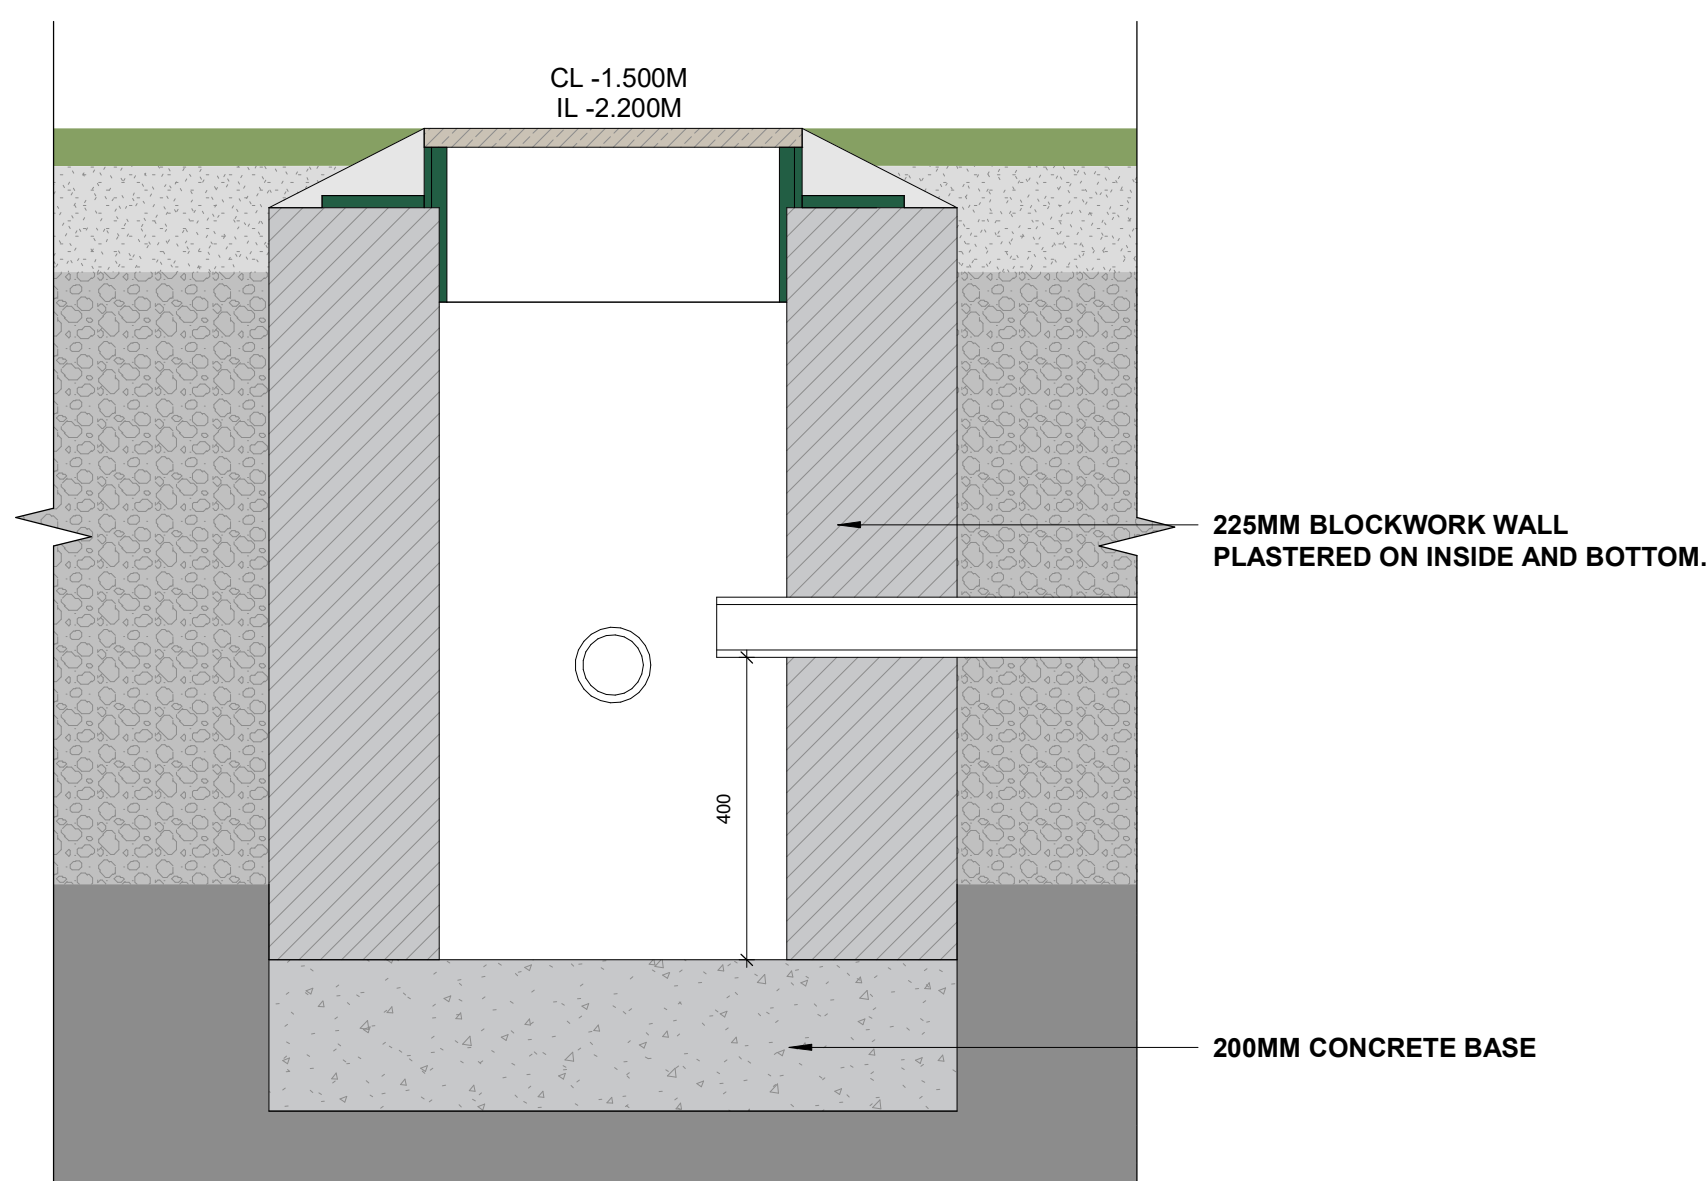

3 Silt Trap Detail
1 : 10