


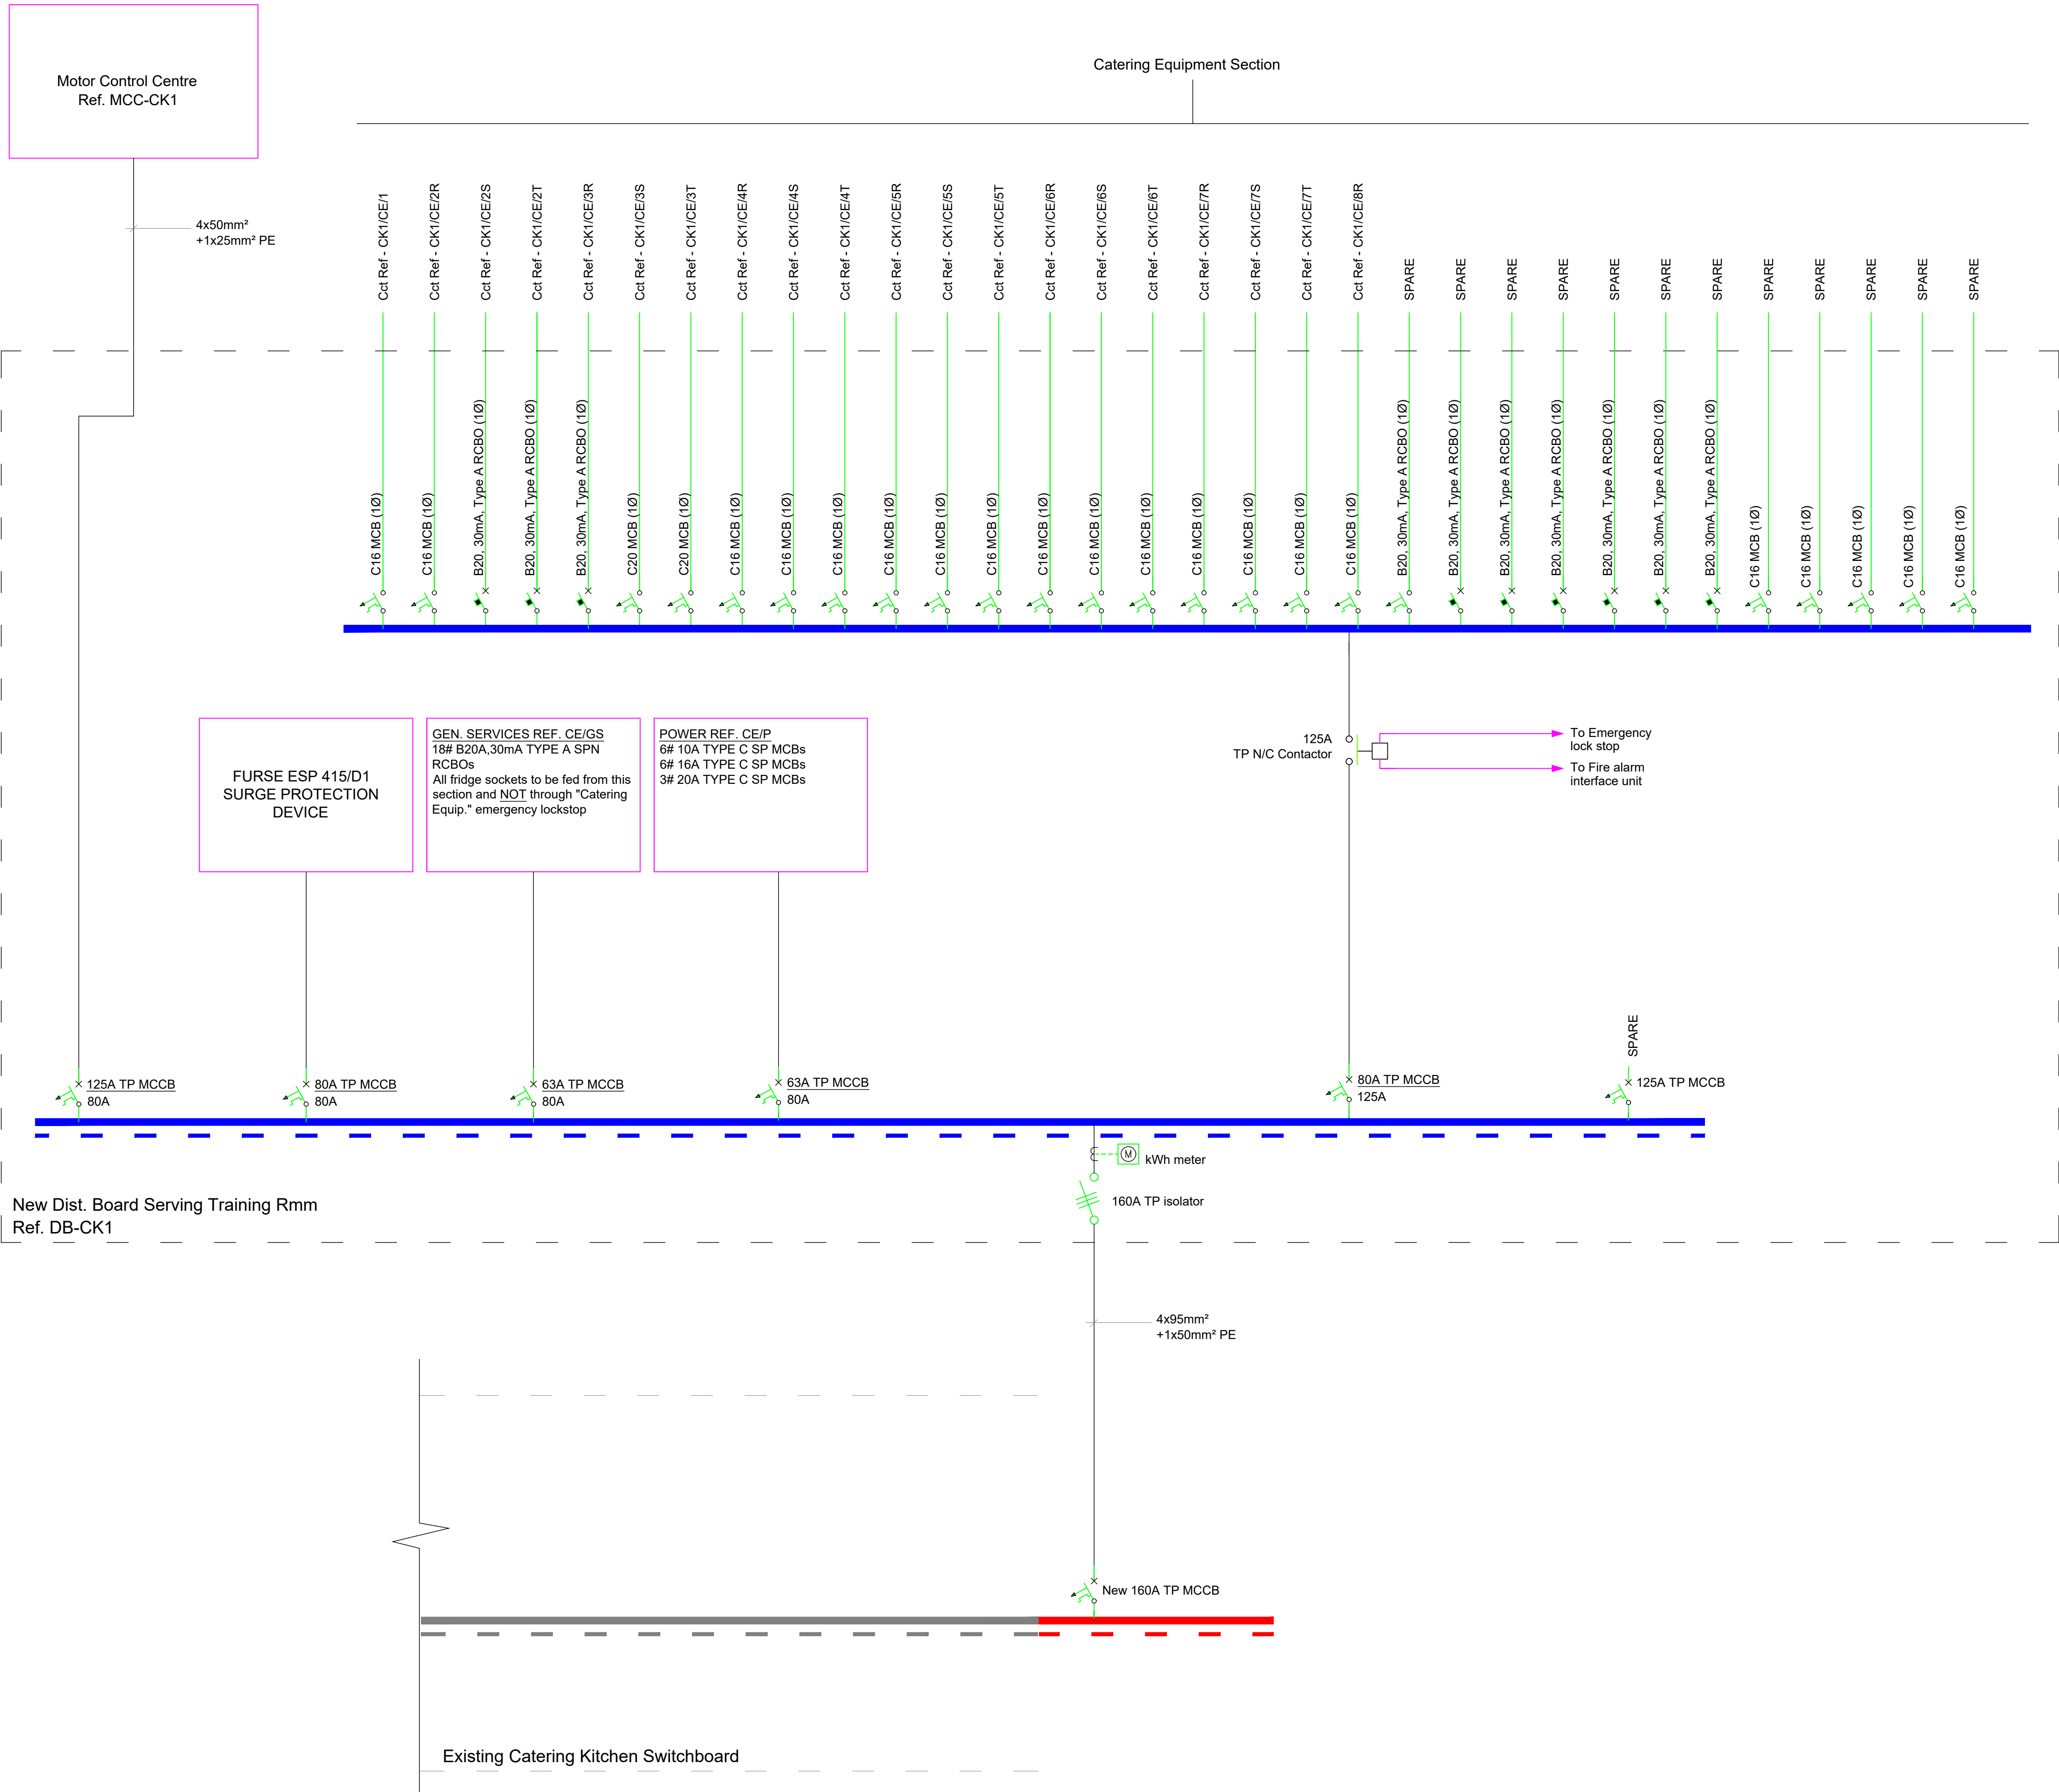

- Notes:
- These drawings are indicative only and are only provided to give a general overview of plant locations.
  - Contractor to liaise with mechanical contractor for obtaining full points schedule indicating all plant and associated contracts and detailing plant electrical loads and wiring requirements.
  - Final positions of all plans and controls to be agreed between mechanical and electrical contractors before commencing 1st fix works.
  - The Contractor shall refer to the Architectural and Structural Engineer's drawings, issued with the Main Contractors tender pack, to determine:
    - Form of construction of floor, walls and roof;
    - Ceiling void depths;
    - Floor to ceiling heights;
    - Floor, wall and ceiling finishes.

|     |          |                      |       |         |
|-----|----------|----------------------|-------|---------|
| P02 | 21/10/26 | UPDATED TENDER ISSUE | RV    | BS      |
| P01 | 17/09/26 | TENDER ISSUE         | RV    | BS      |
| REV | DATE     | DESCRIPTION          | DRAWN | CHECKED |

**DO NOT SCALE**  
This drawing is representative only.  
To be read in conjunction with Architects drawings.

CONSULTING ENGINEER:

**Bernard Smith**  
Consulting Engineers

Bernard Smith Consulting Engineers  
Bracktown Business Park | Clonsilla | Dublin 15  
t: 01-801 4127 | w: www.bernardsmith.ie | e: info@bernardsmith.ie

PROJECT:

**CAVAN INSTITUTE  
CATHEDRAL ROAD  
DRUMALEE, CO. CAVAN**

TITLE:

**MAINS DISTRIBUTION  
SCHEMATIC  
HOSPITALITY & CULINARY ROOM**

|                     |                 |                         |                |              |
|---------------------|-----------------|-------------------------|----------------|--------------|
| DATE:<br>01/09/2026 | DRAWN BY:<br>RV | BSCE JOB NO.:<br>26-038 | STATUS.:<br>D2 | REV.:<br>P02 |
| SCALE:<br>N/A       | CHECK'D:<br>BS  |                         |                |              |

DWG NO.:  
26038-BSCE-XX-00-DR-E-6900

**TENDER**