


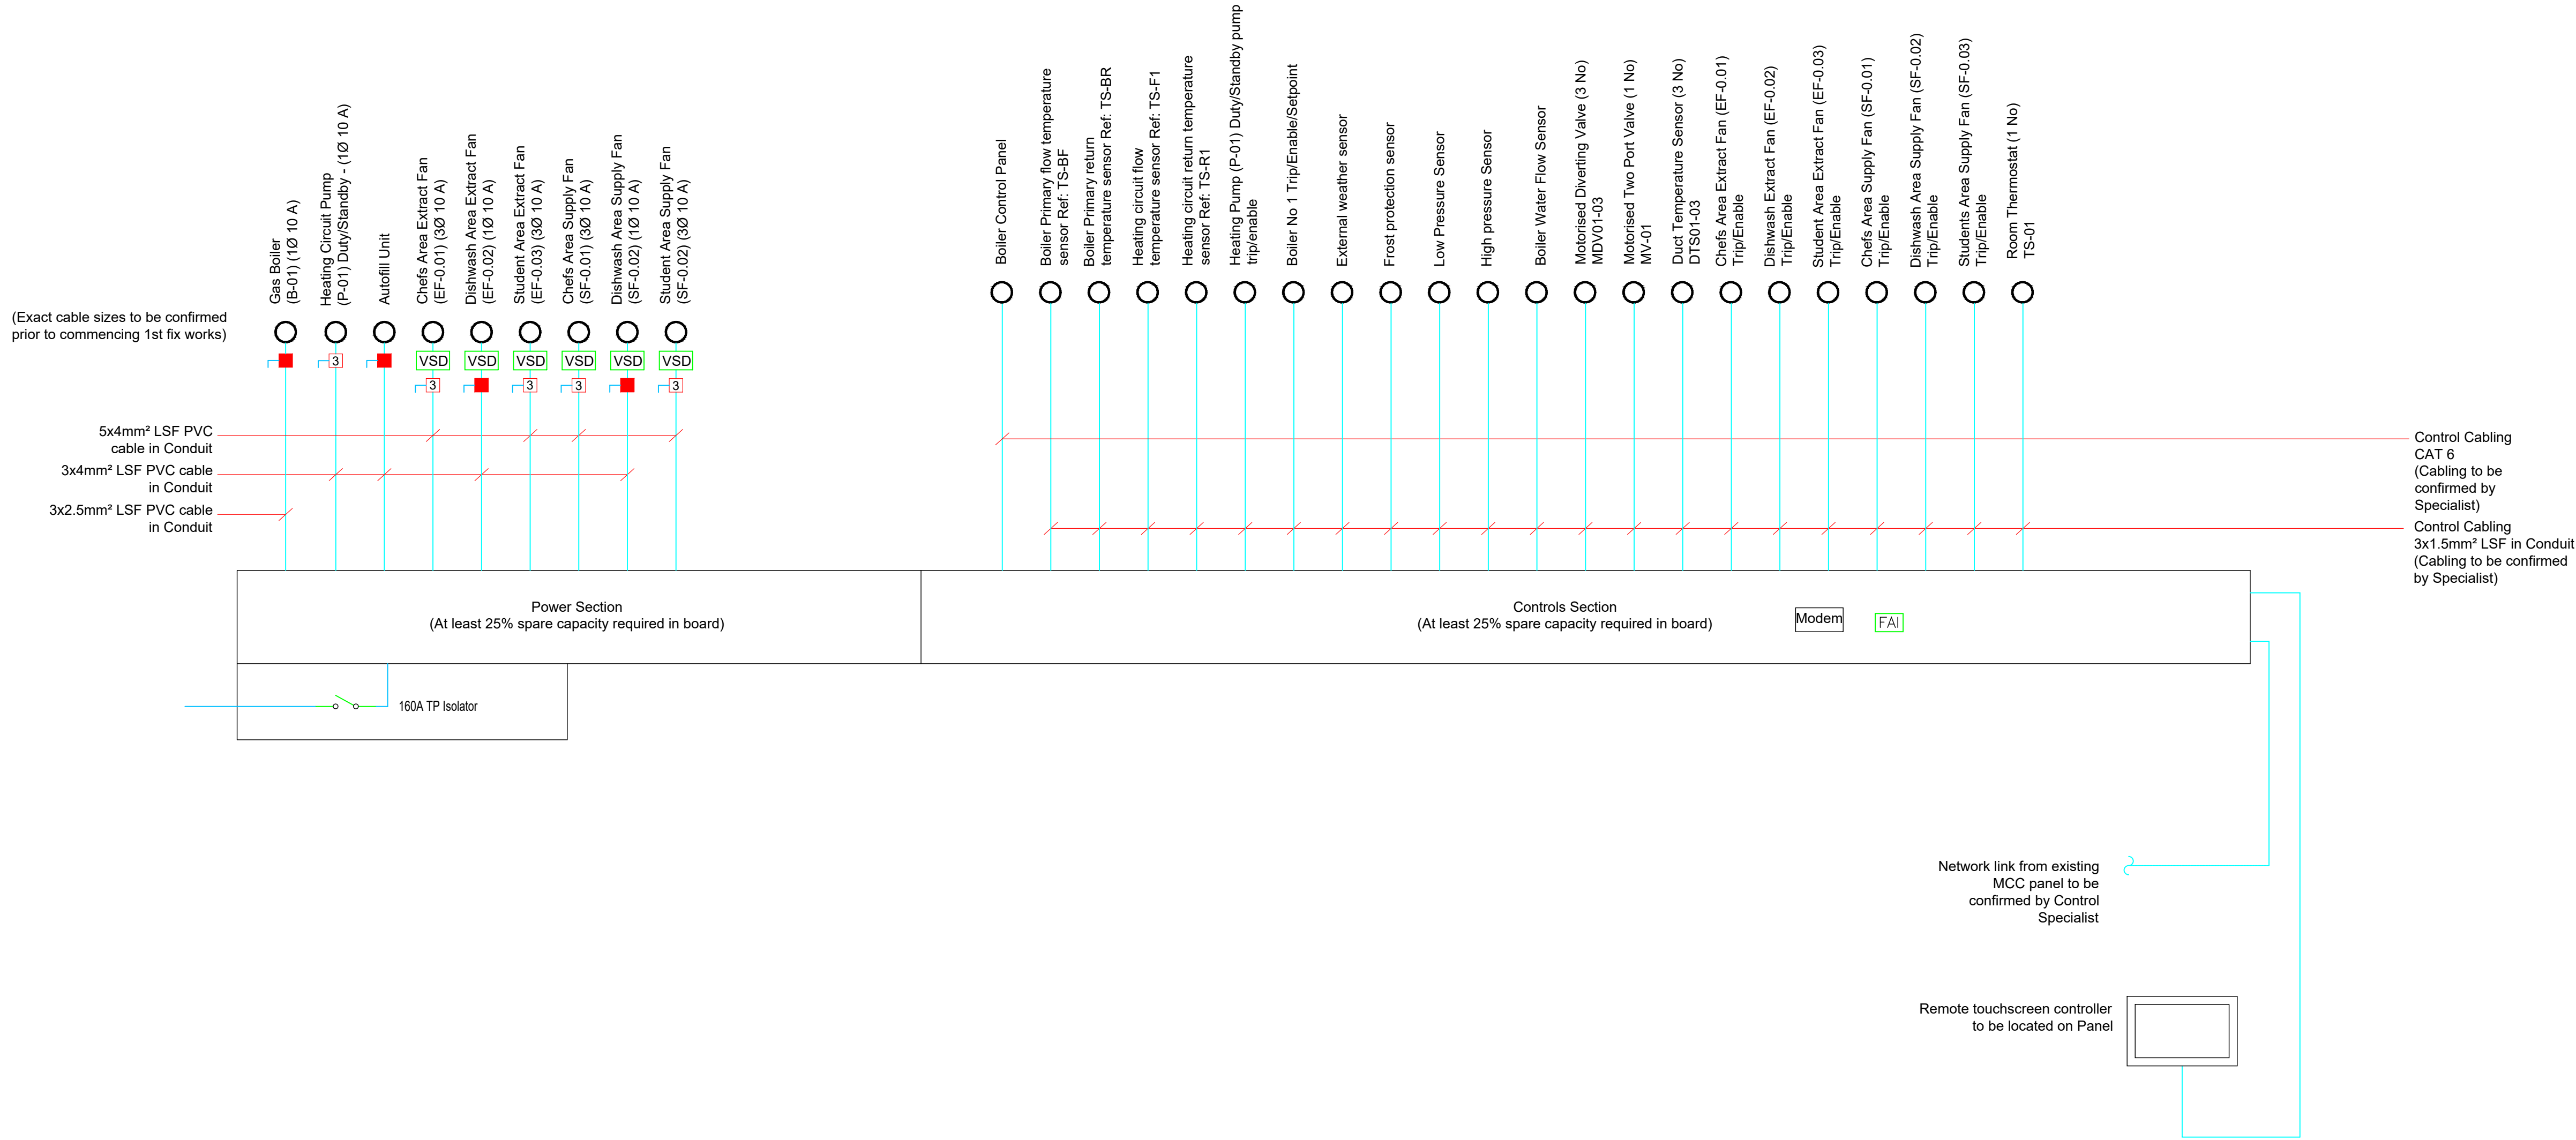

Plantroom Motor Control Centre
Ref. MCC-PR

- Notes:
- These drawings are indicative only and are only provided to give a general overview of plant locations.
 - Contractor to liaise with mechanical contractor for obtaining full points schedule indicating all plant and associated contracts and detailing plant electrical loads and wiring requirements.
 - Final positions of all plans and controls to be agreed between mechanical and electrical contractors before commencing 1st fix works.
 - The Contractor shall refer to the Architectural and Structural Engineer's drawings, issued with the Main Contractors tender pack, to determine:
 - Form of construction of floor, walls and roof;
 - Ceiling void depths;
 - Floor to ceiling heights;
 - Floor, wall and ceiling finishes.

P02	22/10/26	UPDATED TENDER ISSUE	JV	ML
P01	17/09/26	TENDER ISSUE	ML	ML
REV	DATE	DESCRIPTION	DRAWN	CHECKED

DO NOT SCALE

This drawing is representative only.
To be read in conjunction with Architects drawings.

CONSULTING ENGINEER:



Bernard Smith Consulting Engineers
Bractown Business Park | Clonee | Dublin 15
t: 01-801 4127 | w: www.bernardsmith.ie | e: info@bernardsmith.ie

PROJECT:

CAVAN INSTITUTE
CATHEDRAL ROAD
DRUMALEE, CO. CAVAN

TITLE:

MCC SCHEMATIC

DATE: 20/08/2026	DRAWN BY: ML	BSCE JOB NO.: 26-038	STATUS.: D2	REV.: P02
SCALE: NTS	CHECK'D: ML			

DWG NO.:
26038-BSCE-XX-XX-DR-M-5902

TENDER